

WHIPPLE CALLENDER ARCHITECTS

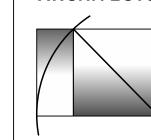

136 PLEASANT AVE.
PORTLAND, ME 04103
P 207.775.2696
F 207.775.3631
www.whipplecallender.com

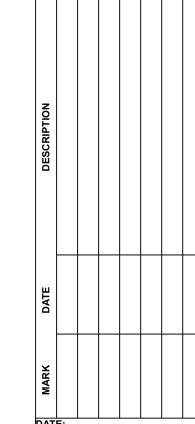

DATE:

10/3/17

CHECKED BY:

JAD

DRAWN BY:


JOB:

EAP 2017

SHEET TITLE:

ELECTRICAL PLANS

E1.1

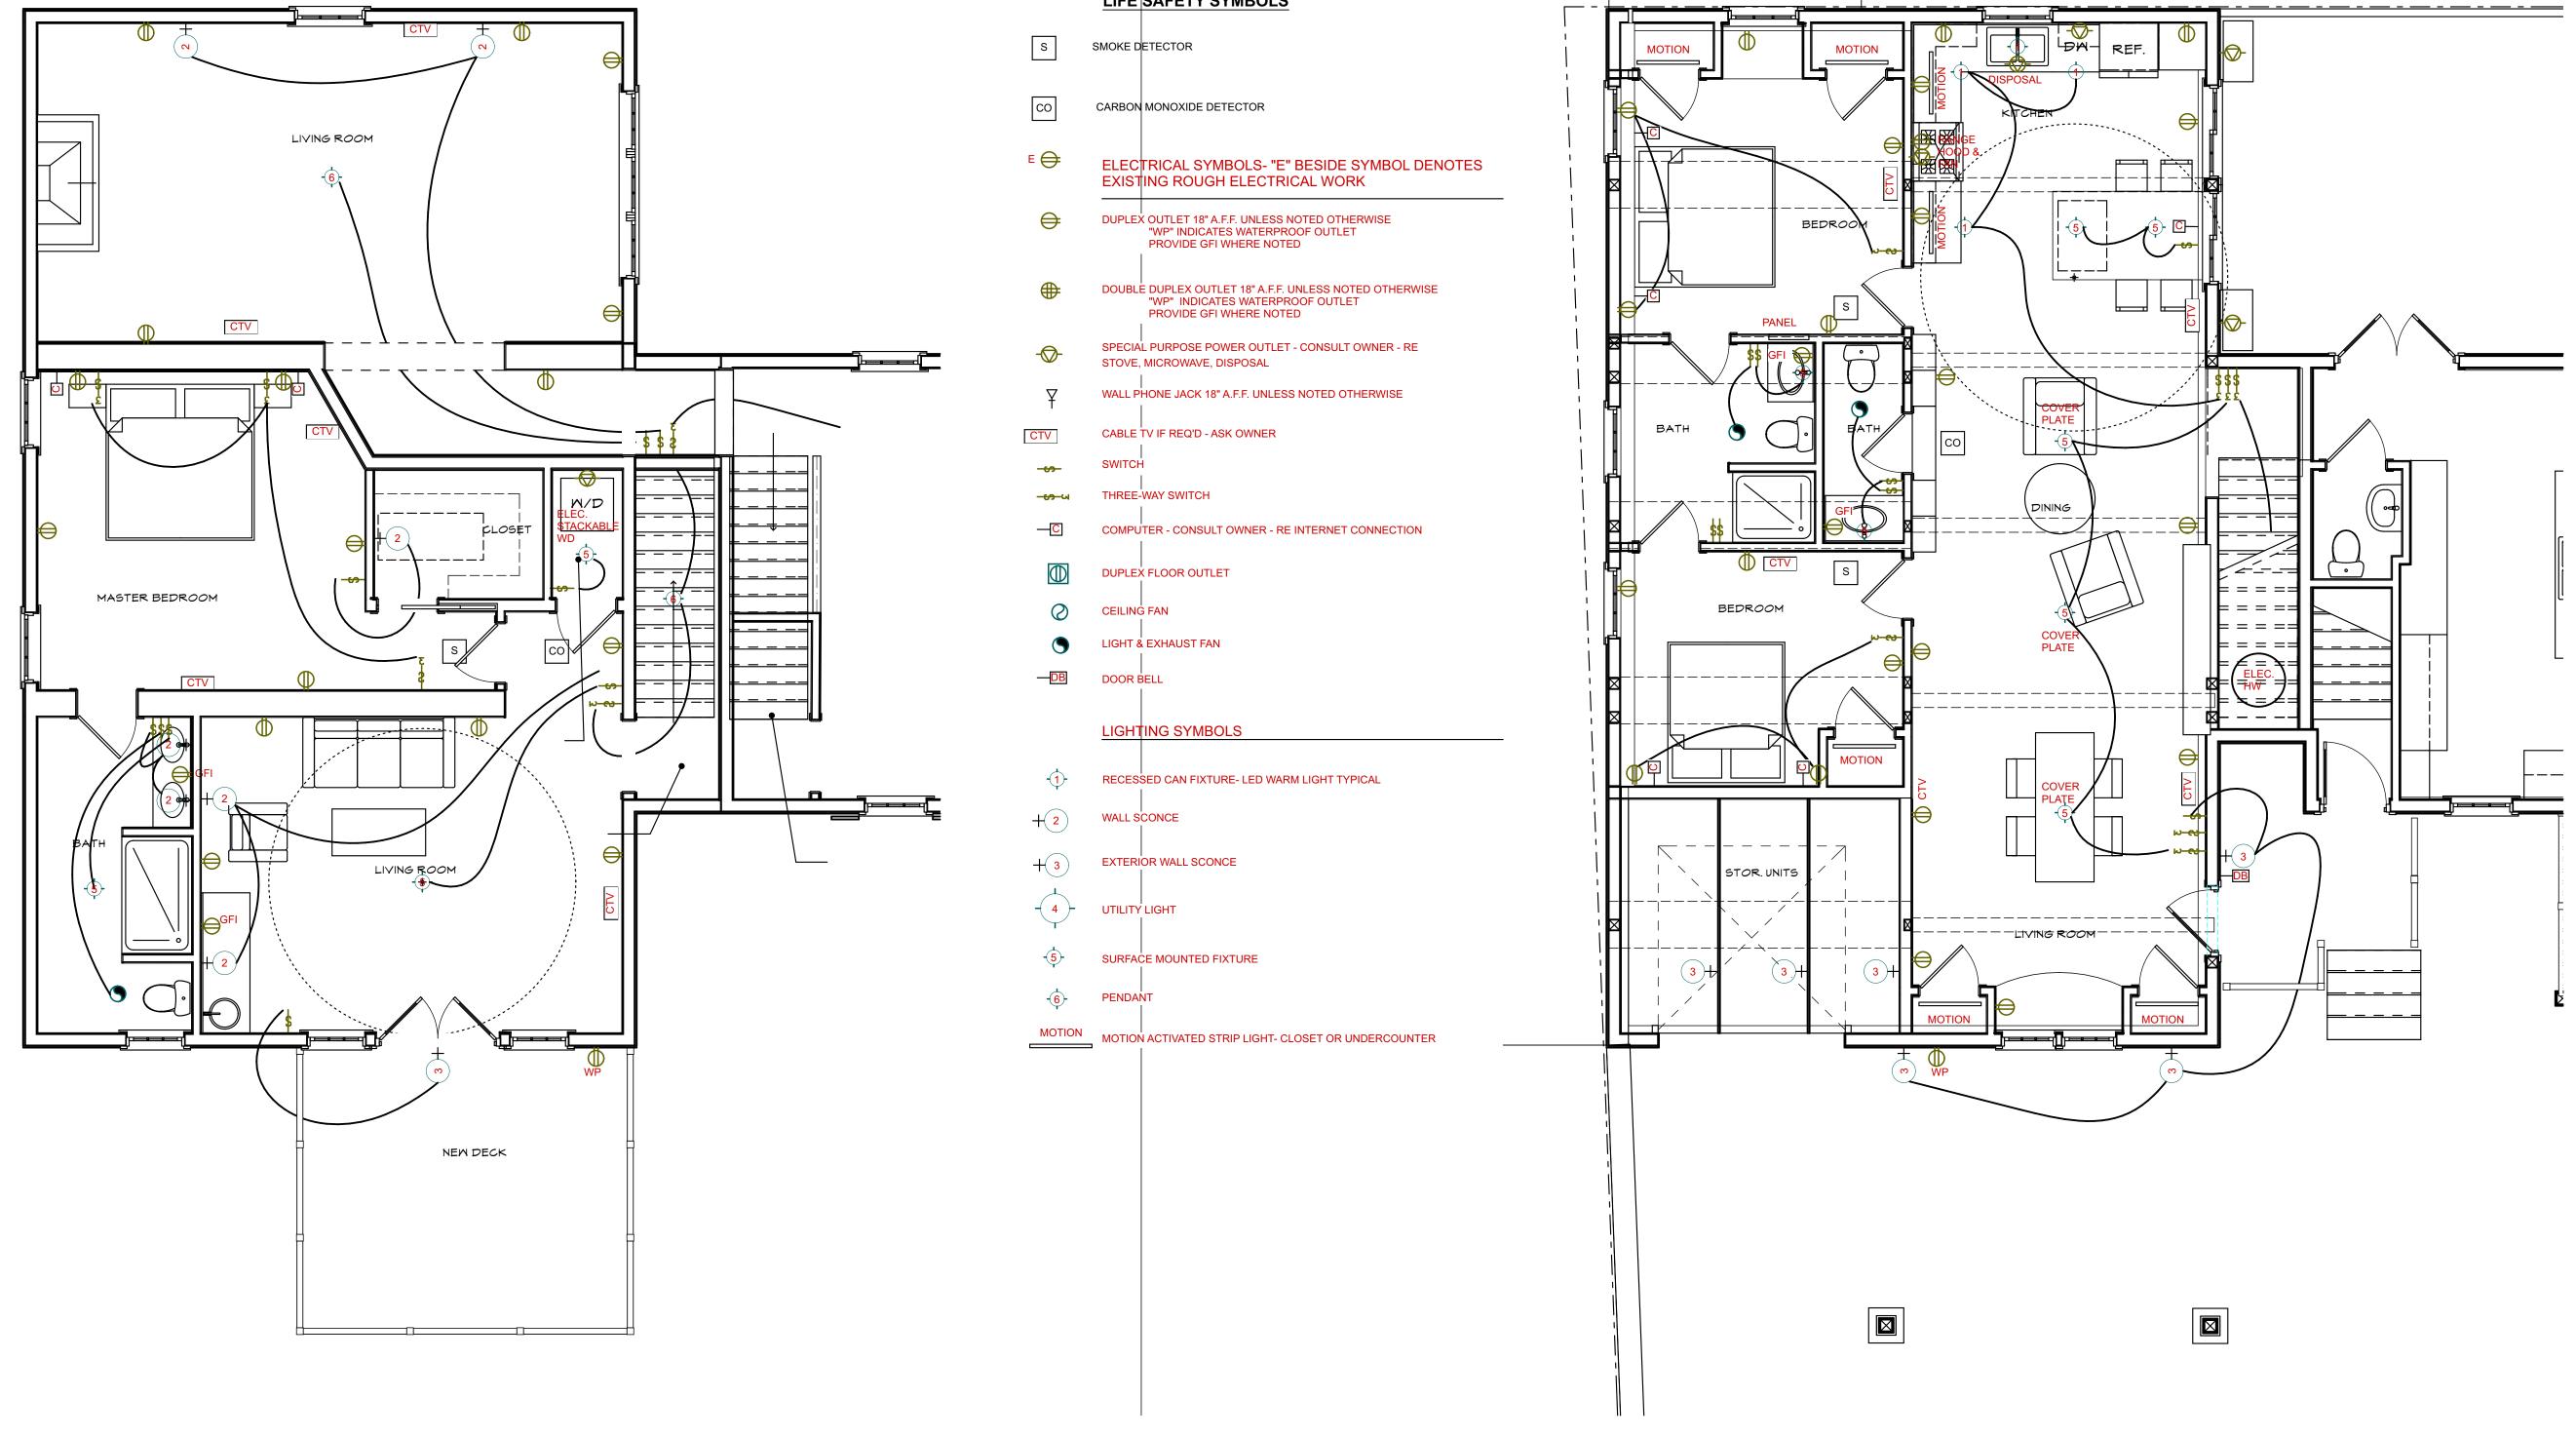

LIFE SAFETY SYMBOLS

SECOND FLOOR ELECTRICAL PLAN

SCALE: 1/4" = 1'-0"

1 GROUND FLOOR ELECTRICAL PLAN
SCALE: 1/4" = 1'-0"