

NOTE:

LUMP SUM METHOD WAS USED TO CALCULATE ALLOWABLE VOLTAGE DROP. THIS METHOD IS RECOMMENDED FOR THE MARGIN OF SAFETY IT PROVIDES FOR THE UNKNOWN. IT TAKES INTO CONSIDERATION THAT THE ROUTING SHOWN ON THE SHOP DRAWINGS MAY DIFFER FROM WHAT IS THE ACTUAL INSTALLED CIRCUIT. IF THE ACTUAL CIRCUIT LENGTH IS GOING TO EXCEED THE MAXIMUM ALLOWABLE CIRCUIT LENGTH, CONTACT YOUR LOCAL SIMPLEXGRINNELL DISTRICT OFFICE.

<u>LEGEND</u>

LOCATED OUTSIDE

LOCATED IN SPRINKLER ROOM 120VAC 20 A.

F PULL STATION (4099-9001)

S SMOKE SENSOR (4098–9714 HEAD, 4098–9792 BASE)

MONITOR MODULE - SUPERVISED (4090-9001 MODULE, 4090-9810 BRACKET, 4090-9806 COVER)

SPRINKLER WATER FLOW SWITCH (F.B.O.)

SPRINKLER TAMPER SWITCH (F.B.O.)

TRANSIENT CUBE, IDNET (2081-9027)

TRANSIENT CUBE (2081-9028)

STROBE - WEATHER PROOF (4906-9105 w/4905-9828 BACKBOX)

END OF LINE RESISTOR (6.8K = 4081-9004)

EARTH GROUND

GENERAL NOTES

ALL Fire Alarm System wiring shall comply with the National Electrical code, applicable state and local Fire and Safety Codes, as well as being coordinated with the Local Authority having jurisdiction.

2. CAUTION: Fire Alarm System Wiring Shall be isolated from all other conductors and MUST test free of all grounds.

3. CAUTION: <u>DO NOT</u> connect any power to Control Panel (batteries or 120 vac) until all other field wiring is tested, connected and free of all grounds.

to or in the same raceway with fire alarm system conductors. 5. CAUTION: Minimum no. 18 AWG wire for 24 VDC wiring, or

4. <u>DO NOT</u> install any A.C. current carrying conductors close

6. See SimplexGrinnell model 4010ES manual or your Technical representative for further instructions.

7. ALL wiring is to be copper conductors only. If shielded wire is used, the following must be observed: A. Metallic continuity of the shield must be maintained throughout the entire length of the cable. B. The entire length of the cable must have a resistance greater than 1 MEGOHM to earth ground.

8. Underground wiring must be free of all water.

9. In areas of high lightning activity or which have large power surges, transient suppressers should be used on the monitor points and any system wires that leave the building.

10. Wires must not be run through elevator shafts. 11. A system ground MUST be provided for earth detection and lightning protection devices. The connection


shall be made to an approved dedicated earth

connection per NFPA78.

TO NEXT DETECTOR LOCAL 120VAC w/ 9VDC BACKUP SMOKE DETECTOR (7109CS) LOCAL 120VAC w/ 9VDC BACKUP CO DETECTOR (CO5120BN) TYPICAL LOCAL 120VAC CO & SMOKE DETECTOR WIRING

				Standby	Total	Alarm	Total
Module	Qty	Description		Current	Standby	Current	Alarm
Panel Equipment							
4010-9401	1	FACP, 248PT IDNET, 1 BAY, 120V, RED	*	0.3160	0.3160	0.4300	0.4300
4010-9912	1	SERIAL DACT		0.0300	0.0300	0.0400	0.0400
	•		Panel Totals		0.3460		0.4700
DNet Addressable Dev	ices (SLC						
4099-9001	4	IDNET SINGLE ACTION PULL STATION	*	0.0000	0.0000	0.0000	0.0000
4090-9001	8	IDNET SUPERVISED IAM	*	0.0000	0.0000	0.0000	0.0000
4098-9714	4	TRUEALARM PHOTO SMOKE SENSOR		0.0000	0.0000	0.0000	0.0000
4098-9792	4	TRUEALARM SENSOR BASE	*	0.0000	0.0000	0.0000	0.0000
Miscellaneous Peripher	al Device	s That May Require System Power					
4606-9102	3	LCD ANNUN FOR 4010ES FACP (RUI)		0.0650	0.1950	0.1400	0.4200
Notification Appliances							
4906-9105	4	WP V/O MC NON-ADDRESS, RED, WALL	WP75	0.0000	0.0000	0.2730	1.0920
	•		Peripheral Totals		0.1950		1.5120
			RUI Totals	0	0.0000		0.0000
			Address Totals	16 Addresses	0.0128		0.0160
* Additional Current included under "Device Addresses Used"				Total Standby	0.5538	Total Alarm	1.9980

	Stand	by	Standby	Alarm	Alarm
Battery Set #1 (Cabinet/Charger #1)	Curre	nt	Total	Current	Total
Select ALL Power Supplies on this battery set:					
4010es			0.5410		1.9820
		Sub Total	0.5410		1.9820
Additional Current Draws:					
RUI Connected Peripheral Devices 0	x 0.0035		= 0.0000	x 0.0035	= 0.0000
MAPNET/IDNet Device Addresses ordered / used 16	x 0.000800		= 0.0128	x 0.001000	= 0.0160
		Sub Total	0.5538		1.9980
Spare addressable point capacity 0%	0 x 0.0008		= 0.0000	x 0.001	= 0.0000
		Total	0.5538		1.9980
Standby Time = 24 Hrs	s x 0.5538		= 13.2912	Standby Ah	
Alarm Time = ${}$ 5 Min	0.08333 x	1.998	= 0.1665	Alarm Ah	
			13.4577		
Additional Spare Capacity =0%		+	0.0000		
			13.4577		
Battery Discharge Factor = 20%		+	2.6915		
Minimum Battery Required 2081—9275 1	18AH (2x)		16.1492		
Battery Supplied 2081-9275 1	18AH (2x)				

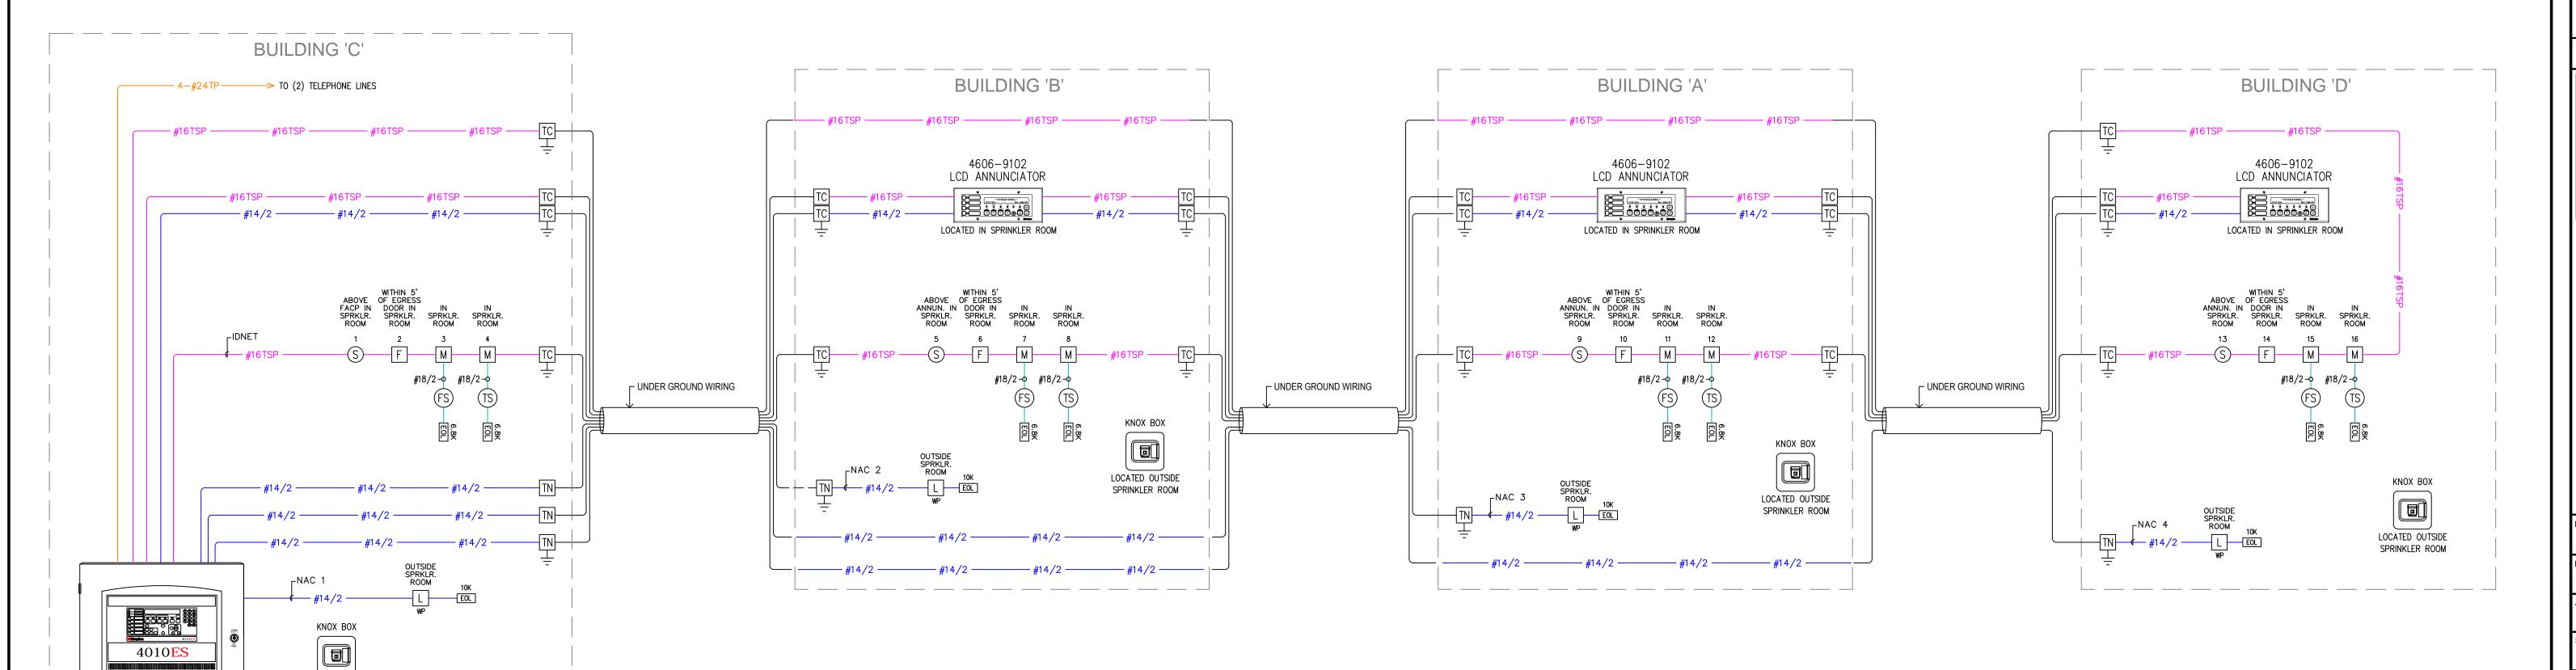

CERTIFIED IAN GREGORY #99614 FIRE ARISER DESIGNED BY: DRAWN BY: 2/22/13 APPROVED BY: SITE NUMBER: 147-420883 PROJECT NUMBER: 966410601 NOT TO SCALE