
RESERVED FOR CITY STAMP

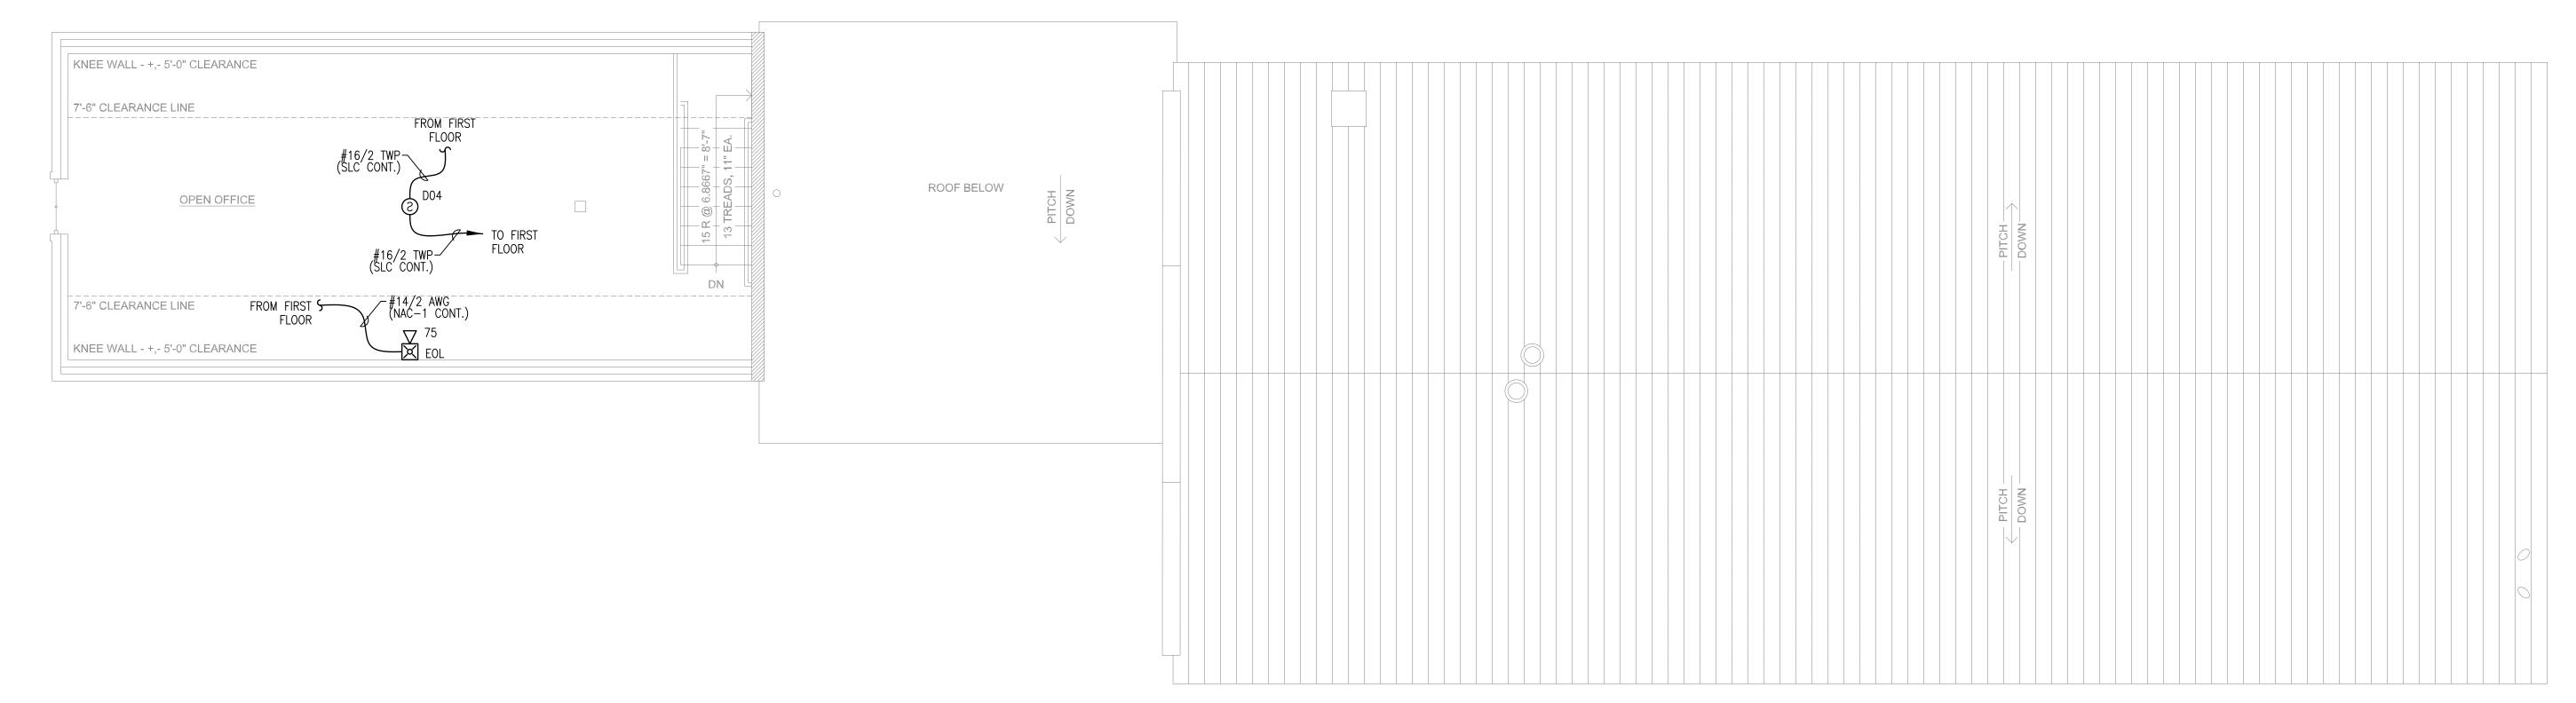

131

PORTLAND, MAINE 04101 SECOND FLOOR FIRE ALARM PLAN

JPB UNICAD JOB #16977 WAYNE B. HAWS NICET IV 90496 1/5/2017

SCALE 1/4"=1'-0" FA-3