


WALL TYPE NOTES


- 1.) INSTALL WATER RESISTANT GYPSUM WALLBOARD IN ALL RESTROOMS AND TOILET ROOM WALLS AND CEILINGS, AND AT ANY WALL WITH PLUMBING FIXTURES
- 2.) WHEN TWO ADJACENT WALL TYPES HAVE DIFFERING NUMBERS OF LAYERS OF GWB, THE FINISHED FACE OF GWB MUST FORM ONE CONTIUOUS PLANE, ADJUST STUD PLANE LOCATION AS REQUIRED TO ACHIEVE THE CONTINUOUS PLANE
- 3.) HOLD BOTTOM OF GWB UP 1/2" FROM CONCRETE, PROVIDE SEALANT AT JOINT.
- 4.) ALL WALL TYPES WITH AN INSULATION COMPONENT TO BE ACOUSTICALLY SEALED

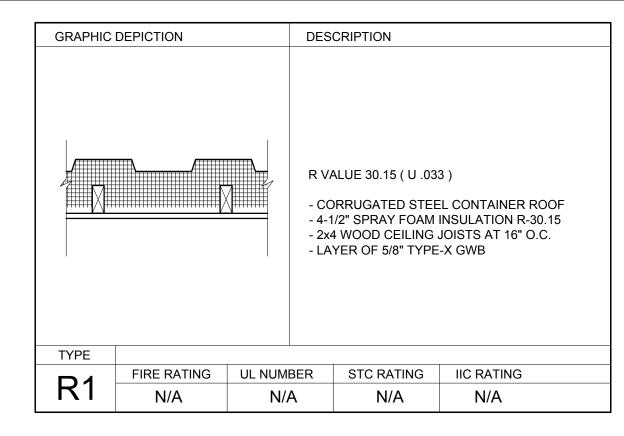

GRAPHIC	DEPICTION		DES	DESCRIPTION		
			R VALUE 20.1 (U .049) - 1-1/8" MARINE GRADE PLYWOOD CONTAINER FLOOR - STEEL JOISTS - 3" SPRAYFOAM INSULATION (FULL COVER ON ALL SIDES OF JOISTS) -CRUSHED STONE BASE, SEE STRUCTRAL AND CIVIL DRAWINGS			
TYPE						
- 4	FIRE RATING	UL NUMBER		STC RATING	IIC RATING	
	N/A	N/A	4	N/A	N/A	

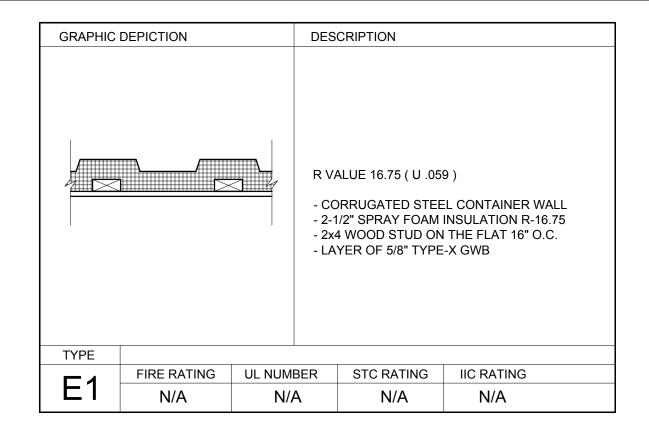

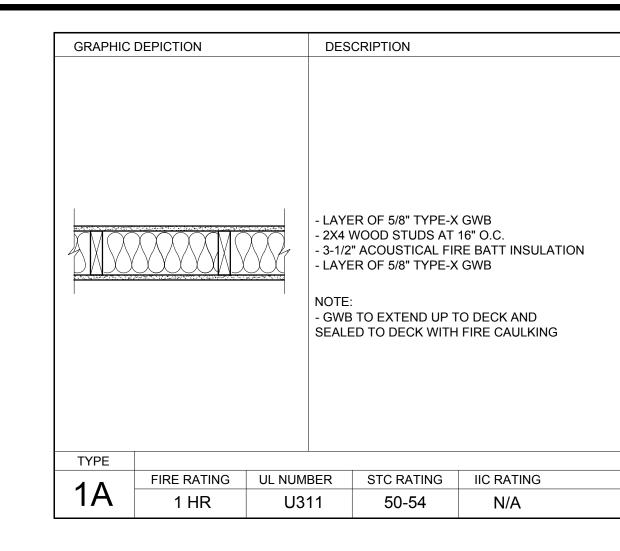

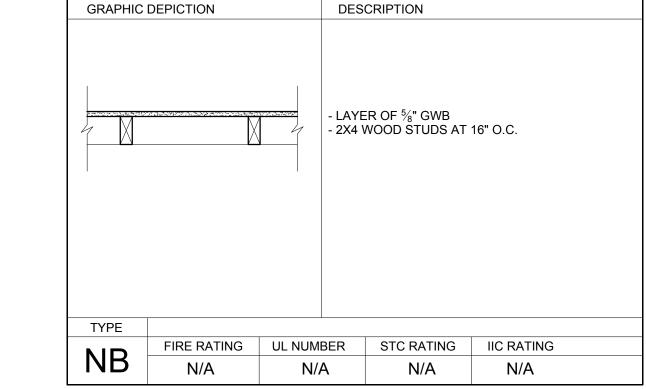



© 2016 RYAN SENATORI ARCHITECTURE

(人 (正

MASHINGTON PORTLAND, MAINE

RYAN SENATORE
ARCHITECTURE
565 CONGRESS STREET
PORTLAND, MAINE 04101
207-650-6414
senatorearchitecture.com

CONSULTANTS:

REVISIONS:

DATE: JULY 26, 2016

PROJECT No. 1626

DRAWN BY: RJS / RR

CHECKED BY: RJS

CHECKED BY: RJS

SCALE: AS NOTED

SHEET TITLE:
WALL TYPES

ASSEMBLIES

A0-1