



WALL TYPE NOTES


- 1.) INSTALL WATER RESISTANT GYPSUM WALLBOARD IN ALL RESTROOMS AND TOILET ROOM WALLS AND CEILINGS, AND AT ANY WALL WITH PLUMBING FIXTURES
- 2.) WHEN TWO ADJACENT WALL TYPES HAVE DIFFERING NUMBERS OF LAYERS OF GWB, THE FINISHED FACE OF GWB MUST FORM ONE CONTIUOUS PLANE, ADJUST STUD PLANE LOCATION AS REQUIRED TO ACHIEVE THE CONTINUOUS PLANE
- 3.) HOLD BOTTOM OF GWB UP 1/2" FROM CONCRETE, PROVIDE SEALANT AT JOINT.
- 4.) ALL WALL TYPES WITH AN INSULATION COMPONENT TO BE ACOUSTICALLY SEALED

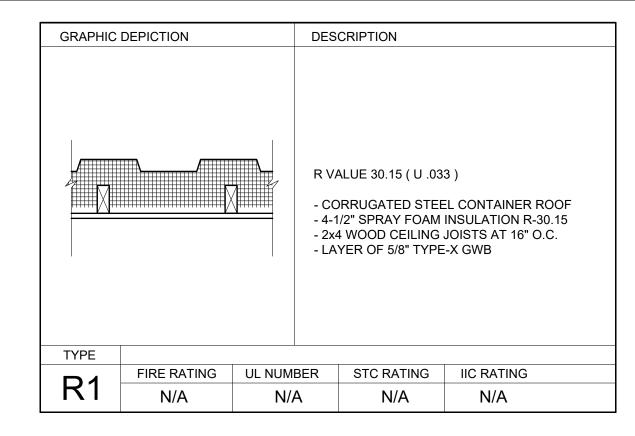


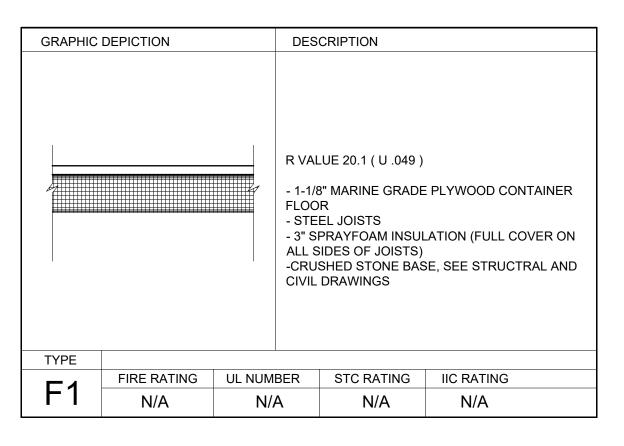


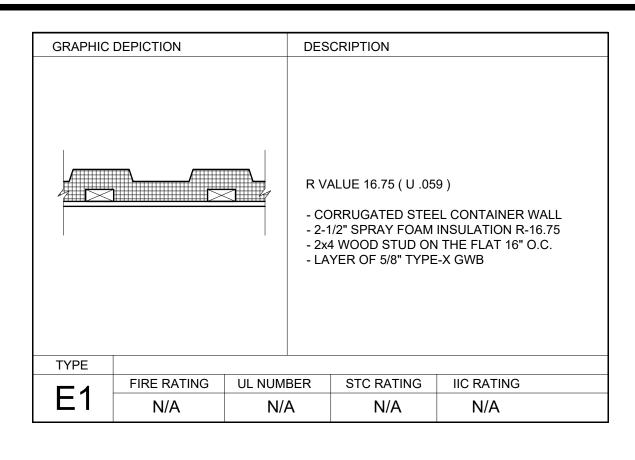

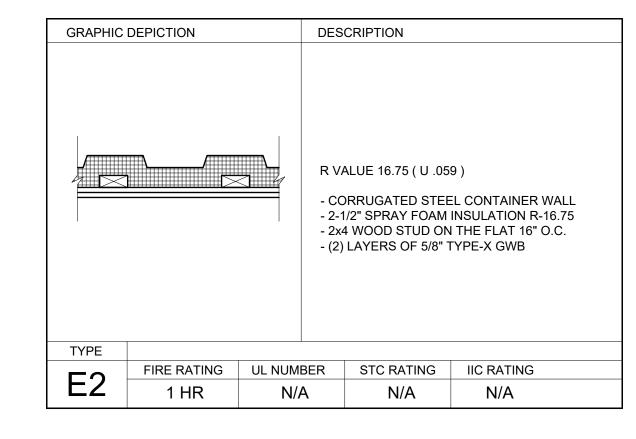

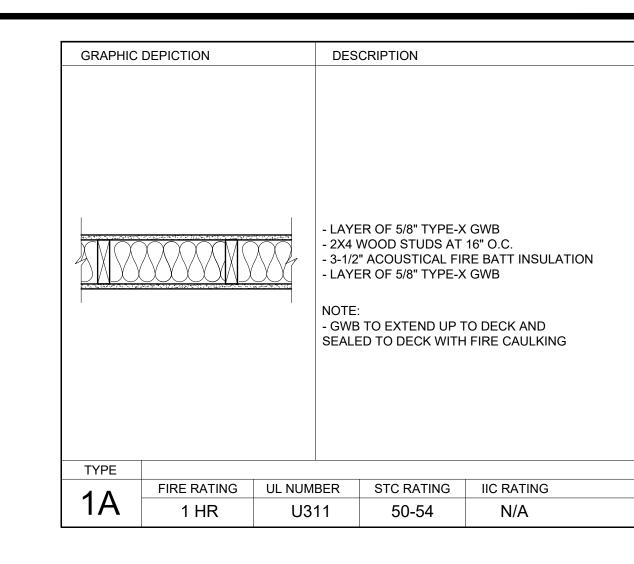

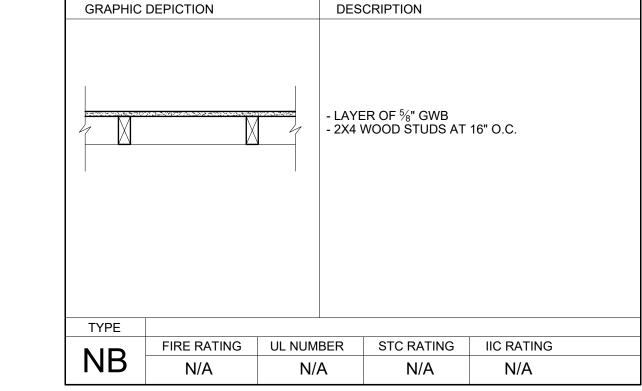

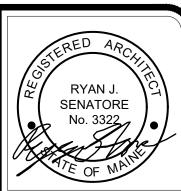

© 2017 RYAN SENATOR ARCHITECTURE

TON AVE.

WASHINGTON PORTLAND, MAINE

RYAN SENATORE
ARCHITECTURE
565 CONGRESS STREET
PORTLAND, MAINE 04101
207-650-6414
senatorearchitecture.com

CONSULTANTS:

REVISIONS:

DATE: JULY 22, 2017
PROJECT No. 1620
DRAWN BY: RJS / RR

SCALE: AS NOTED

SHEET TITLE:
WALL TYPES

ASSEMBLIES

A0-1