RENOVATION OF EXISTING SINGLE-FAMILY HOUSE CURRENTLY CONTAINING (1) APARTMENT UNITS ON TWO FLOOR LEVELS.

NEW KITCHEN AND BATHROOM WILL BE INSTALLED, WITH ALL NEW PLUMBING FIXTURES, CABINETRY AND COUNTERTOPS. MINOR RECONFIGURATION OF INTERIOR WALLS WILL BE DONE TO IMPROVE THE LAYOUT. EXISTING ELECTRICAL SERVICE, WIRING AND DEVICES WILL BE REPLACED IN THEIR ENTIRETY. ALL LIGHT FIXTURES WILL BE PROVIDED NEW


ONE EXISTING INTERNAL STAIRWAYS WILL REMAIN IN USE. THE EXISTING FRONT PORCH WILL

ALL WINDOWS WILL BE REPLACED, AND SIZES AND OPERATION WILL BE CHECKED TO ENSURE THAT ALL BEDROOMS AND LIVING SPACES ARE PROVIDED WITH AT LEAST (1) EMERGENCY ESCAPE WINDOW.

EXISTING SIDING IS TO BE REMOVED AND REPLACED AS NOTED ON THE BUILDING ELEVATIONS. BLOWN-IN CELLULOSE INSULATION WILL BE INSTALLED IN ALL EXTERIOR WALLS, EXISTING ROOF INSULATION WILL REMAIN IN PLACE OR REPLACED IN KIND.

ELLA HOUSING

77 CONGRESS STREET - REAR

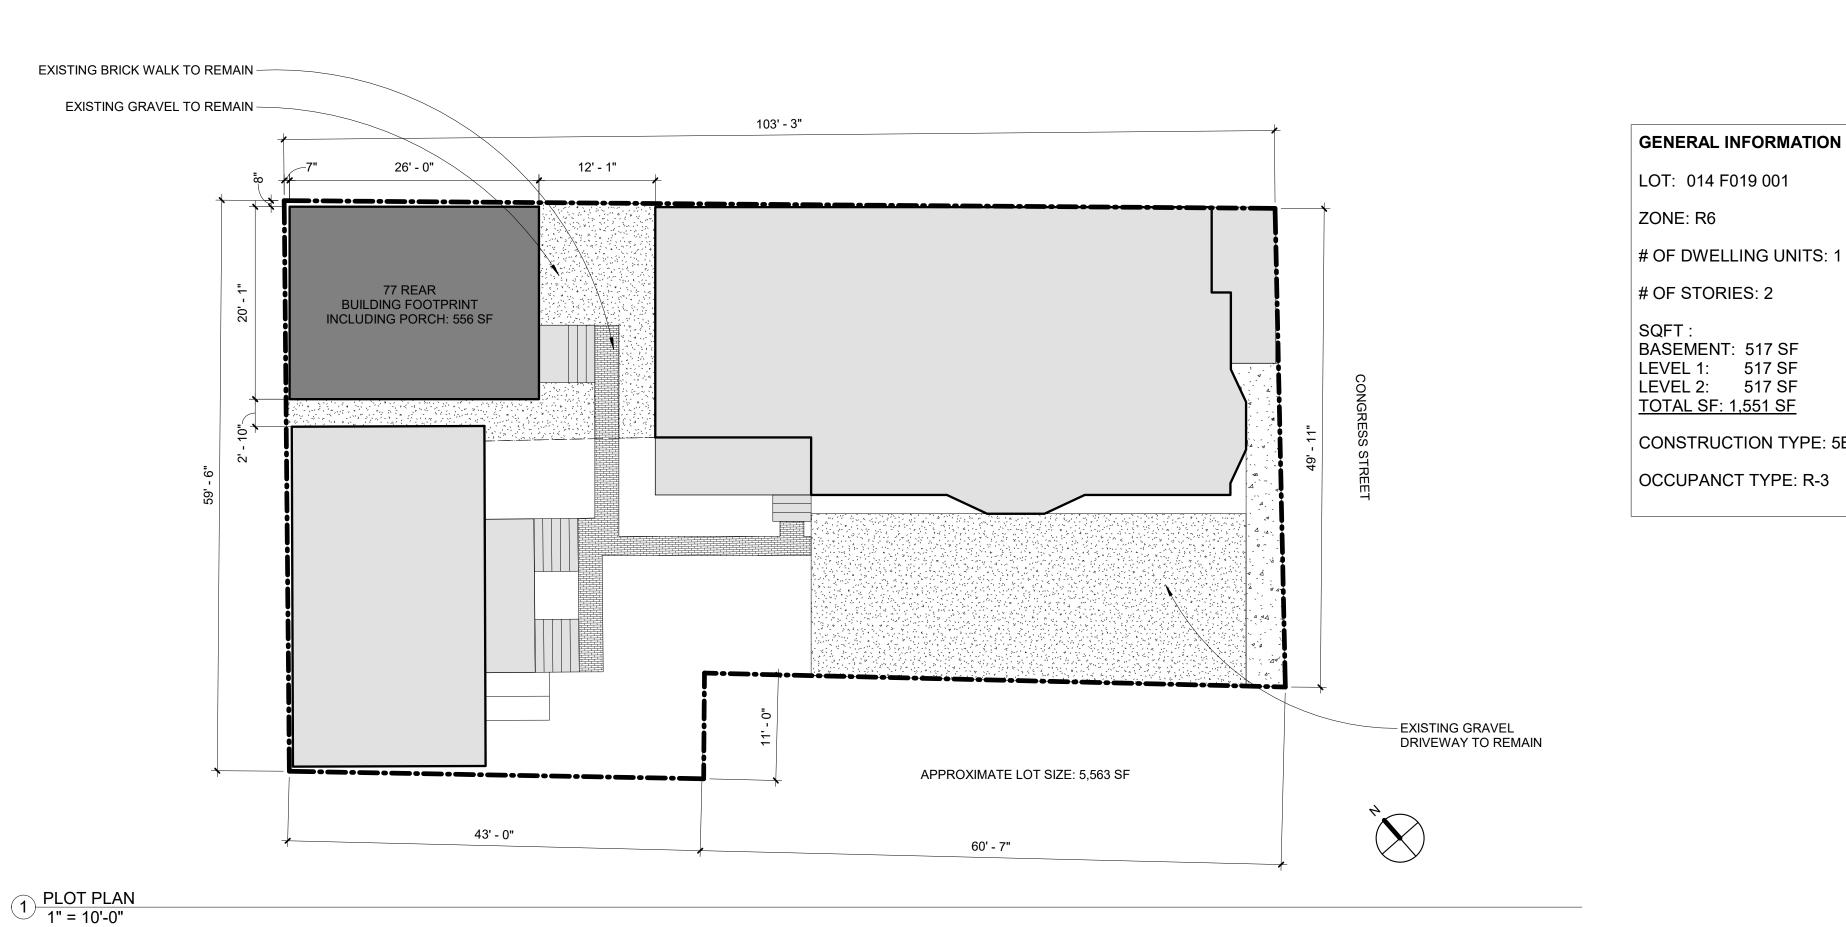

N	SYMB	OL LE
	1_ SIM	– DETAIL NUI BUILDING S – DRAWING I
1	SIM A101	– DETAIL NUI CALL OUT – DRAWING 1
	£	CENTERLIN
	101	DOOR TAG
	•	ELEVATION
5B	Ref 1 1 A101 1 2 Ref	ELEVATION
	Ref View Name	ELEVATION

SYMBOL LEGEND		
1_SIM_A101	DETAIL NUMBERBUILDING SECTIONDRAWING NUMBER	
SIM A101	DETAIL NUMBERCALL OUT✓ DRAWING NUMBER	
Ą	CENTERLINE	
101	DOOR TAG	
+	ELEVATION INDICATOR	
Ref 1 A101 1 jag Ref	ELEVATION TAG	
Ref View Name	ELEVATION TAG	
	NORTH ARROW	
<u> </u>	REVISION	
Room name	ROOM TAG WITH NUMBER	
0	STRUCTURAL GRID BUBBLE	
<u>(1i)</u>	WALL TAG	
(1t)	WINDOW TAG	

NUMBER	SHEET TITLE
B-G001	COVER SHEET
B-D101	DEMOLITION PLANS
B-A101	FLOOR PLANS
B-A201	EXTERIOR ELEVATIONS
B-A301	BUILDING SECTIONS
B-A601	SCHEDULES
B-A501	INTERIOR ELEVATIONS
B-A502	FINISH PLANS & SCHEDULE
B-E101	ELECTRICAL PLANS
A-E201	ELECTRICAL GENERAL NOTES, LEGEND & FIXTURE SCHEDULE
S0.1	STRUCTURAL - GENERAL NOTES
S1.0	STRUCTURAL - FOUNDATION AND FRAMING PLANS
S2.0	STRUCTURAL - SECTIONS AND DETAILS

CONSULTANTS:

REVISIONS:

ISSUED FOR

PERMITTING ISSUED: 10/13/2017 PROJECT No:

DRAWN BY: CHECKED BY: COVER SHEET

B-G001