

3 <u>LEVEL 2 - RCP</u> 1/4" = 1'-0"

LIGHTING SYMBOL LEGEND			
	SURFACE MOUNTED LIGHT FIXTURE		4' SURFACE MOUNTED FLUORESCENT LIGHT FIXTURE
0	RECESSED LIGHT FIXTURE		UNDER-CABINET LIGHT FIXTURE
\bigoplus	WALL MOUNTED LIGHT FIXTURE	X	PENDANT LIGHT FIXTURE
#	EXHAUST FAN/LIGHT		WALL MOUNTED STRIP LIGHT
	GARAGE DOOR OPENER		CEILING FAN/LIGHT

FINISH LEGEND

WALL


W1 PLASTER W2 PLASTER + PAINTED WALLPAPER
W3 GYPSUM WALL BOARD

W4 PAINTED WOOD WAINSCOTT W5 CERAMIC TILE


CEILING C1 PLASTER
C2 GYPSUM WALL BOARD ON STRAPPING
C3 GYPSUM WALL BOARD ON FURRING & SOUND ISOLATION CLIPS

FINISH LEGEND FLOOR

F1 CLEAR FINISH HARDWOOD
F2 PAINTED HARDWOOD
F3 CLEAR FINISH SOFTWOOD
F4 PAINTED SOFTWOOD
F5 PORCELAIN TILE
F6 CARPET
F7 LAMINATE
F8 CONCRETE

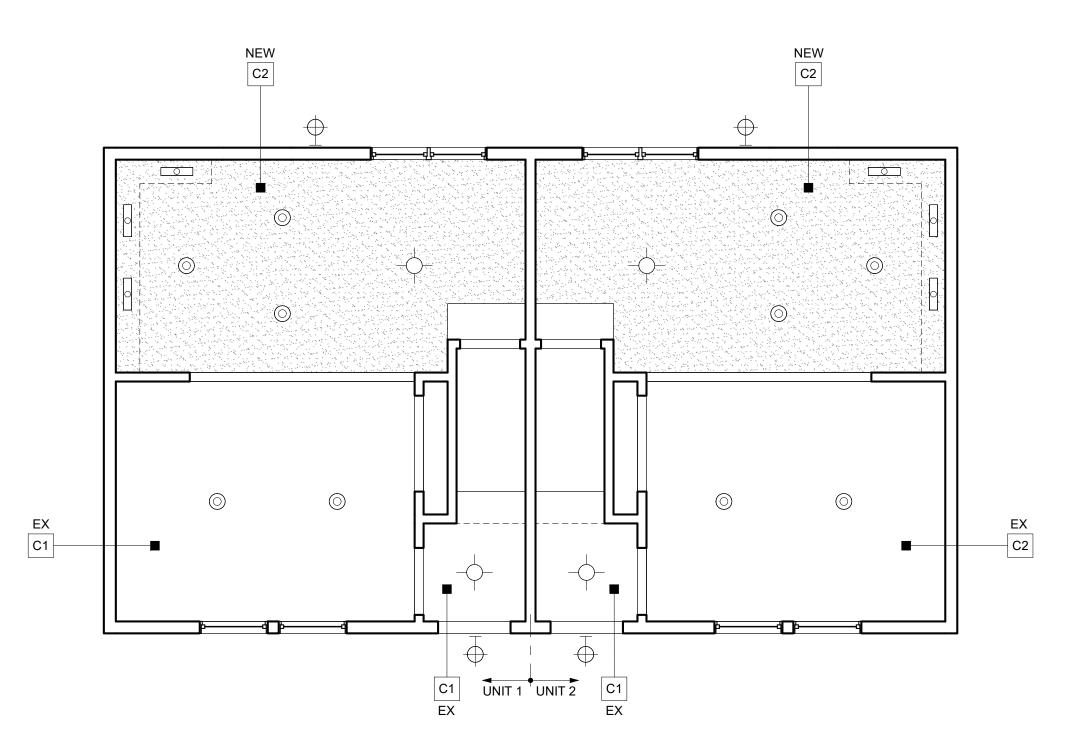

2 LEVEL 1 - RCP 1/4" = 1'-0"

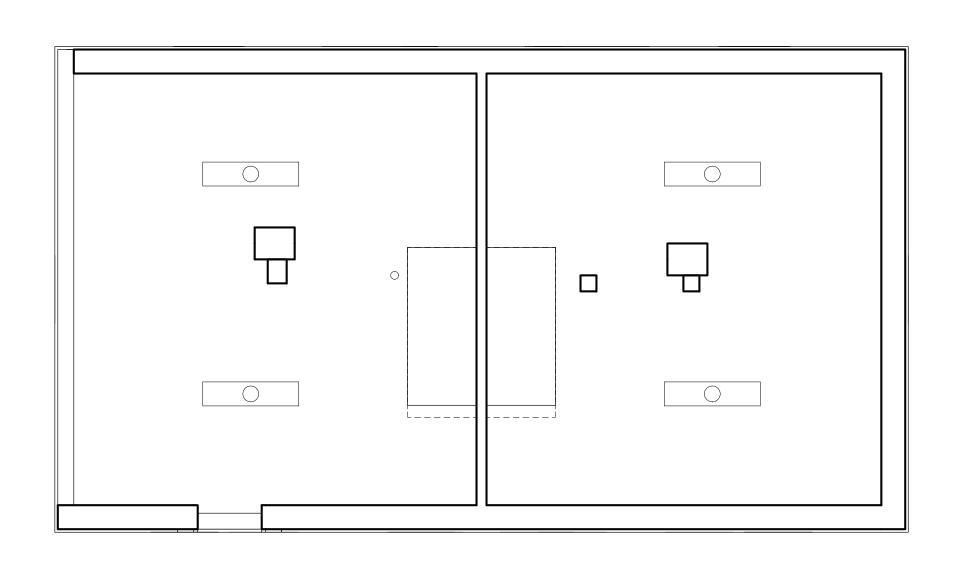

1 BASEMENT REFLECTED CEILING PLAN 1/4" = 1'-0"

CONGRES 79 HOUSING

CONSULTANTS:

REVISIONS: No. Name Date

ISSUED FOR PERMITTING ISSUED: 10/13/2017

PROJECT No: DRAWN BY: CHECKED BY: SHEET TITLE: CEILING PLANS

C-A111