


AREAS IN GRAY NOT INCLUDED IN THIS PERMIT SECOND FLOOR LIGHTING PLAN

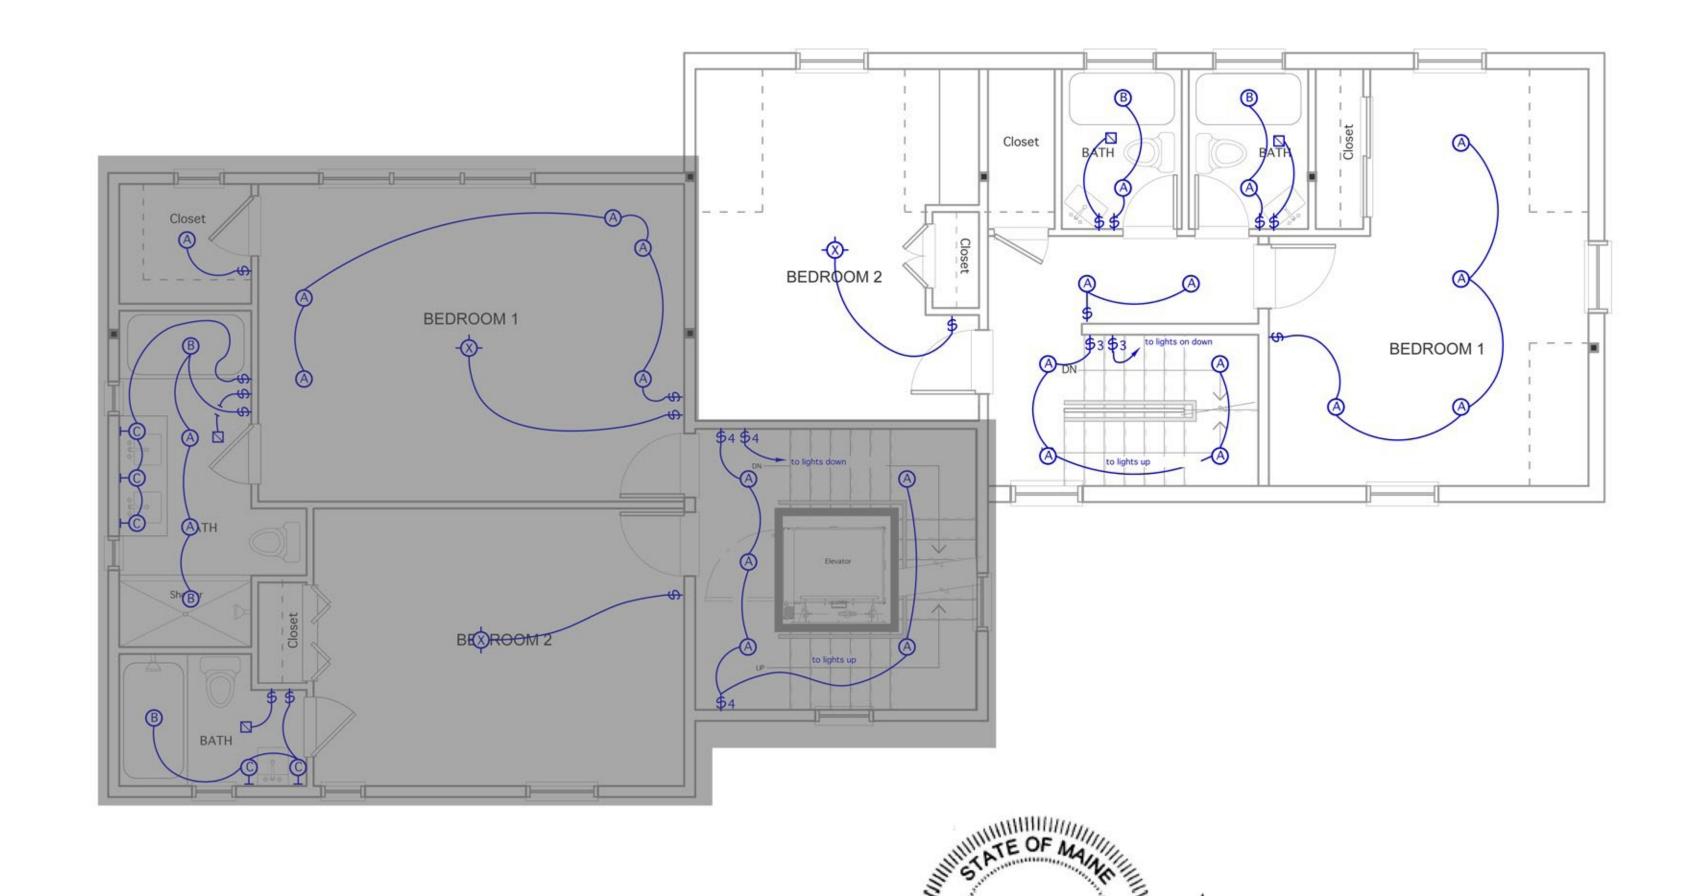

7/19/17 STAMP FOR STRUCTURE ONLY



Trademark Inc.
FOR PERMIT 07/12/17

33 Turner Road
Portland, ME
Scale: 1/4" = 1'-0"