



Calculation Summary					
Label	Avg	Max	Min	Avg/Min	Max/Min
site	0.89	5.0	0.0	N.A.	N.A.

Luminaire Schedule (note fixture catalogue numbers are not complete)

Type	Symbol	Qty	Lumens	LLF	Lum. Watts	Description
W1	□	4	726	0.800	10.8	AEL12-10W 3000K
LS	□	7	30	0.900	4.95	SS-LED-e102-A-0-DEGREES
B	○	11	506	0.600	18.1	B30-8R-15L3K reduced output
TR	○	16	176	0.900	2.56	MM-LED-e72-MFL-12-C
EX	○	3	6220	0.900	109	Holophane Eastern city
R	○	9	676	0.600	8.42	FLC3D-RO-700L-120-L11-T reduced output
LP	□	7	3221	0.900	55.8	VP-S-24NB-55-3K-T4-BLC
LP2	□	1	4816	0.900	55.8	VP-S-24NB-55-3K-T2
EXh	○	3	8937	1.000	153	Holophane comm city


NOTES:

- 1) EXACT MOUNTING DETAILS TO BE DETERMINED AT JOBSITE
- 2) CALCULATIONS MAY SHOW THE EFFECT OF SHADOWING CAUSES WITHIN THE CALCULATED SPACE OR IN THE SITE AREA
- 3) READINGS SHOWN ARE INITIAL HORIZONTAL FOOTCANDLES UNLESS OTHERWISE INDICATED.
- 4) THIS CALCULATION IS BASED ON LIMITED INFORMATION SUPPLIED BY SWANNEY LIGHTING ASSOCIATES AND STANDARD ASSUMPTIONS
- 5) CONFORMANCE TO CODES AND OTHER LOCAL REQUIREMENTS ARE THE RESPONSIBILITY OF THE OWNER AND/OR THE OWNER'S PLANNER
- 6) THIS LAYOUT DRAWING MUST BE COORDINATED WITH THE SITE PLANNER TO ENSURE CORRECT FIXTURE ORIENTATION.
- 7) CHECK GRAPHIC SCALE. DOCUMENTS PRINTED OR PLOTTED FROM ELECTRONIC FILES MAY OCCUR AT OTHER THAN THE DESIRED OR ASSUMED GRAPHIC SCALES. IT IS THE RESPONSIBILITY OF THE RECIPIENT TO VERIFY THAT THE PRINTED OR PLOTTED-TO-SCALE DRAWING IS PRINTED TO SCALE.

DATE of APPROVAL: October 4, 2017
PLANNER: Caitlin Cameron
PROJECT NO.: 2017-180

site 10-4-17-A

site 10-4-17-A

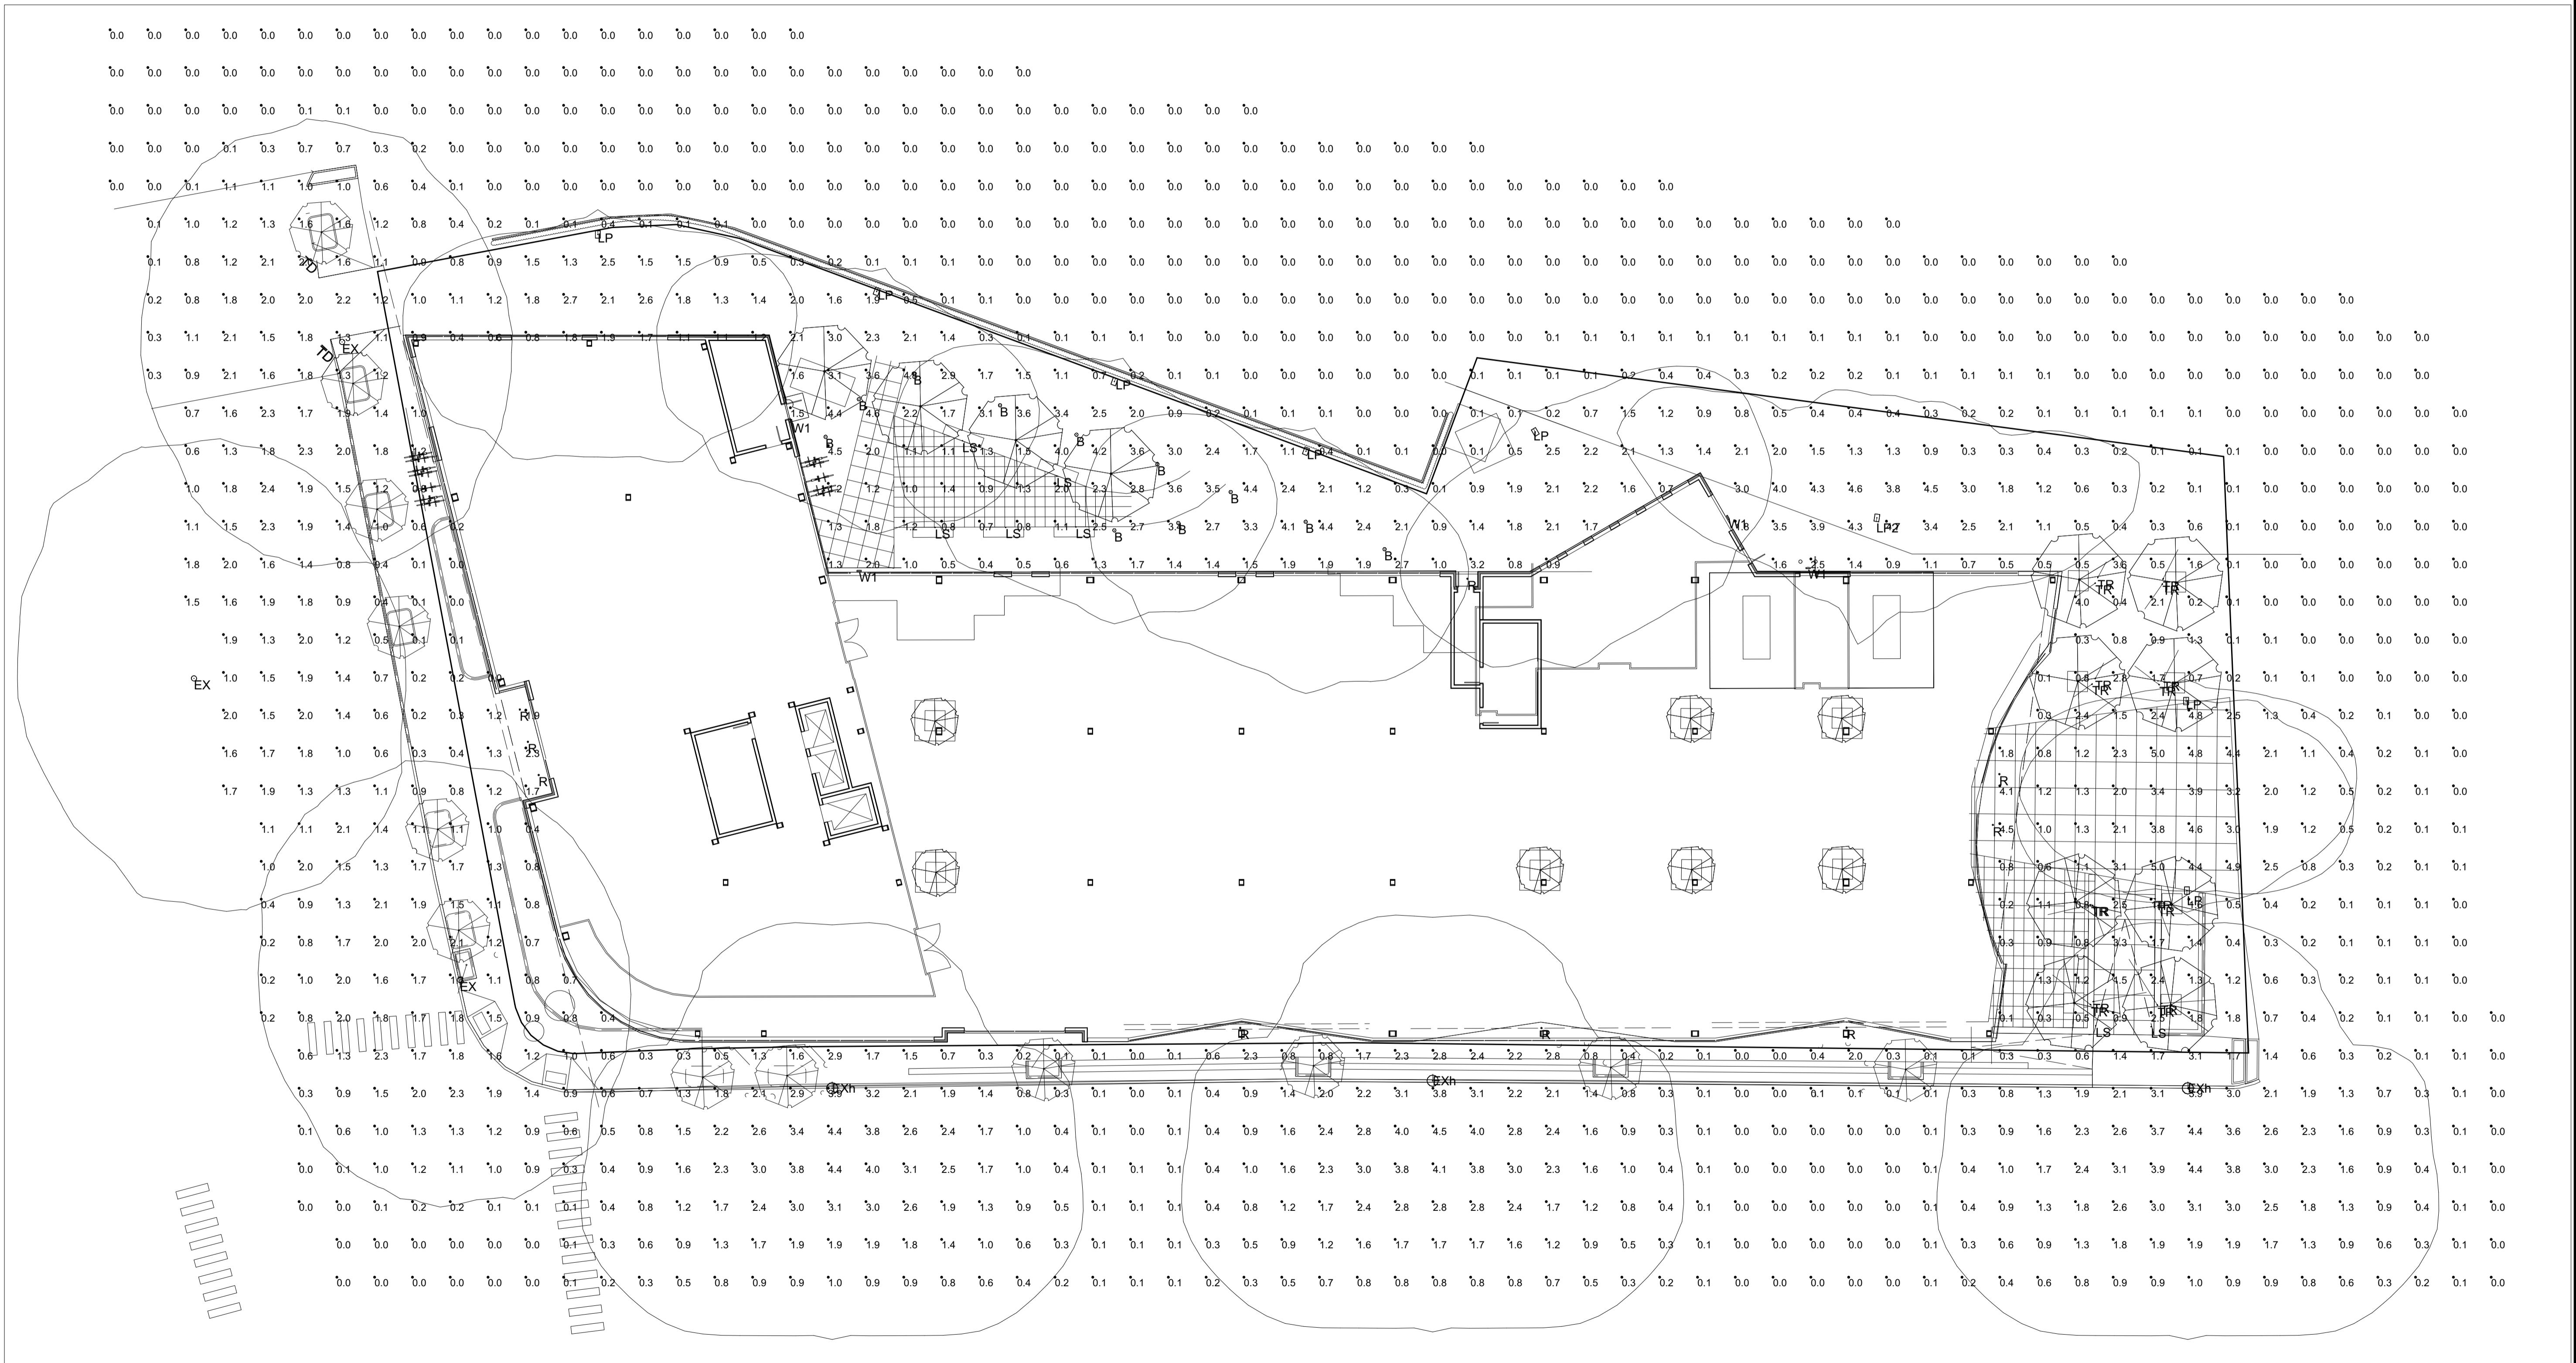

WEX
PORTLAND, ME
SITE LIGHTING LAYOUT

TITLE

STANTEC,
MOHR & SEREDIN

SCALE NOT TO SCALE

GENERATED FOR



SLA

SWANEY LIGHTING
ASSOCIATES, INC.

NOTICE: THIS DRAWING IS THE EXCLUSIVE PROPERTY OF SWANEY LIGHTING ASSOCIATES, INC. AND IS PROVIDED TO THE CONTRACTOR FOR THE USE IN THE PERFORMANCE OF THE CONTRACT. IT IS THE PROPERTY OF SWANEY LIGHTING ASSOCIATES, INC. AND IS NOT TO BE COMMUNICATED, COPIED, DISCLOSED OR USED IN WHOLE OR IN PART, EXCEPT AS EXPRESSLY AUTHORIZED BY SWANEY LIGHTING ASSOCIATES, INC. THIS DRAWING IS PROVIDED FOR THE USE OF THE CONTRACTOR ONLY AND IS NOT TO BE USED FOR ANY OTHER PURPOSE. THE CONTRACTOR AGREES TO HOLD SWANEY LIGHTING ASSOCIATES, INC. HARMLESS FROM ALL CLAIMS, DEMANDS, COSTS, EXPENSES, LIABILITIES, OR DAMAGES ARISING OUT OF THE CONTRACT, WHETHER IN CONTRACT, TORT, OR OTHERWISE, WHICH ARE CAUSED BY THE CONTRACTOR'S NEGLIGENCE, CARELESSNESS, OR GROSS NEGLIGENCE, OR BY THE CONTRACTOR'S BREACH OF THIS AGREEMENT. THE CONTRACTOR AGREES TO INDEMNIFY SWANEY LIGHTING ASSOCIATES, INC. FOR ANY LIABILITY, LOSS, OR DAMAGE WHICH SWANEY LIGHTING ASSOCIATES, INC. MAY SUFFER AS A RESULT OF THE CONTRACTOR'S VIOLATION OF THIS AGREEMENT. THIS DRAWING IS PROVIDED FOR THE USE OF THE CONTRACTOR ONLY AND IS NOT TO BE USED FOR ANY OTHER PURPOSE. THE CONTRACTOR AGREES TO HOLD SWANEY LIGHTING ASSOCIATES, INC. HARMLESS FROM ALL CLAIMS, DEMANDS, COSTS, EXPENSES, LIABILITIES, OR DAMAGES ARISING OUT OF THE CONTRACT, WHETHER IN CONTRACT, TORT, OR OTHERWISE, WHICH ARE CAUSED BY THE CONTRACTOR'S NEGLIGENCE, CARELESSNESS, OR GROSS NEGLIGENCE, OR BY THE CONTRACTOR'S BREACH OF THIS AGREEMENT. THE CONTRACTOR AGREES TO INDEMNIFY SWANEY LIGHTING ASSOCIATES, INC. FOR ANY LIABILITY, LOSS, OR DAMAGE WHICH SWANEY LIGHTING ASSOCIATES, INC. MAY SUFFER AS A RESULT OF THE CONTRACTOR'S VIOLATION OF THIS AGREEMENT.