

PLUMBING LEGEND

AND DETAILS

sheet number:

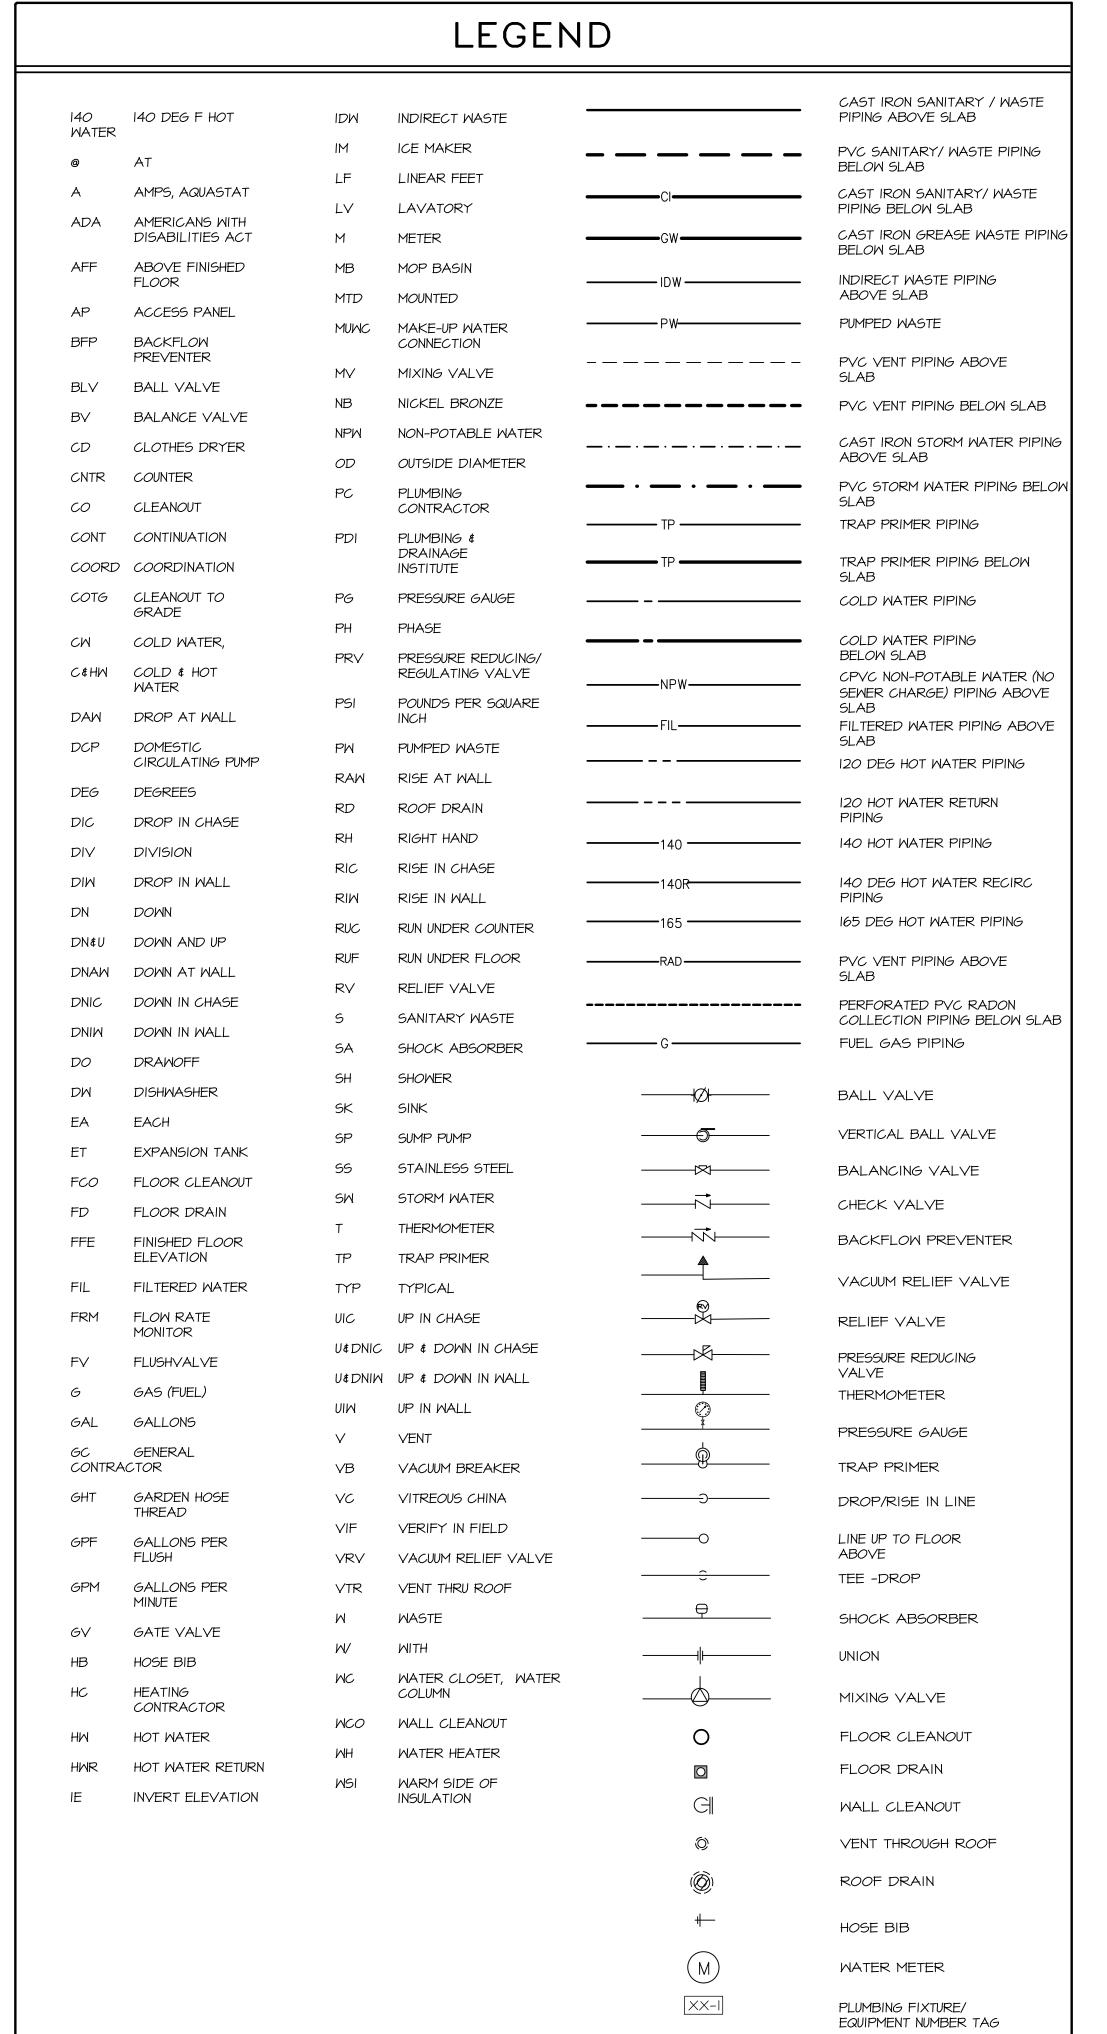

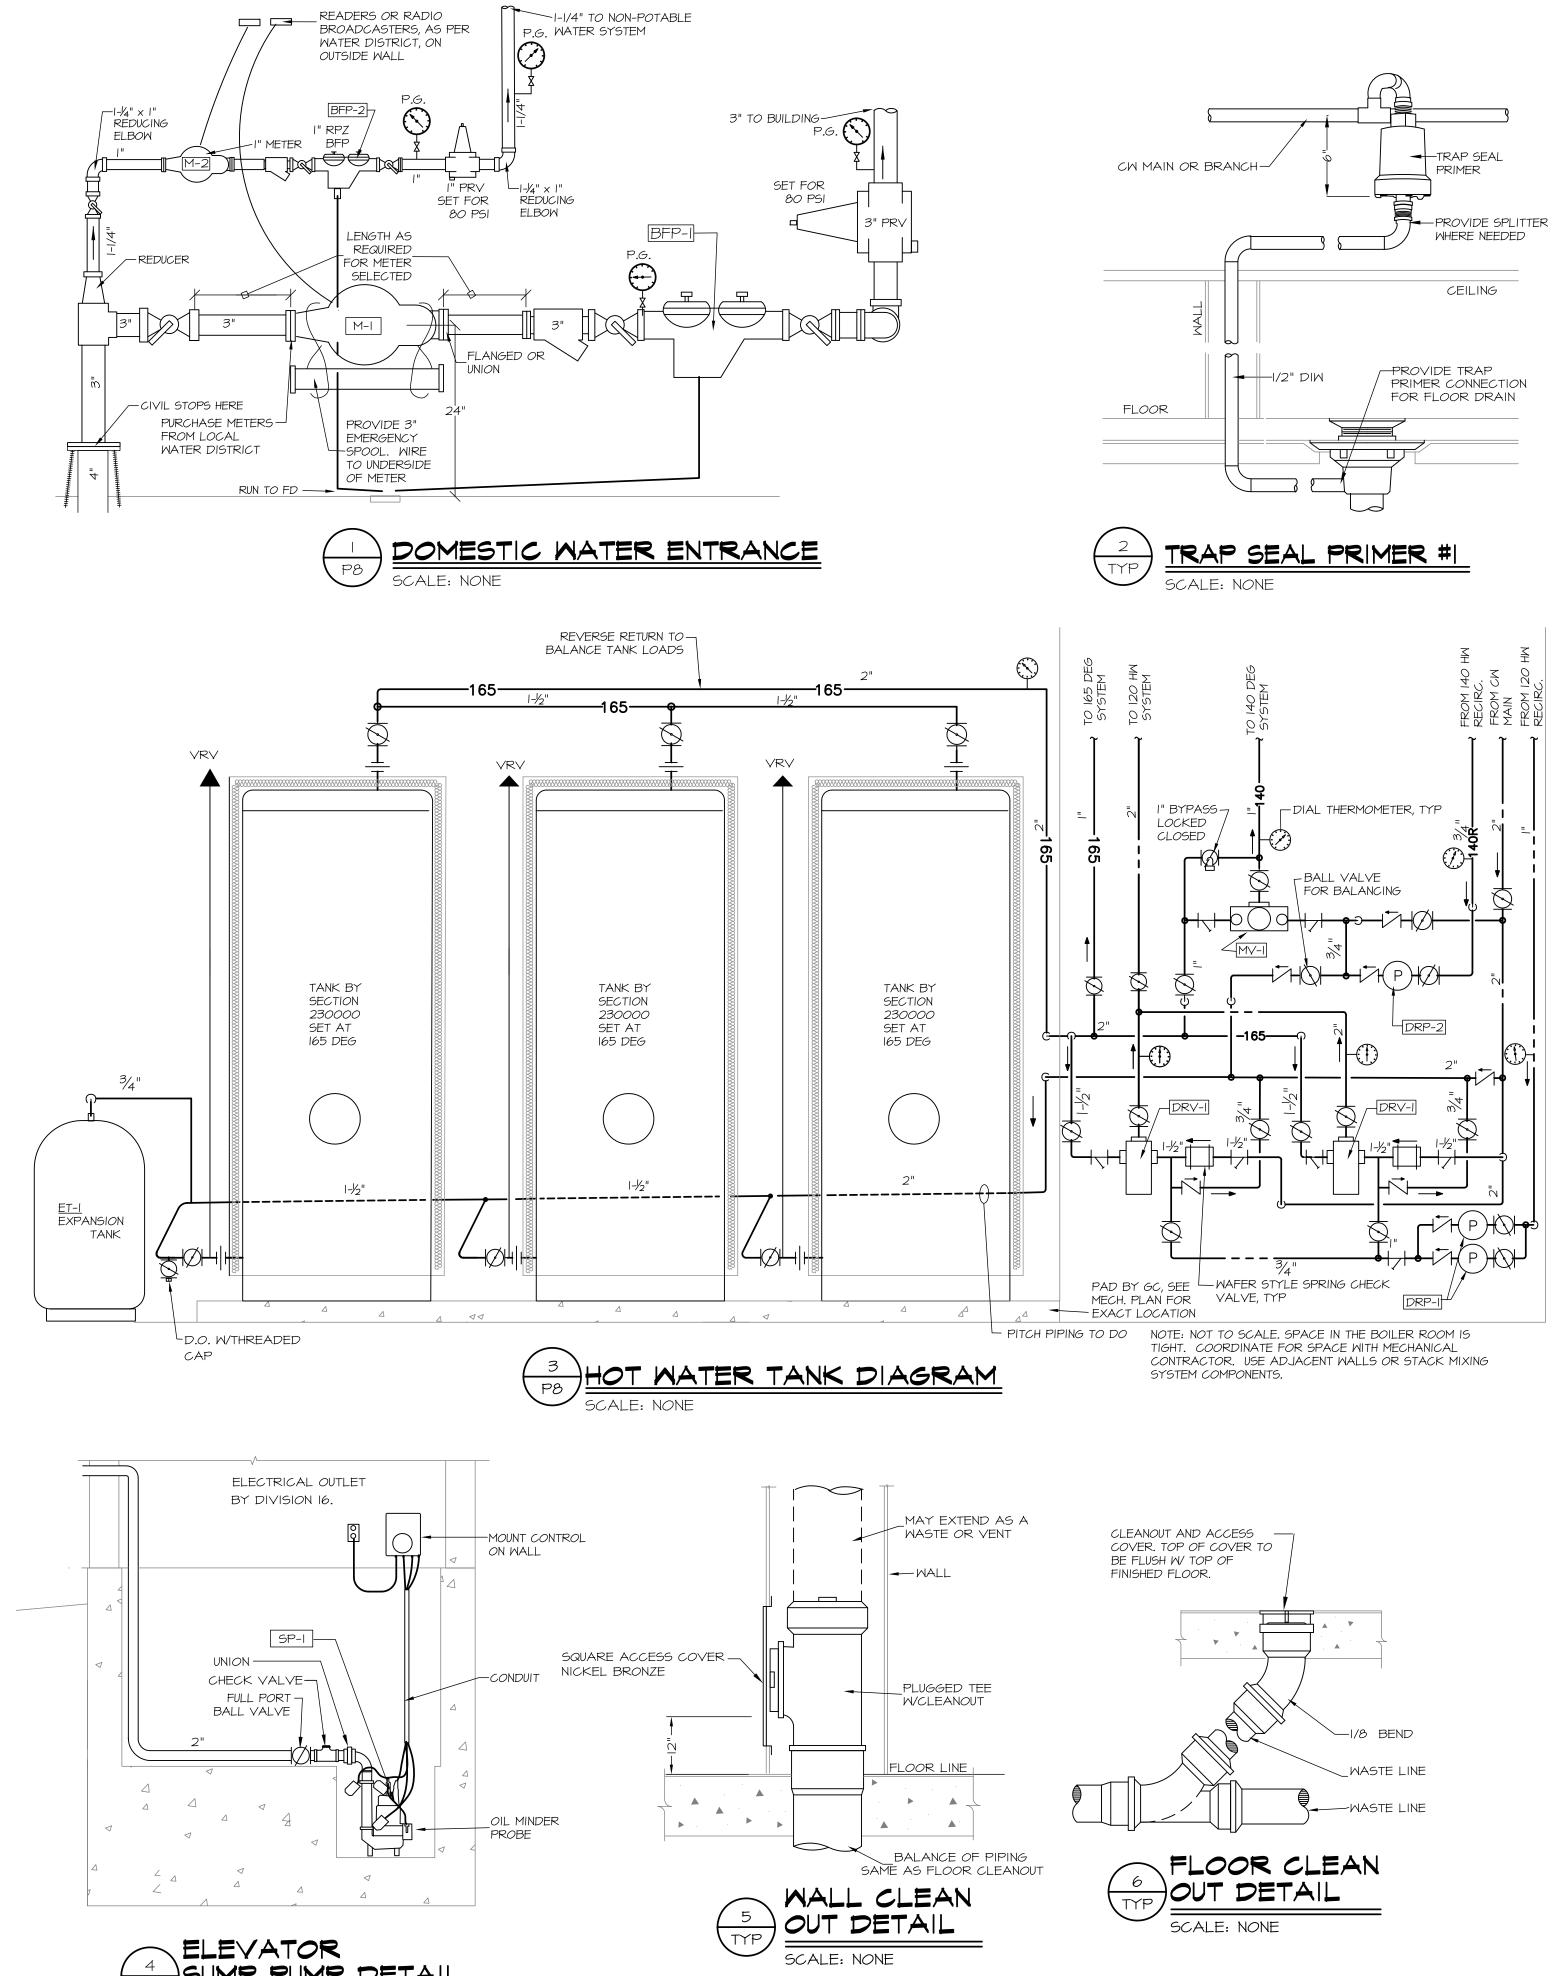

SCALE: NONE



ROYAL RIVER CENTER, UNIT 10B

(207) 846-1441

© COPYRIGHT 2016 M.S.E. Proj. 1632