TO THE ATTENTION OF THE DESIGN PROFESSIONAL BEFORE PROCEEDING.

2. SIGNIFICANT DESIGN ALTERATIONS, ADDITIONS, OR DISCREPANCIES SHALL BE BROUGHT

B. THE ELECTRICAL CONTRACTOR IS RESPONSIBLE FOR COORDINATING THE ELECTRICAL SYSTEM INSTALLATION WITH ALL TRADES INCLUDING MECHANICAL, ARCHITECTURAL, STRUCTURAL, AND PLUMBING.

4. ELECTRICAL WORK SHALL CONFORM TO ALL LOCAL, STATE, AND FEDERAL STANDARDS, CODES, AND GUIDELINES.

5. THE ELECTRICAL CONTRACTOR IS RESPONSIBLE FOR VERIFYING THAT SERVICE SIZE IS ADEQUATE.

6. ALL PENETRATIONS THROUGH FIRE-RESISTANT RATED WALL, FLOOR/CEILING AND ROOF/CEILING ASSEMBLIES SHALL BE MADE IN ACCORDANCE WITH AN APPROVED U.L. LISTED THRU-PENETRATION ASSEMBLY AND SUCH ASSEMBLY IS THE RESPONSIBILITY OF THE ELECTRICAL CONTRACTOR..

7. EXTERIOR LIGHTING TO BE PROVIDED WITH A PHOTOCELL AND TIMER.

8. EXTERIOR LIGHT FIXTURES ARE INDICATED ON THE SITE LIGHTING PLAN LP-1.

9. ALL EXPOSED WIRING SYSTEMS ARE TO BE RUN IN E.M.T. OR RIGID CONDUITS RUN TIGHT TO THE FLOOR DECK OR CONTINUOUSLY ALONG OTHER STRUCTURAL COMPONENTS.


LIGHTING NOTES SYMBOL LEGEND SYMBOL LEGEND 10. COLOR FOR ELECTRICAL COVER PLATES AND COMPONENTS TO MATCH THE BUILDING NOTE: REFER TO AC HOTELS BY MARRIOTT - INTERIOR PRODUCT & FINISH NOTE: REFER TO AC HOTELS BY MARRIOTT - INTERIOR PRODUCT & FINISH SPECIFICATIONS FOR COMPLETE LIGHT FIXTURE DESCRIPTIONS AND SPECIFICATIONS. SPECIFICATIONS FOR COMPLETE LIGHT FIXTURE DESCRIPTIONS AND SPECIFICATIONS. COLOR SCHEME. SYMBOL DESIGNATION DESCRIPTION SYMBOL DESIGNATION DESCRIPTION 1. PHOTOCELL TO BE LOCATED ABOVE TIMER CLOCK ON ROOF. SURFACE MTD. 12. AT SUSPENDED ACOUSTICAL CEILING TILE AREAS, FIXTURES ARE TO BE CENTERED IN EXTERIOR WALL MOUNTED LIGHT LIGHT FIXTURE EXTERIOR UTILITY LIGHT FIXTURE WITH CRACK-RESISTANT RECESSED 2x2 LIGHT FIXTURE 13. FLOOR/CEILING ASSEMBLIES HAVE A FIRE RATING WHERE INDICATED ON THE GLOBE AND PROTECTIVE CAGE. REFLECTED CEILING PLAN. TC TIMER CLOCK RECESSED 2x4 LIGHT FIXTURE 14. ELECTRICAL CONTRACTOR IS RESPONSIBLE FOR SUPPLYING CONDUITS TO THE PC PHOTOCELL TO BE LOCATED ON ROOF BUILDING FOR TELEPHONE FIBER OPTIC AND CABLE SERVICES. DC DIMMER CONTROL IN ADMIN. WORK ROOM RECESSED DECORATIVE FIXTURE 15. AN EMERGENCY BACKUP GAS GENERATOR SHALL BE PROVIDED TO RUN ALL PUBLIC REMOTE LIGHTING CONTROL IN ADMIN. WORK ROOM LIGHTING, ELEVATOR AND ALL OTHER EMERGENCY CIRCUITS AS REQUIRED BY CODE. 00 RECESSED-DECORATIVE FIXTURE SINGLE-POLE SWITCH MOUNTED 42" A.F.F. TO CENTER 16. ELECTRICAL CONTRACTOR TO PROVIDE FIXTURE SUBMITTALS AND CIRCUITED DRAWING, 0 SURFACE MOUNTED FIXTURE INCLUDING PANEL DIAGRAMS FOR APPROVAL PRIOR TO INSTALLATION. THREE-WAY SWITCH MOUNTED 42" A.F.F. TO CENTER SINGLE-POLE SWITCH - WITH MOTION/INFARED SENSOR-MOUNTED 42" A.F.F TO CENTER RECESSED 7. MOUNTING HEIGHTS INDICATED ON PLANS ARE TO THE CENTER OF FIXTURE. DIMMER SWITCH MOUNTED 42" A.F.F. TO CENTER WALL SCONCE - CENTER ON WALL AT 5'-9" AFF TO CENTER OF FIXTURE 18. LIGHT SWITCH AND OUTLET MOUNTING HEIGHTS ARE SHOWN ON E2.01 UNLESS NOTED OTHERWISE ON THE PLANS. SINGLE-POLE SWITCH WITH "IN-USE" INDICATOR MOUNTED 42" A.F.F. TO CENTER FAN/LIGHT UNIT SINGLE-POLE SWITCH WITH KEY OPERATION PENDANT LIGHT -SEE PLANS FOR SIZE

CEILING-MOUNTED OCCUPANCY SENSOR

EMERGENCY LIGHT W/ REMOTE BATTERY PACK

EXTERIOR EMERGENCY LIGHT W/ REMOTE BATTERY PACK

00

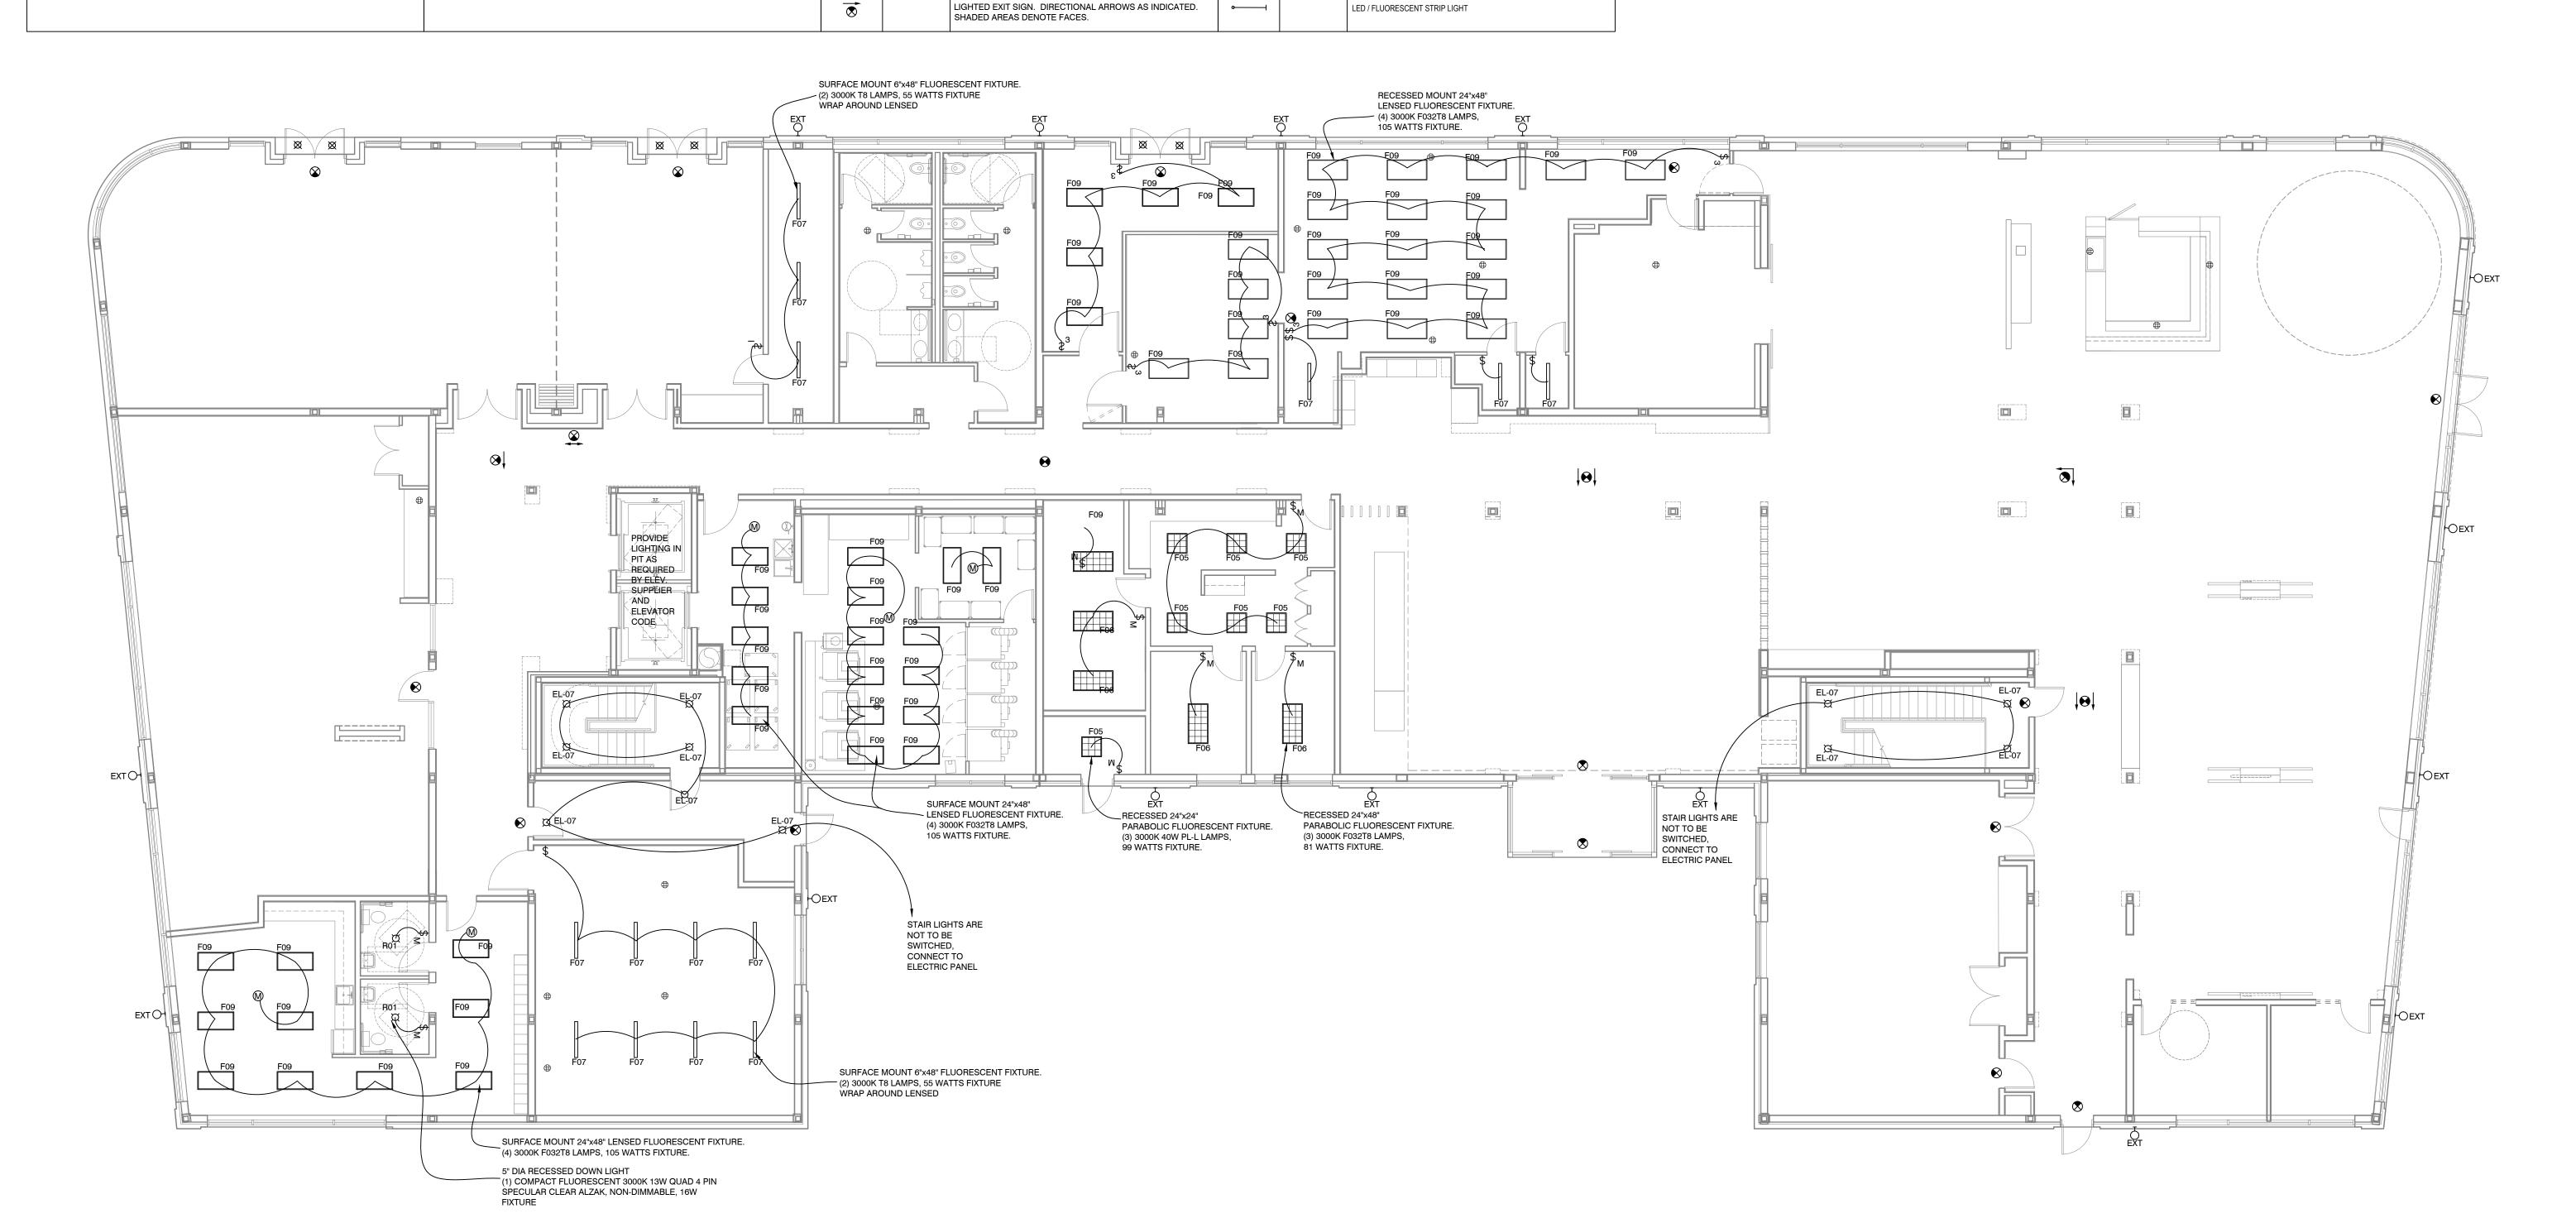

TRACK W/ ADJUSTABLE

TRACK HEADS

FIRST FLOOR LIGHTING PLAN

project architect: KAK drawn by:

FIRST LEVEL LIGHTING PLAN

sheet number: