


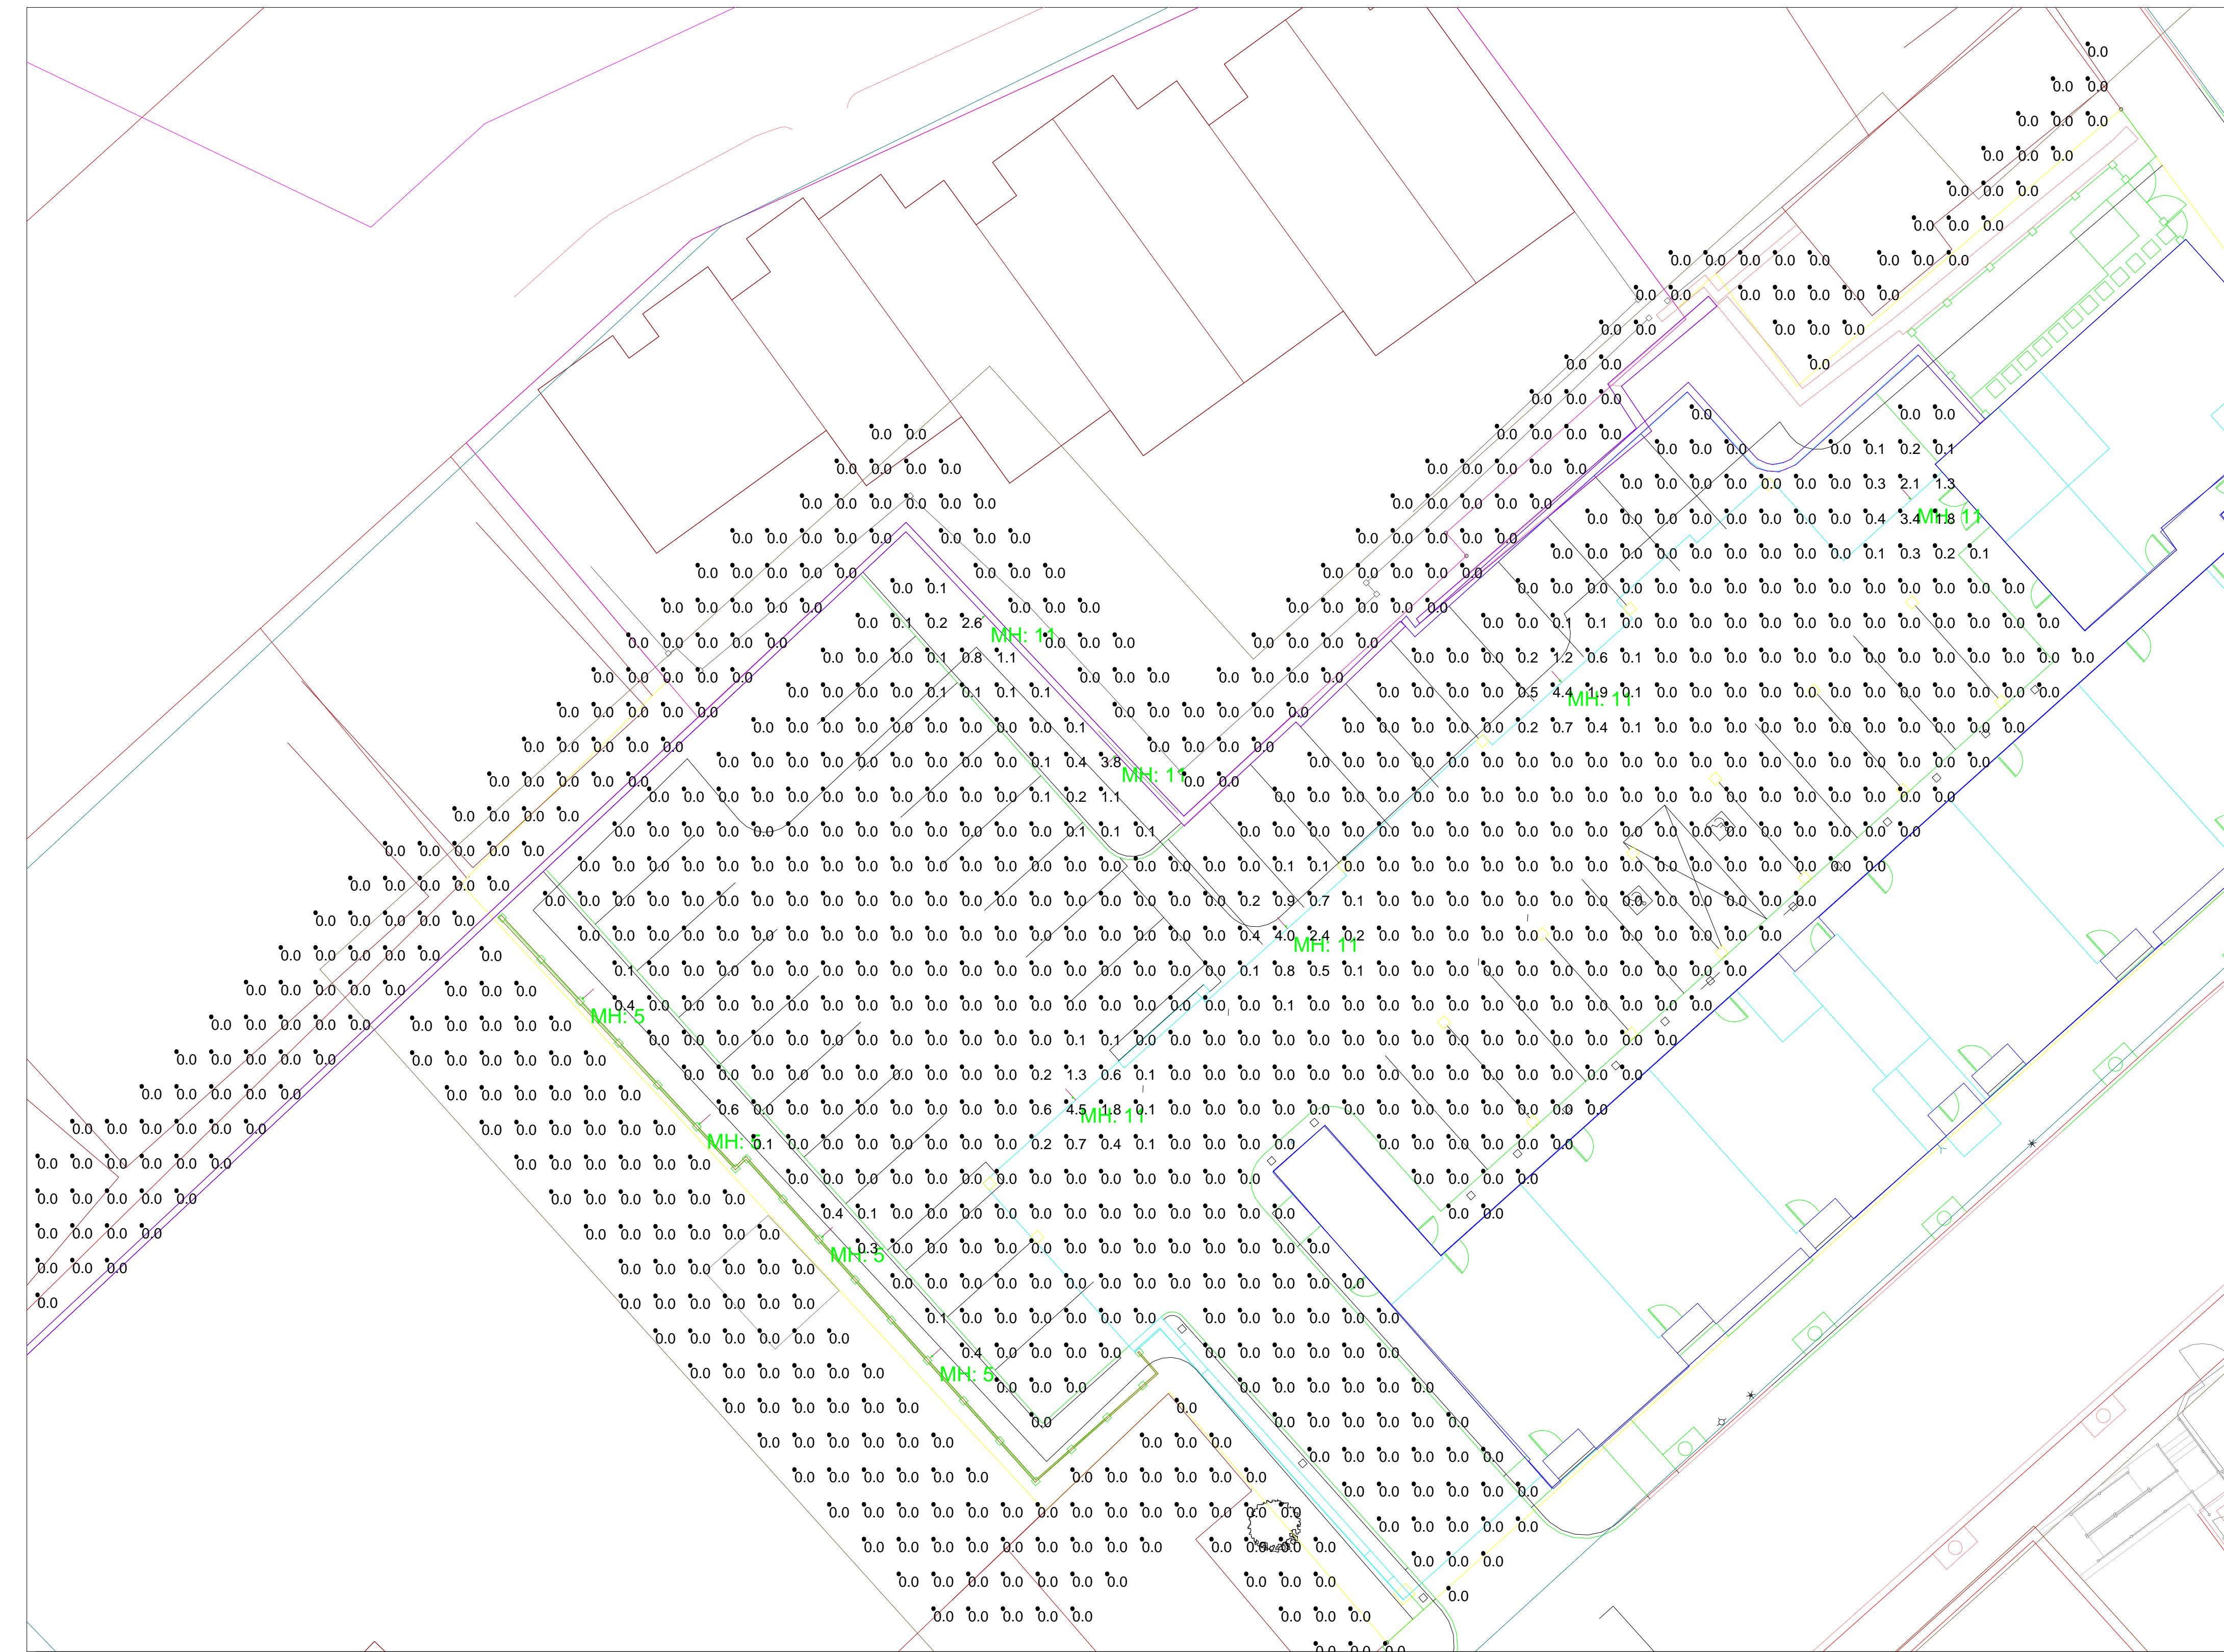

BK LIGHTING ARTISTAR WITH INTEGRAL TRANSFORMER AND ADJUST LUME SET AT 80%



Luminaire Schedule

Symbol	Qty	Lum. Lumens	LLF	Description
●	10	347	0.800	NS-LED-e23-WFL-12; AR-LED-TR-e23-WFL-12-

Calculation Summary

Label	Avg	Max	Min
Parking	0.08	4.5	0.0
perimeter	0.00	0.0	0.0
perimeter_1	0.00	0.0	0.0

#	Date	Comments
1	11/6/14	Preliminary - REV 1

Revisions

Drawn By: Steve Weatherbie
Not to Scale
THIS LIGHTING CALCULATION IS BASED ON LIMITED INFORMATION
SUPPLIED BY OTHERS TO SWANEY LIGHTING ASSOCIATES AND
STANDARD ASSUMPTIONS ON THE SPACE OR SITE CHARACTERISTICS.
FIELD DEVIATIONS MAY SIGNIFICANTLY AFFECT PREDICTED
PERFORMANCE. PRIOR TO INSTALLATION CRITICAL SITE INFORMATION
SHOULD BE COORDINATED WITH THE OWNER AND/OR
THE PROJECT CONTRACTOR TO DETERMINE IF SITE CONDITIONS ARE AS
REPRESENTED.