


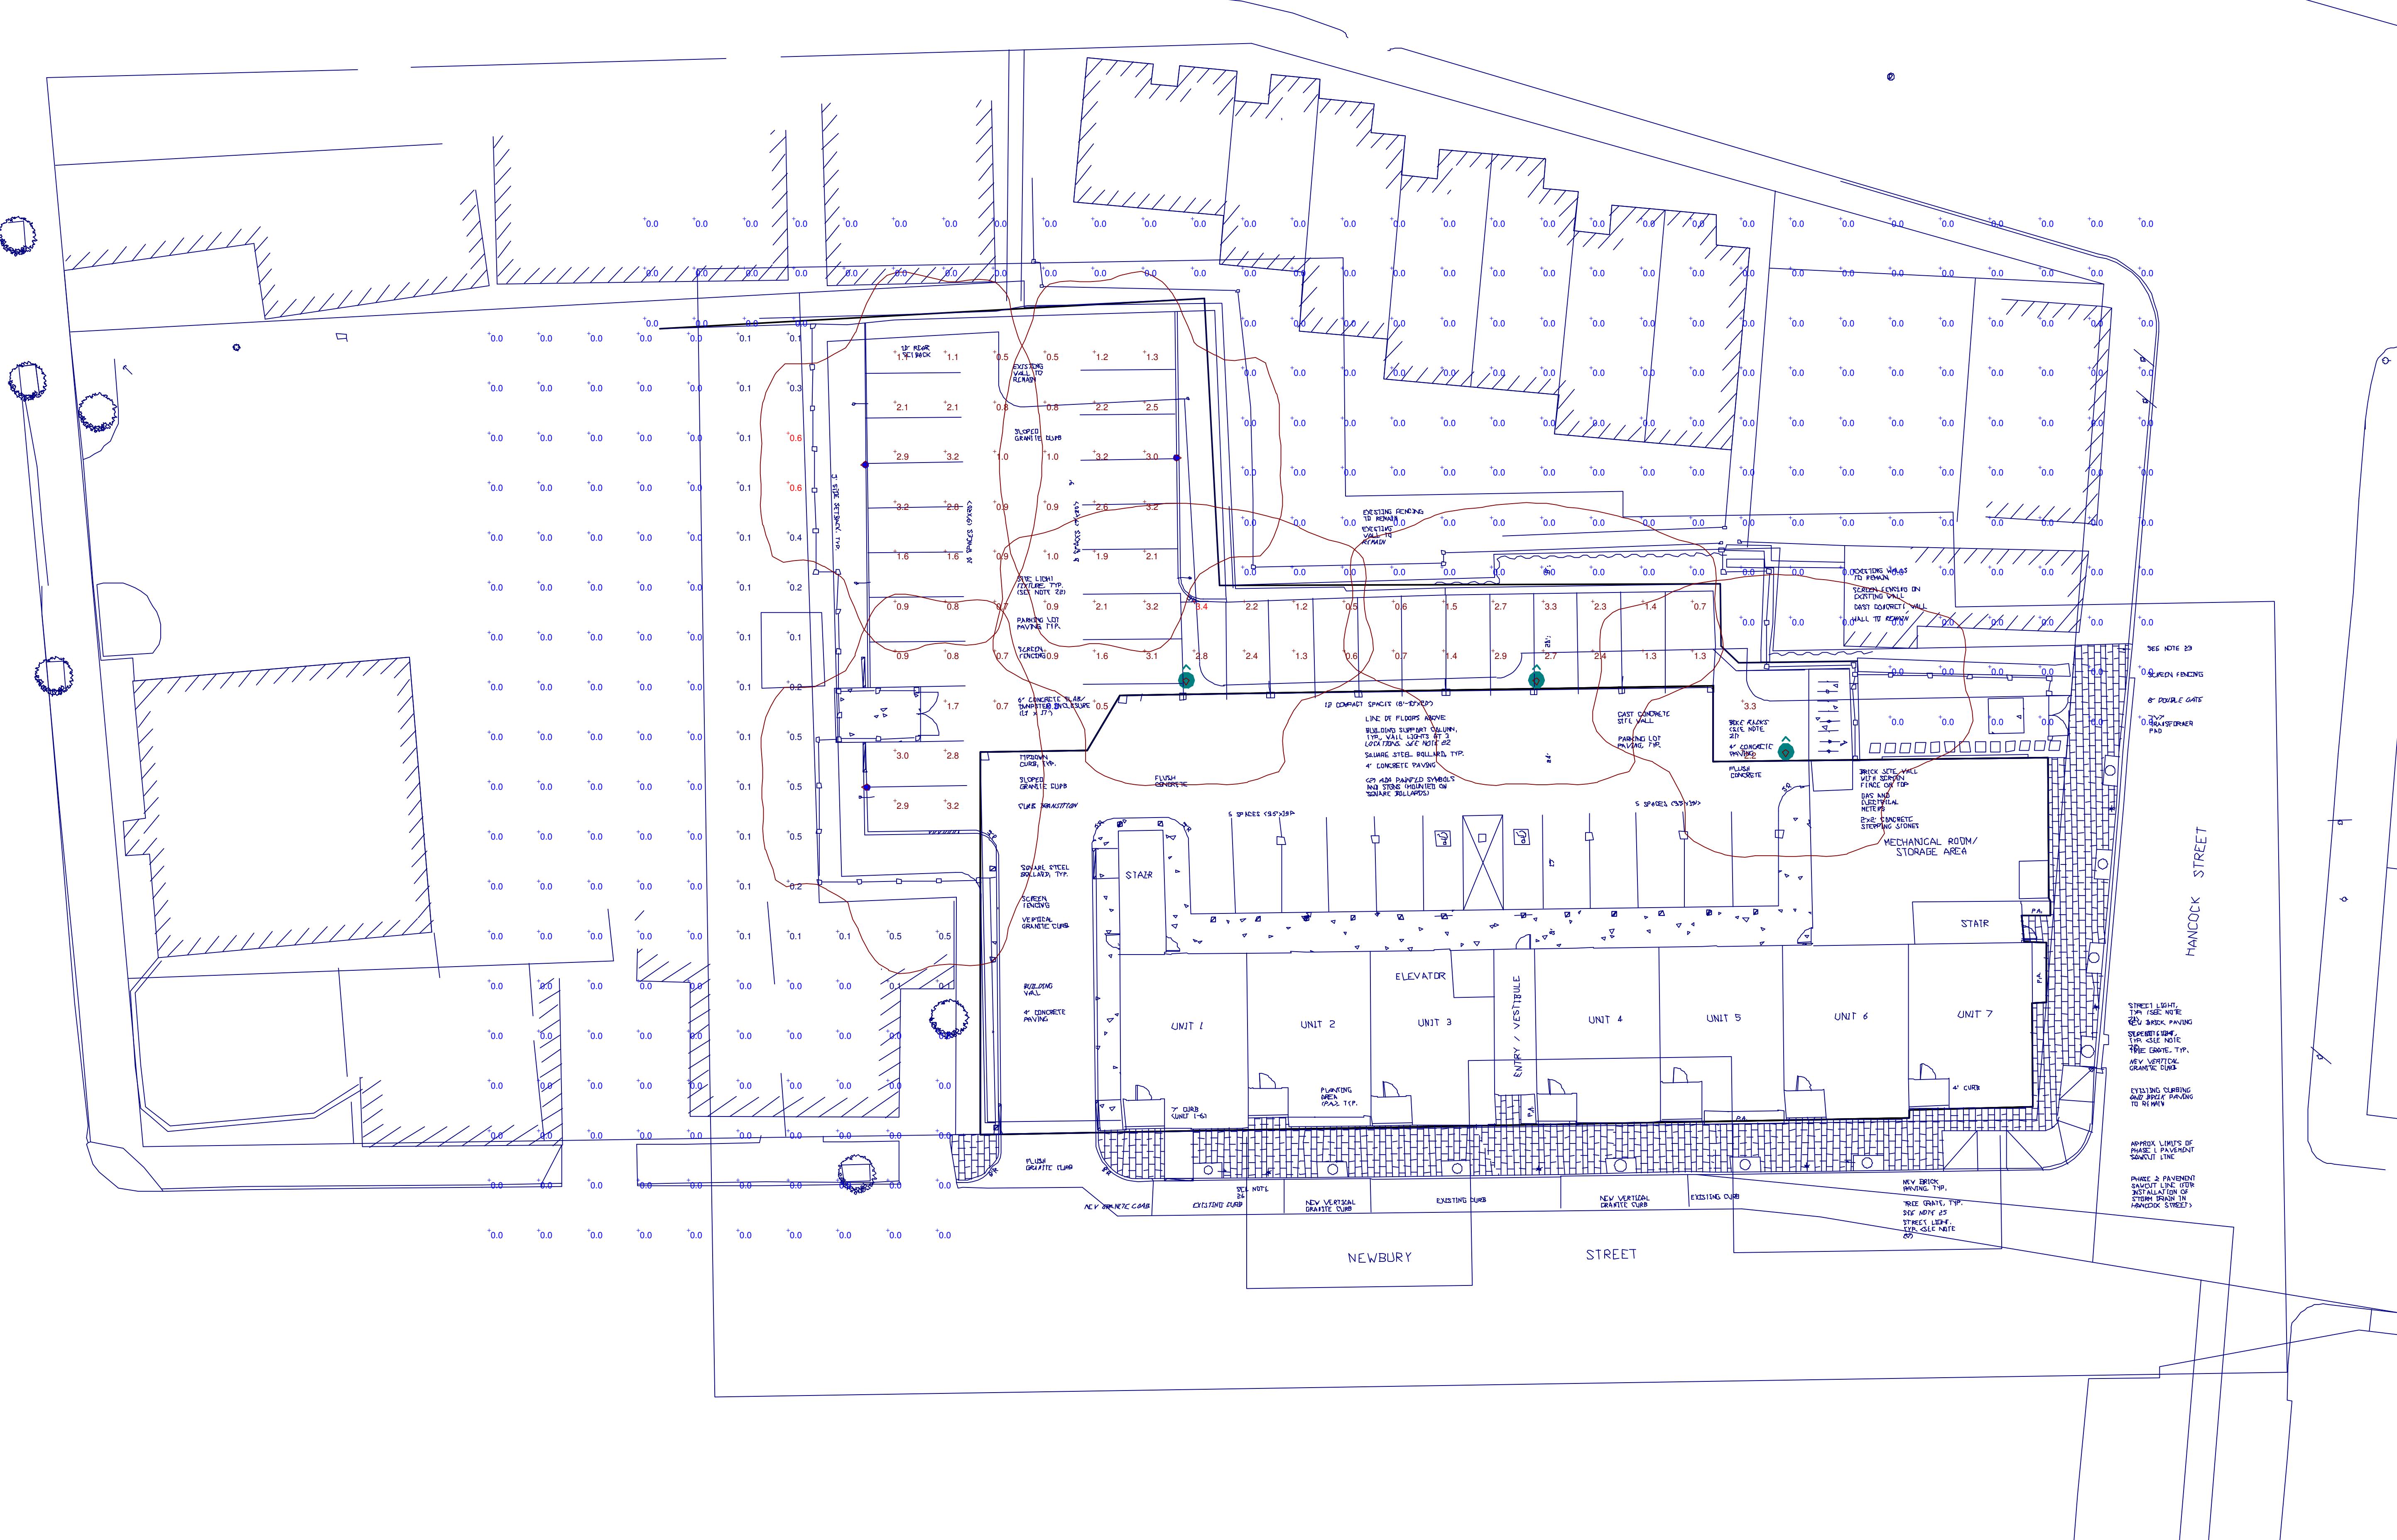

The Bay House, Phase II

STATISTICS						
Description	Symbol	Avg	Max	Min	Max/Min	Avg/Min
east spill at 0' AFG	+	0.0 fc	0.6 fc	0.0 fc	N/A	N/A
north spill at 12' AFG	+	0.0 fc	0.0 fc	0.0 fc	N/A	N/A
parking lot footcandles	+	1.8 fc	3.4 fc	0.3 fc	11.3:1	6.0:1

LUMINAIRE SCHEDULE						
Symbol	Label	Qty	Catalog Number	Description	Lamp	File
●	A	3	PUL0704KASXL3X	Holophane FCO LED POST TOP SERIES	70W LED ARRAY	PUL0704KASX Absolute L3X.ies
●	B	3	PUL0704KASXL3X	Holophane FCO LED POST TOP SERIES	70W LED ARRAY	PUL0704KASX Absolute L3X.ies



Designer

WC/JB

Date

Aug 30 2013

Scale

Drawing No.