




FORE 85

May, 2015

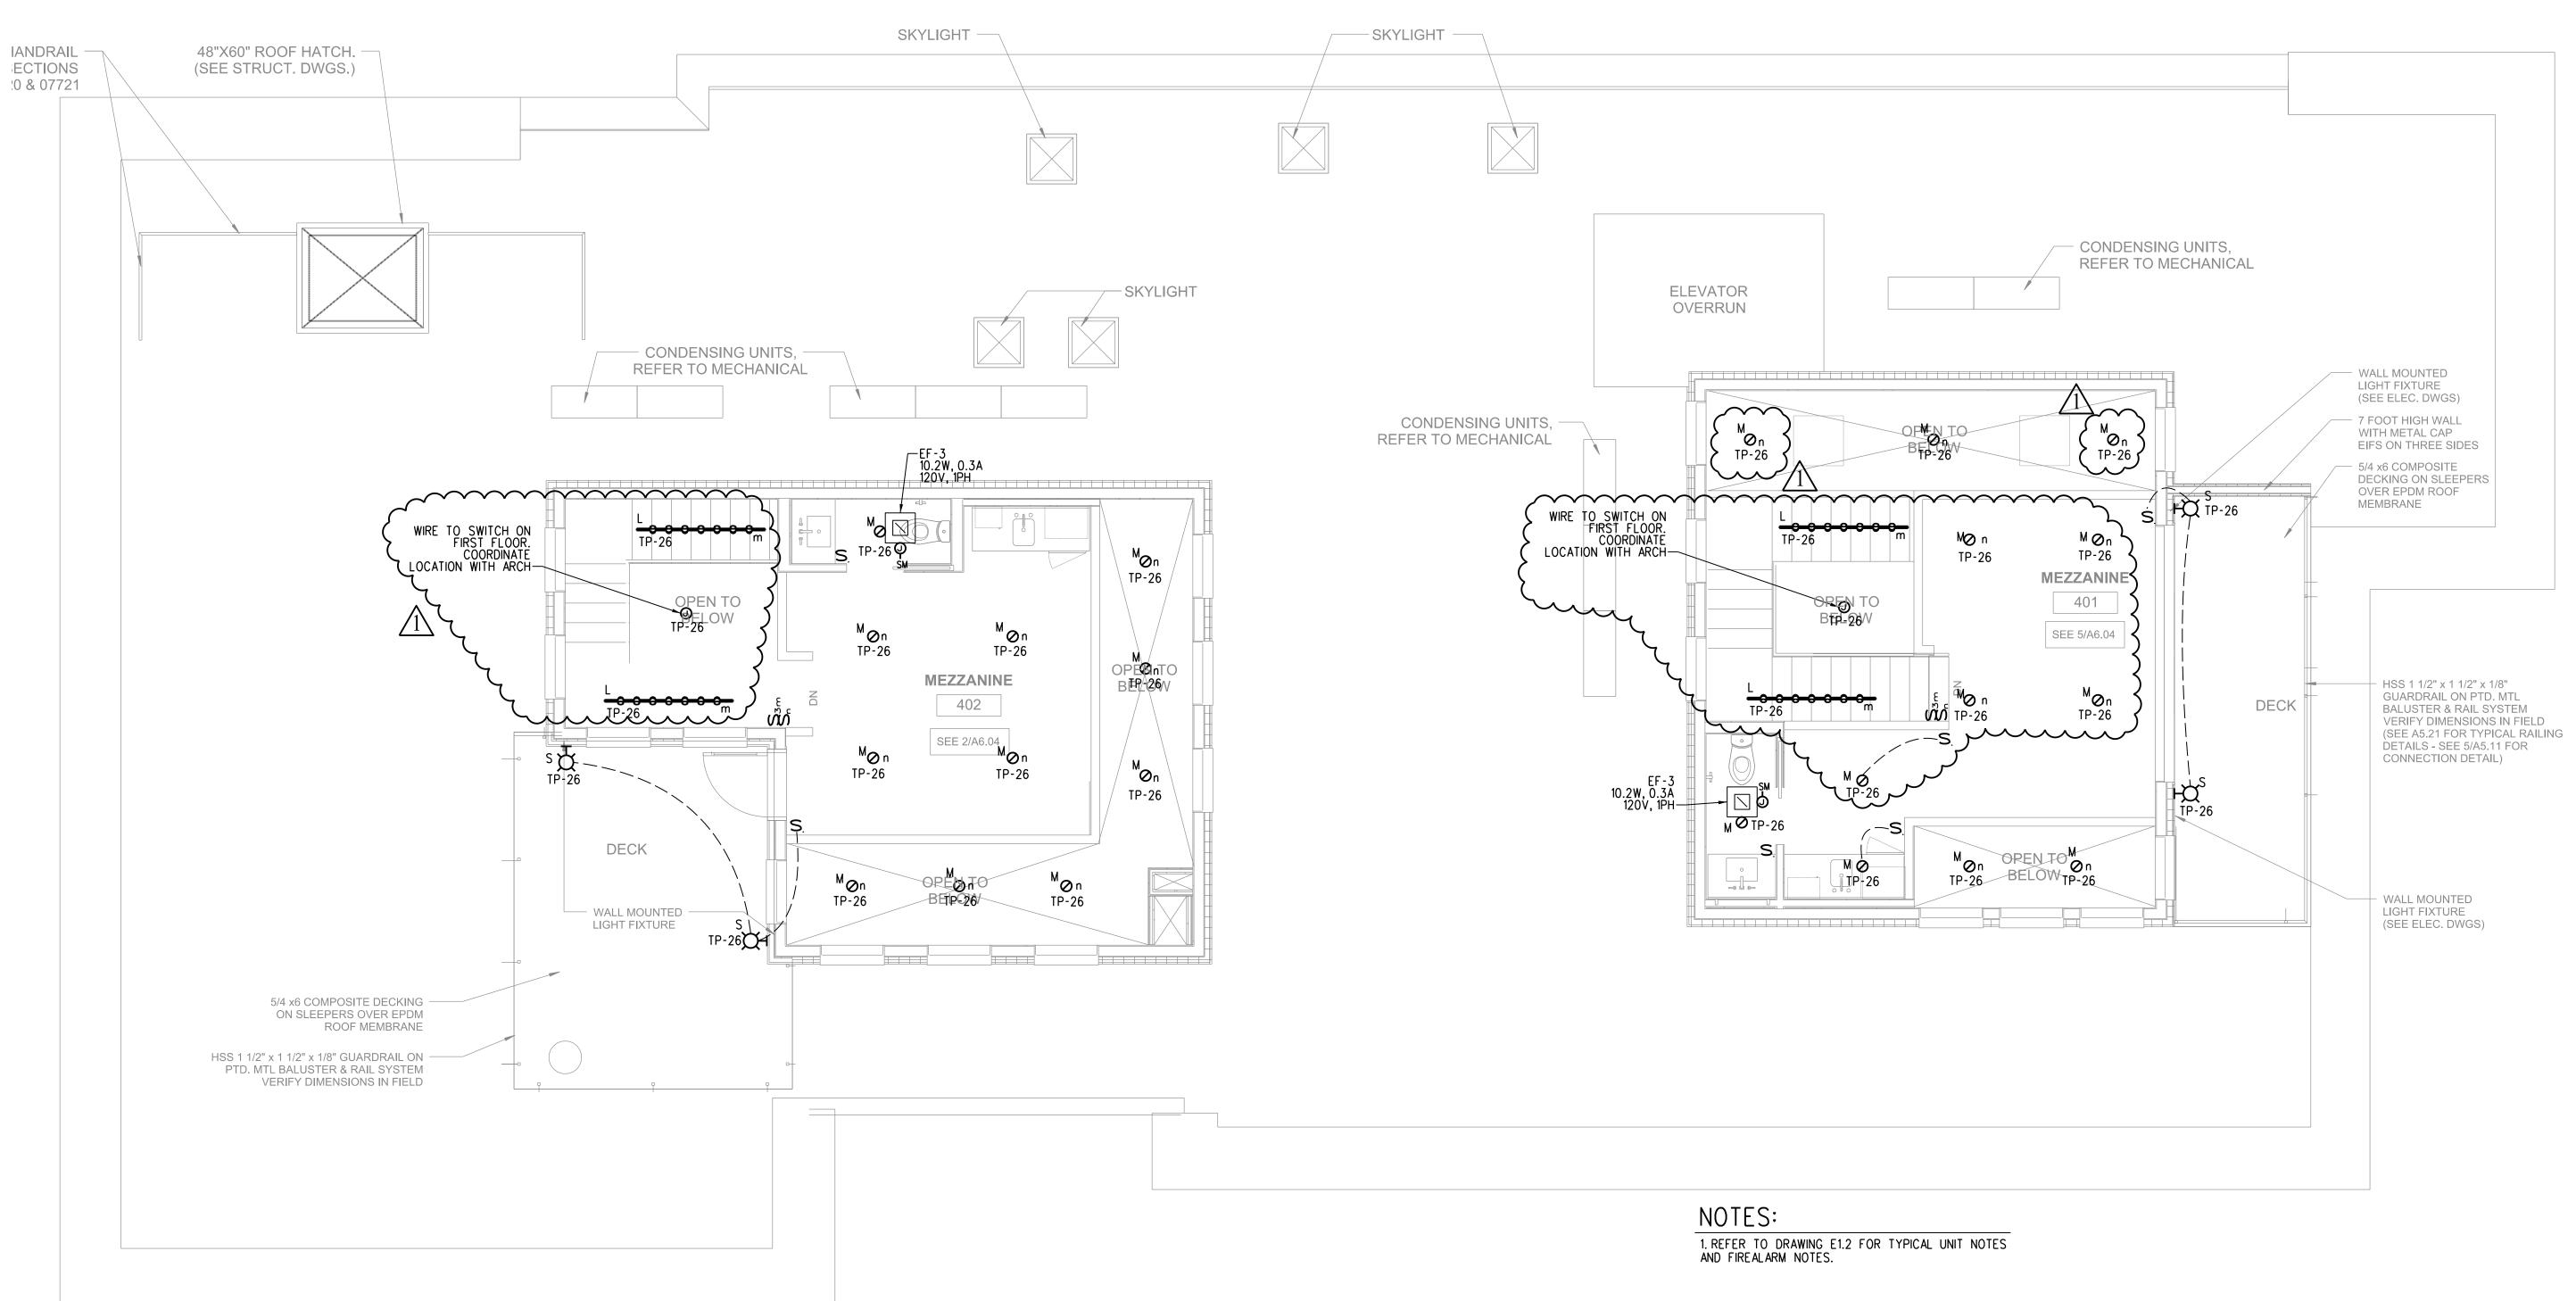



MEZZ LIGHTING PLAN

SCALE: 1/4" = 1'-0"