


STREET FORE

185

Date: 22 May, 2015

PENTHOUSE / ROOF MECHANICAL PLAN

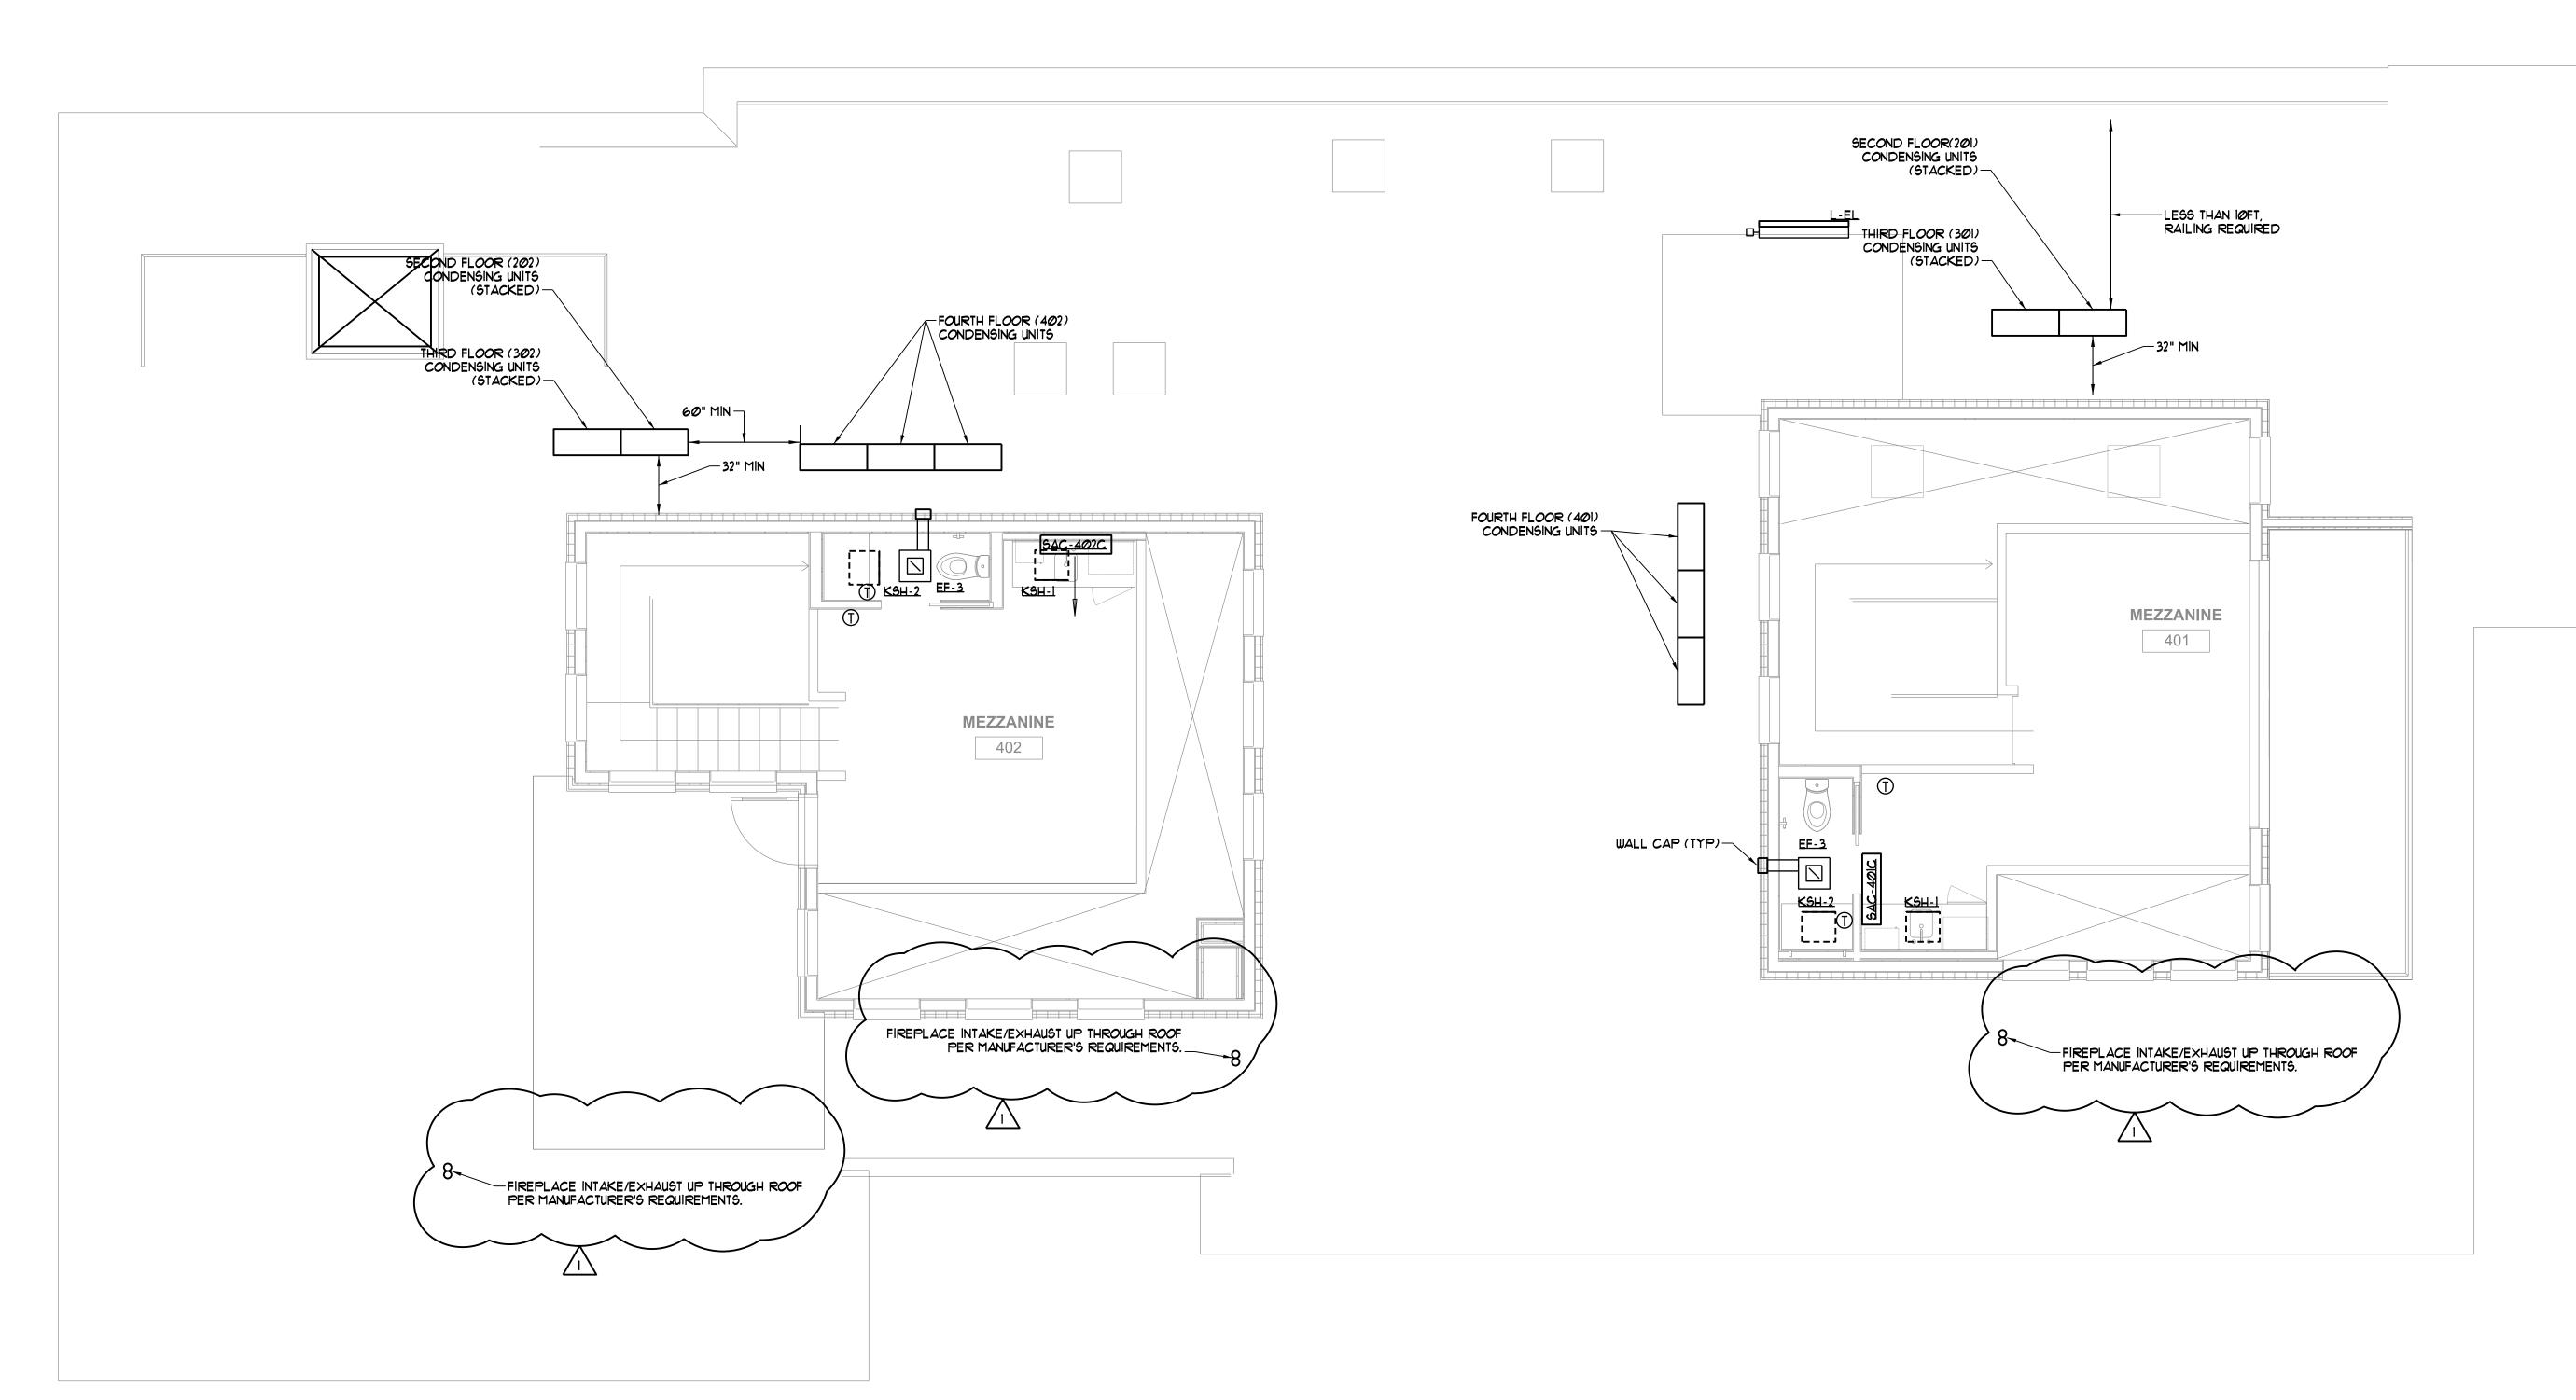

PENTHOUSE/ROOF MECHANICAL PLAN SCALE - 1/4" = 1'-0"