


NOTES:

- 1) EXACT MOUNTING DETAILS TO BE DETERMINED AT JOBSITE BY OTHERS.
- 2) CALCULATIONS MAY SHOW THE EFFECT OF SHADOWING CAUSED BY BUILDINGS AND OBJECTS WITHIN THE CALCULATED SPACE OR IN THE SITE AREA.
- 3) READINGS SHOWN ARE INITIAL HORIZONTAL FOOTCANDLES ON A FLAT SITE UNLESS OTHERWISE INDICATED.
- 4) THIS CALCULATION IS BASED ON LIMITED INFORMATION SUPPLIED BY OTHERS TO SWANEY LIGHTING ASSOCIATES AND STANDARD ASSUMPTIONS OF THE SPACE AND/OR SITE.
- 5) CONFORMANCE TO CODES AND OTHER LOCAL REQUIREMENTS AS DETERMINED BY THE AHJ ARE THE RESPONSIBILITY OF THE OWNER AND/OR THE OWNER'S REPRESENTATIVE.
- 6) THIS LAYOUT DRAWING MUST BE COORDINATED WITH THE SITE LOCATION FOR CORRECT FIXTURE ORIENTATION.
- 7) CHECK GRAPHIC SCALE. DOCUMENTS PRINTED OR PLOTTED FROM ELECTRONIC FILES MAY OCCUR AT OTHER THAN THE DESIRED OR ASSUMED GRAPHIC SCALES. IT IS THE RESPONSIBILITY OF THE RECIPIENT TO VERIFY THAT THE PRINTED OR PLOTTED-TO-SCALE DRAWING IS PRINTED TO SCALE.

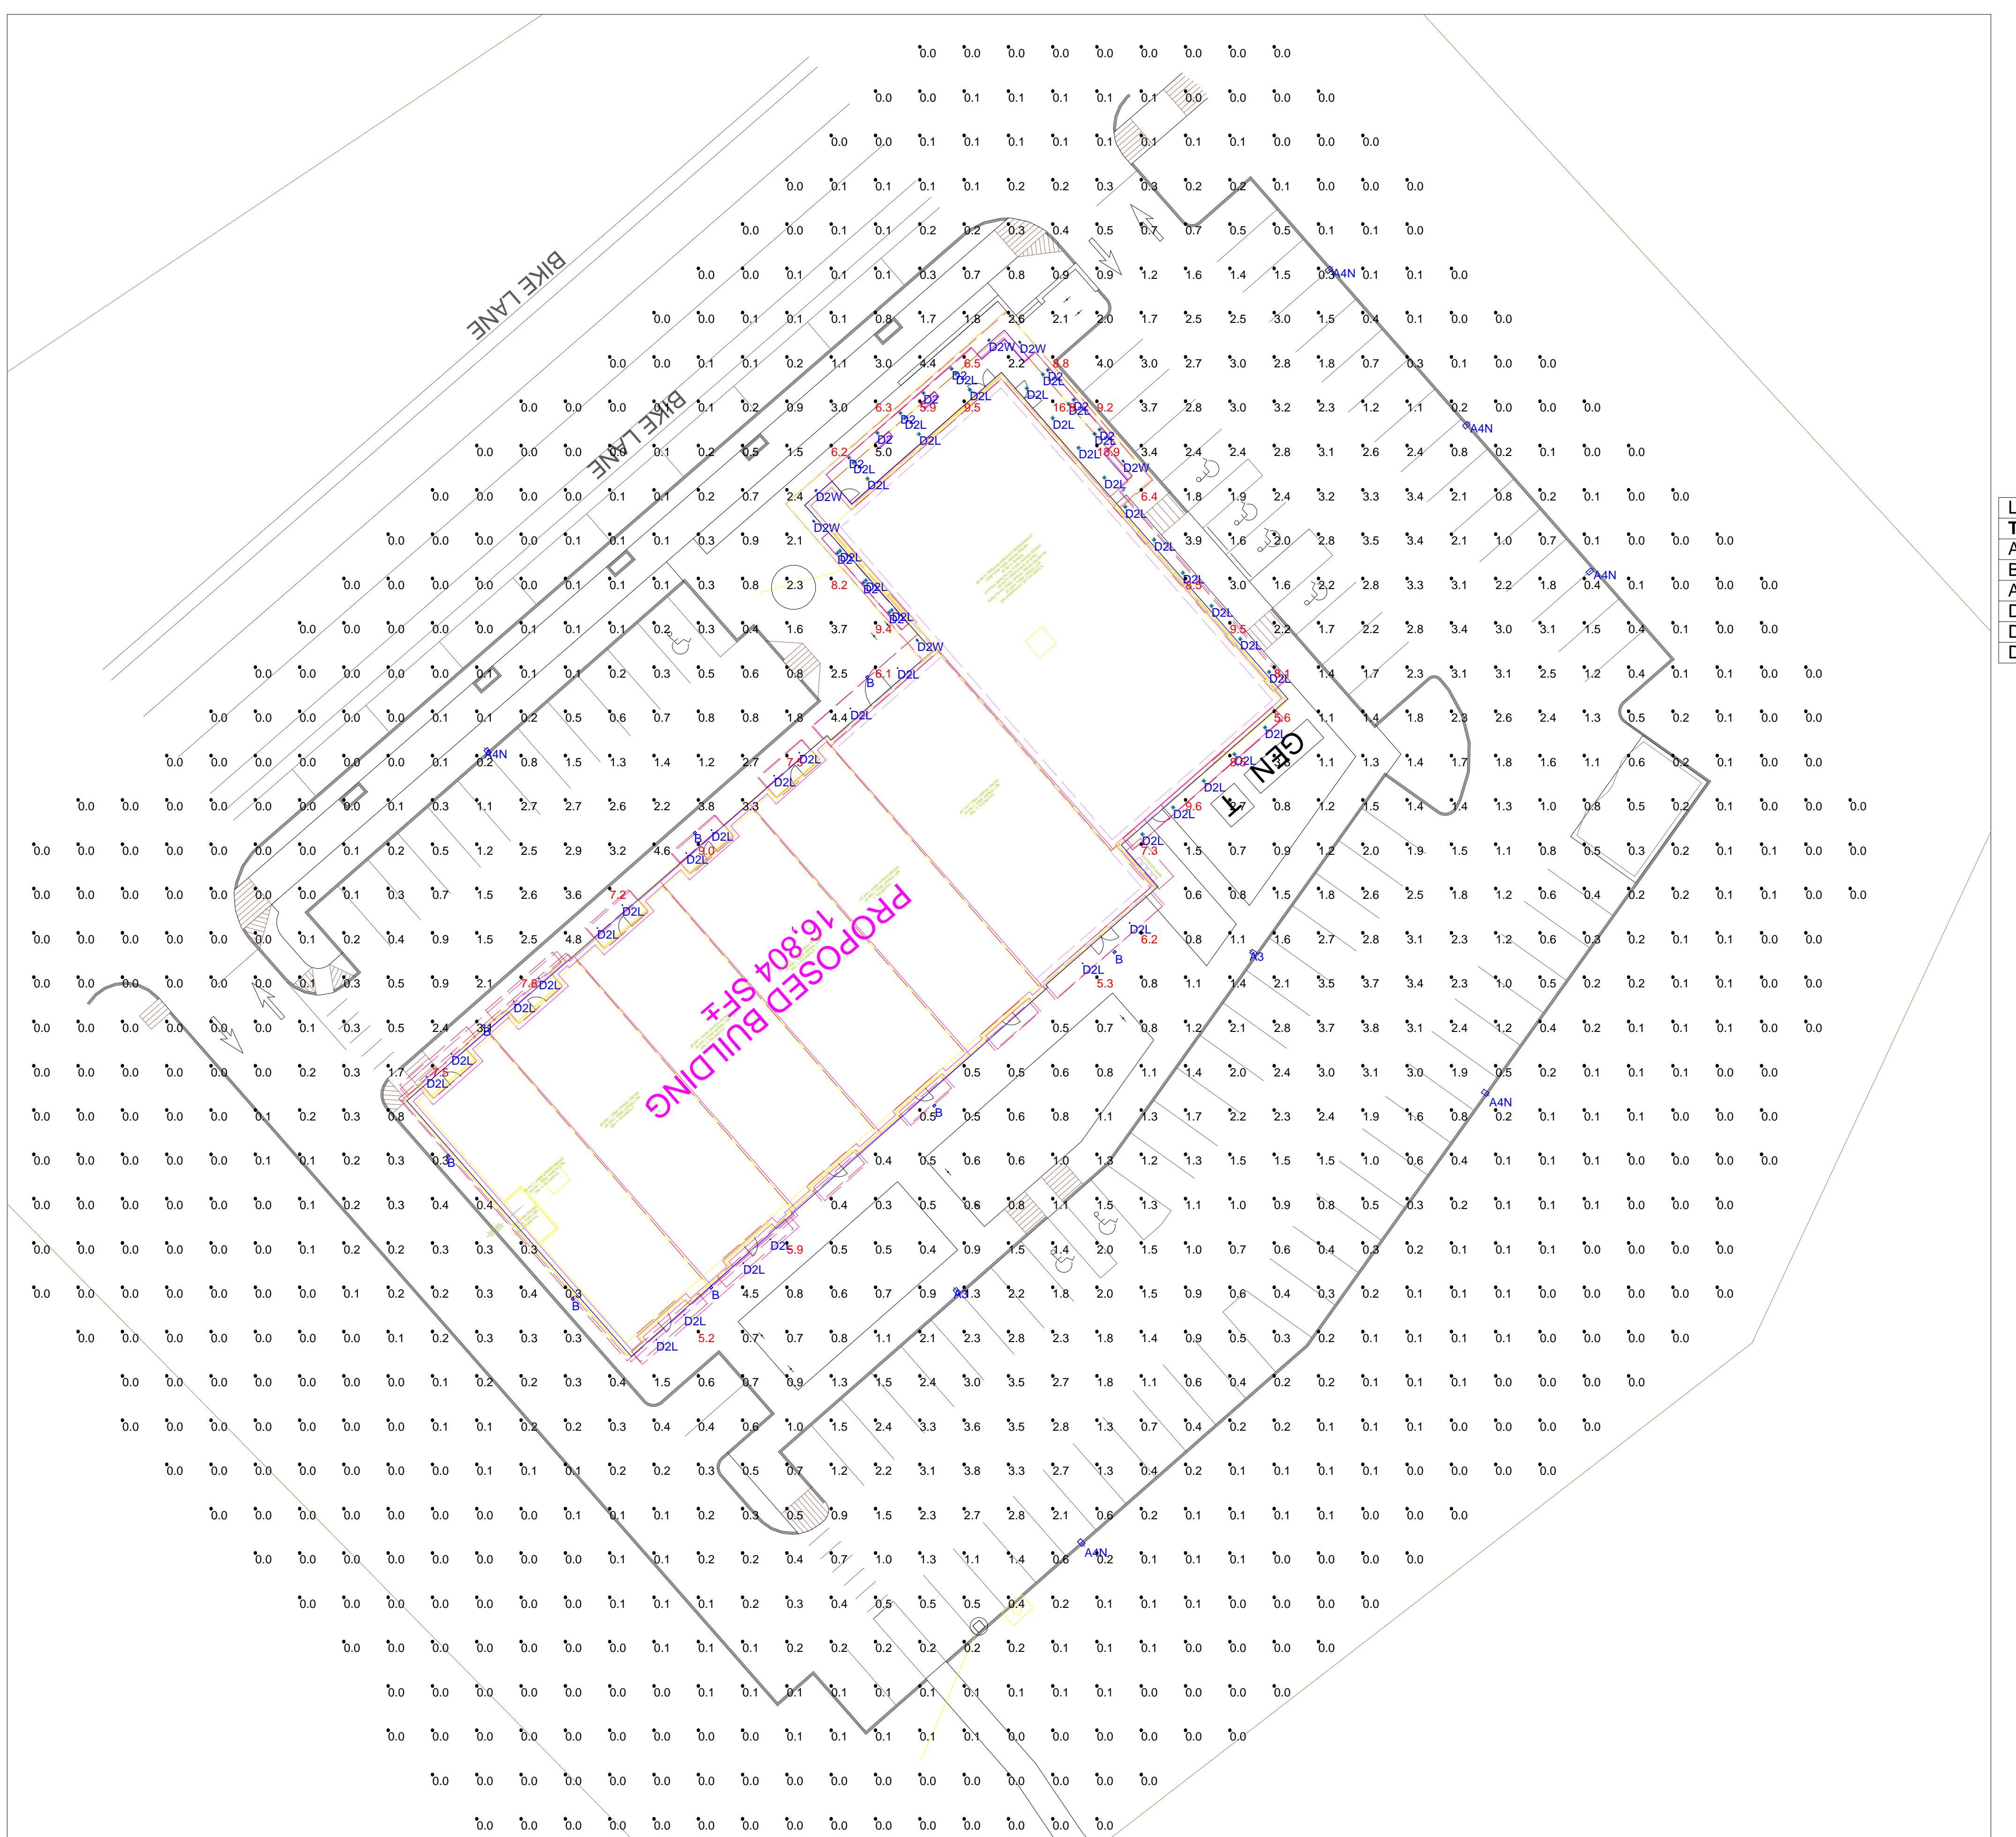

Calculation Summary					
Label	Avg	Max	Min	Avg/Min	Max/Min
SITE	0.80	16.8	0.0	N.A.	N.A.

Luminaire Schedule (note fixture catalog numbers are not complete)

Type	Qty	Lumens	LLF	Lum. Watts	Description
A4N	6	7745	0.900	90.4	AR4P35-80L4K-NFO
B	8	820	0.900	12.8	LCC-12LU-5K-1
A3	2	8509	0.900	91	AR3P35-80L4K
D2L	45	881	0.900	16	D2LED-2D9LED9L30K8WFL45
D2	11	1235	0.900	22	D2LED-2D9LED12L30K8WFL45
D2W	6	1002	0.900	22.1	D2LED-2D9LED12L30K8WW

191 MARGINAL WAY PORTLAND, ME SITE LIGHTING LAYOUT

TITLE: Page 1 of 1 Date: 2/26/2017
STANTEC Scale Not To Scale
SITE: 2-6-17 AGI



NOTICE: THIS DRAWING IS THE EXCLUSIVE PROPERTY OF SWANEY LIGHTING ASSOCIATES. ITS ACCEPTANCE CONSTITUTES AN AGREEMENT THAT THE DRAWING WILL BE TREATED AS CONFIDENTIAL INFORMATION AND NOT BE COPIED, REPRODUCED, OR DISCLOSED, AND THAT THIS DRAWING IS NOT TO BE RETURNED UPON REQUEST AND IS NOT TO BE COMMUNICATED OR MADE AVAILABLE TO OTHERS EXCEPT EXPRESSLY AUTHORIZED BY SWANEY LIGHTING ASSOCIATES. NOTICE: THE ATTACHED LIGHTING LAYOUT SUGGESTS THE RECOMMENDED LIGHTING PERFORMANCE FROM THE MANUFACTURER. ANY VARIATION IN THE PERFORMANCE FROM THE MANUFACTURER'S SPECIFIED PERFORMANCE SHOWN IN THIS FILE IS THE RESPONSIBILITY OF SWANEY LIGHTING ASSOCIATES. FOR ANY OTHER PURPOSE THIS DRAWING IS NOT AUTHORIZED BY SWANEY LIGHTING ASSOCIATES.