



BUILDING 2 1ST LEVEL GREASE WASTE RISER

BUILDING 2 INTERIOR GARAGE DRAIN RISER


BUILDING 2 ROOF DRAIN RISER

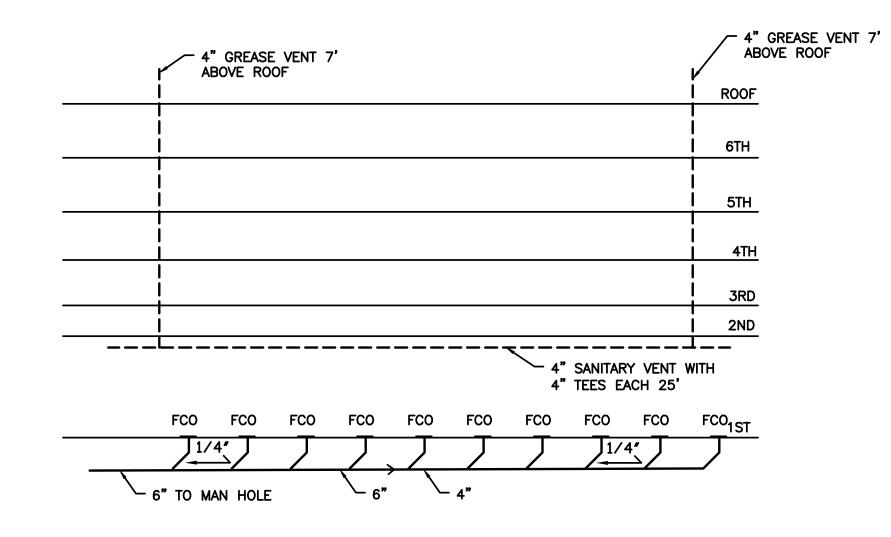


BUILDING 2 1ST LEVEL SANITARY WASTE RISER N.T.S.

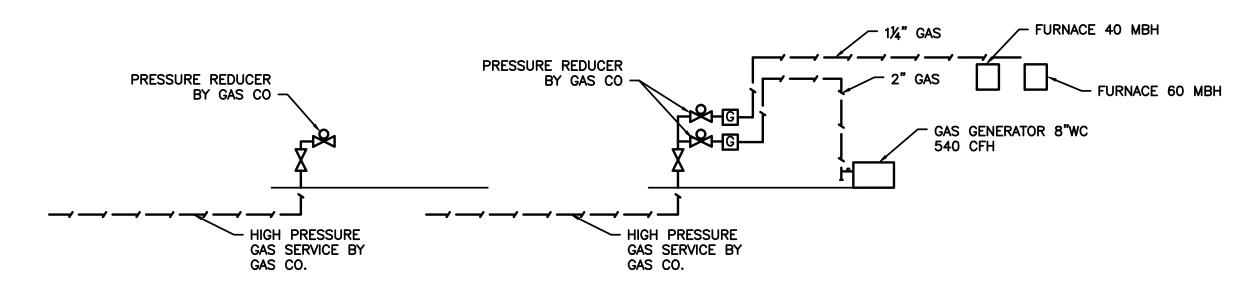

BUILDING 2 GAS PIPING N.T.S.

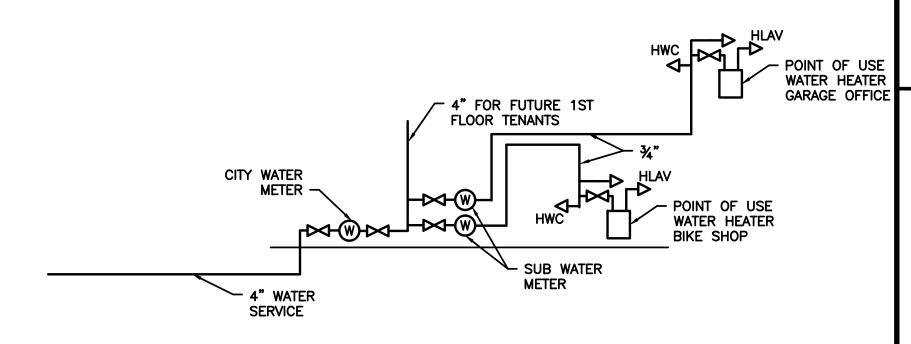

BUILDING 2 WATER PIPING

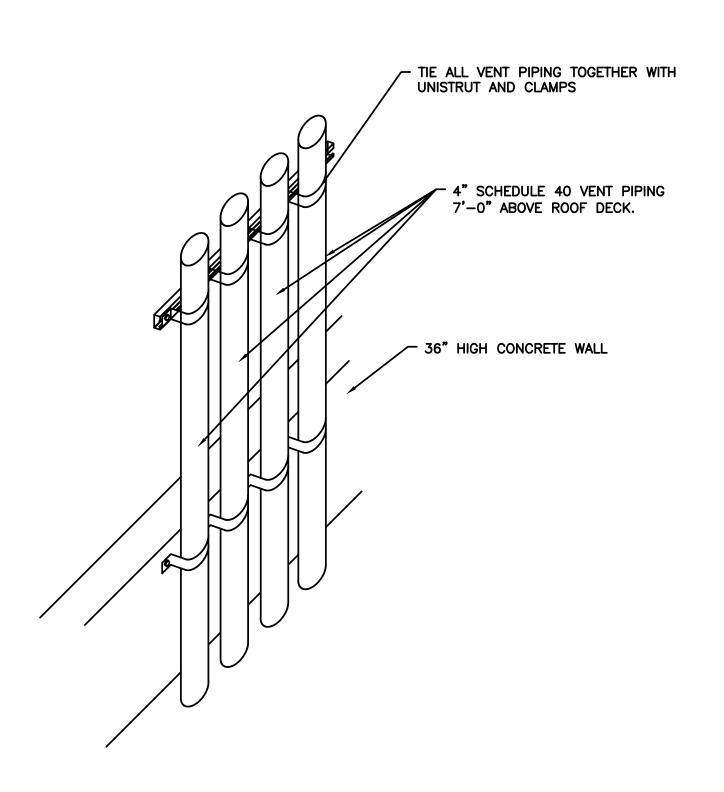

BUILDING 2 ROOF VENT PIPING DETAIL
N.T.S.

Revised Permit Set April 15, 2016

Permit Set February 8, 2016

THA ARCHITECTS, LLC

ARCHITECTURE DESIGN PLANNING INTERIOR DESIGN

STRATHAM, NEW HAMPSHIRE 03885

Tel: (603) 770-2491 Fax: (603) 773-0238

www.thaarc.com
These drawings and specifications were prepared

These drawings and specifications were prepared for use at the location indicated. Publication and use is expressly limited to the identified location. Reuse or reproduction by any method, in whole or in part, is prohibited without the written permission of THA Architects, LLC.



midtown Portland

Somerset Street
Elm Street
Portland, ME

Building 2 PLUMBING RISER DIAGARM & DETAILS

Structural Engineer
Becker Engineering
MEP ENGINEER
McCabe Associates
FP Engineer
McCabe Associates

SCALE: 1/16"=1'-0"

ISSUED / DRAWN BY

© THA Architects, LLC.

REVISED / REVISED BY

JOB NO: 15001

SHEET NUMBER

P-3.1