

Winton Scott **Architects** 5 Milk Street Portland, ME 04101

Wright Ryan Construction, Inc. 10 Danforth Street Portland, ME 04101

Becker Structural Engineers, Inc. 75 York Street Portland, Maine 04101

Mechanical Systems Engineers
10 Royal River Center
Yarmouth, Maine 04096

Bartlett Design 942 Washington St. Bath, Maine 04530


Fore Solutions 386 Fore Street Portland, Maine 04101

SECOND FLOOR LIGHTING PLAN-PART C

Includes all revisions and changed up to and including 10-28-09

Scale: 1/8" = 1'-0" Date: 03-20-09

SECOND FLOOR LIGHTING PLAN — PART C (1) (E2.6) 1/8" = 1'-0"

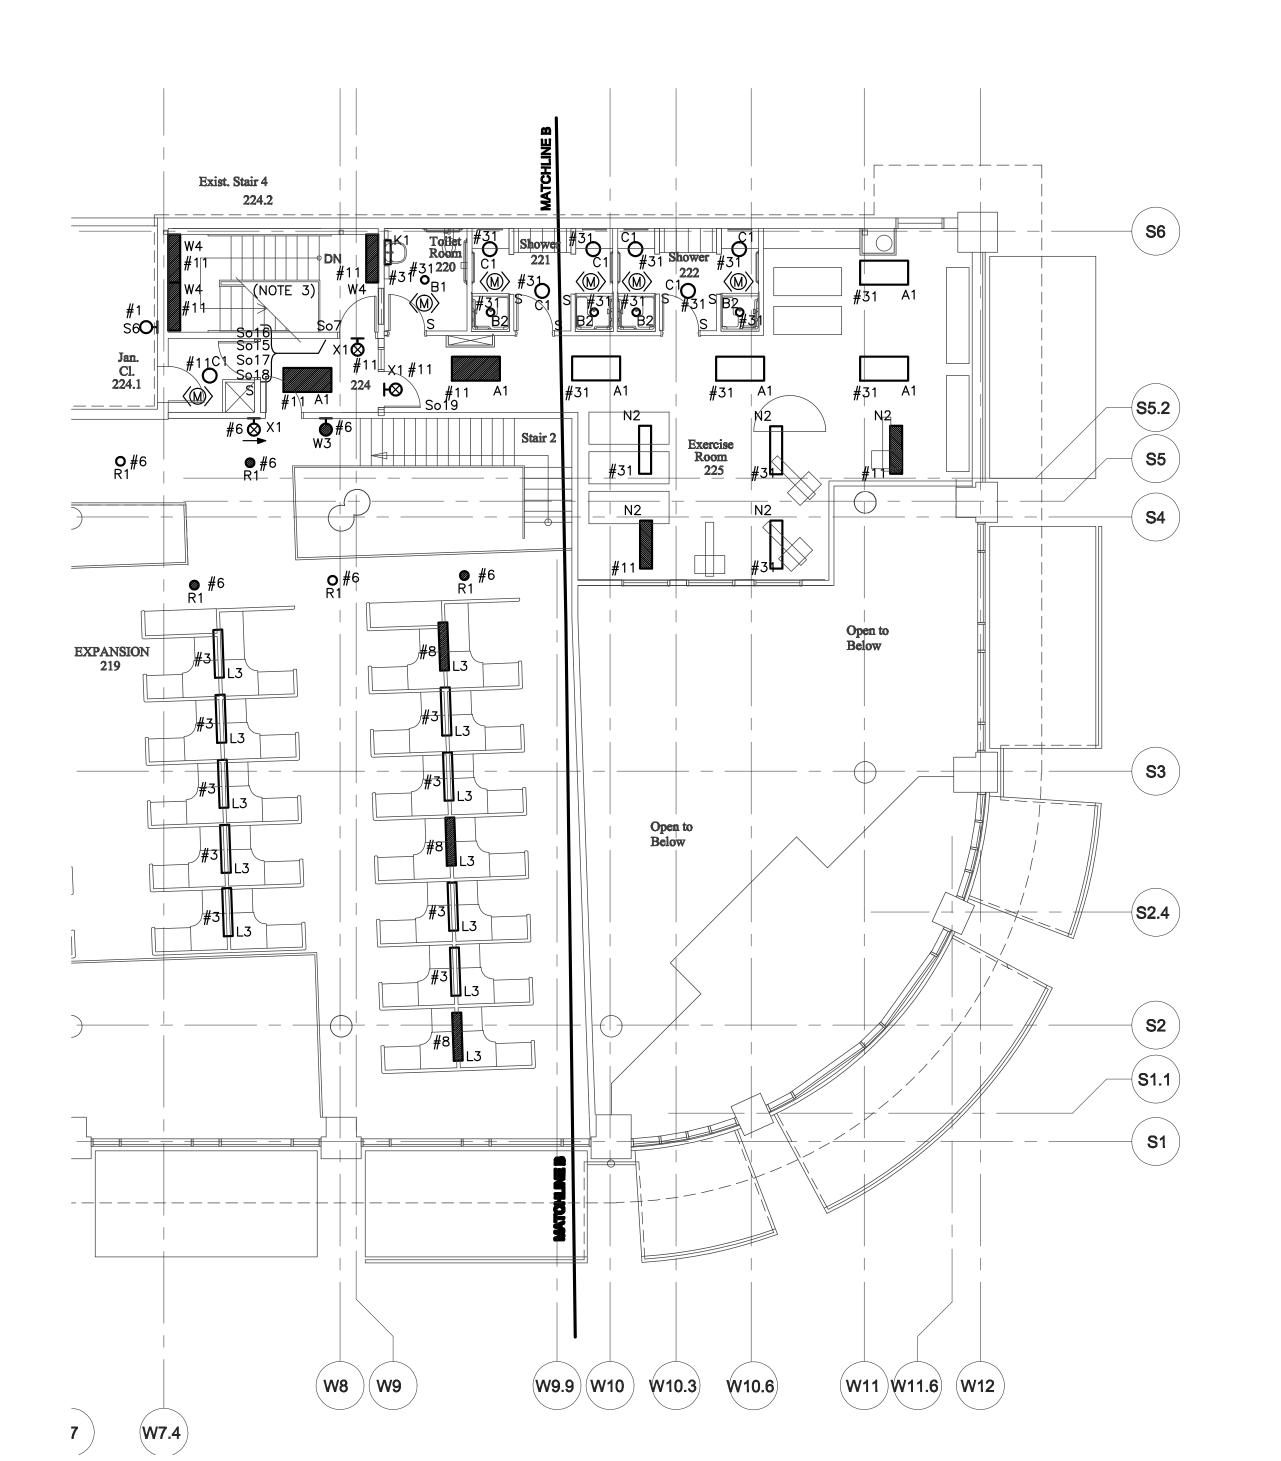

NOTES:

1. INTERIOR LIGHTS WITH SHADED PATTERNS WILL BE CIRCUITED TO PANEL P-EL1. ALL OTHER INTERIOR LIGHTS IN AREA C SHALL BE CIRCUITED TO PANEL P3.

2. LIGHT SWITCHES INDICATED BY So15, So17, So18, & So19 SHALL BE LOW VOLTAGE CONTROL SWITCHES WIRED TO TO THE LIGHTING CONTROL PANEL LOCATED IN ELEC/DATA CLOSET 135.