


1. CIRCUIT DESIGNATIONS LOCATED IN PLAN AREA C

- REFER TO PANEL P3. 2. VOICE/DATA WIRING FROM OUTLETS SHALL BE EXTENDED TO NETWORK SWITCHES LOCATED IN THE CEILING SPACE BETWEEN THE FIRST FLOOR AND THE MEZZANINE. SEE SHEET E1.3 FOR KEY PLANS DESIGNATING SHOWING BUILDING AREA GROUPS AND THEIR ASSOCIATED NETWORK SWITCHES AS WELL AS
- CIRCUITING INFORMATION FOR NETWORK SWITCHES.

  3. WORKSTATIONS LOCATED IN PLAN AREA C SHALL BE CIRCUITED TO PANEL P3.
- 4. SEE SHEET E1.1 FOR FURNITURE PARTITION WIRING



5. SEE SHEET E1.4 FOR SKYLIGHT AWNING WINDOW ELECTRIC OPERATOR WIRING DIAGRAM.

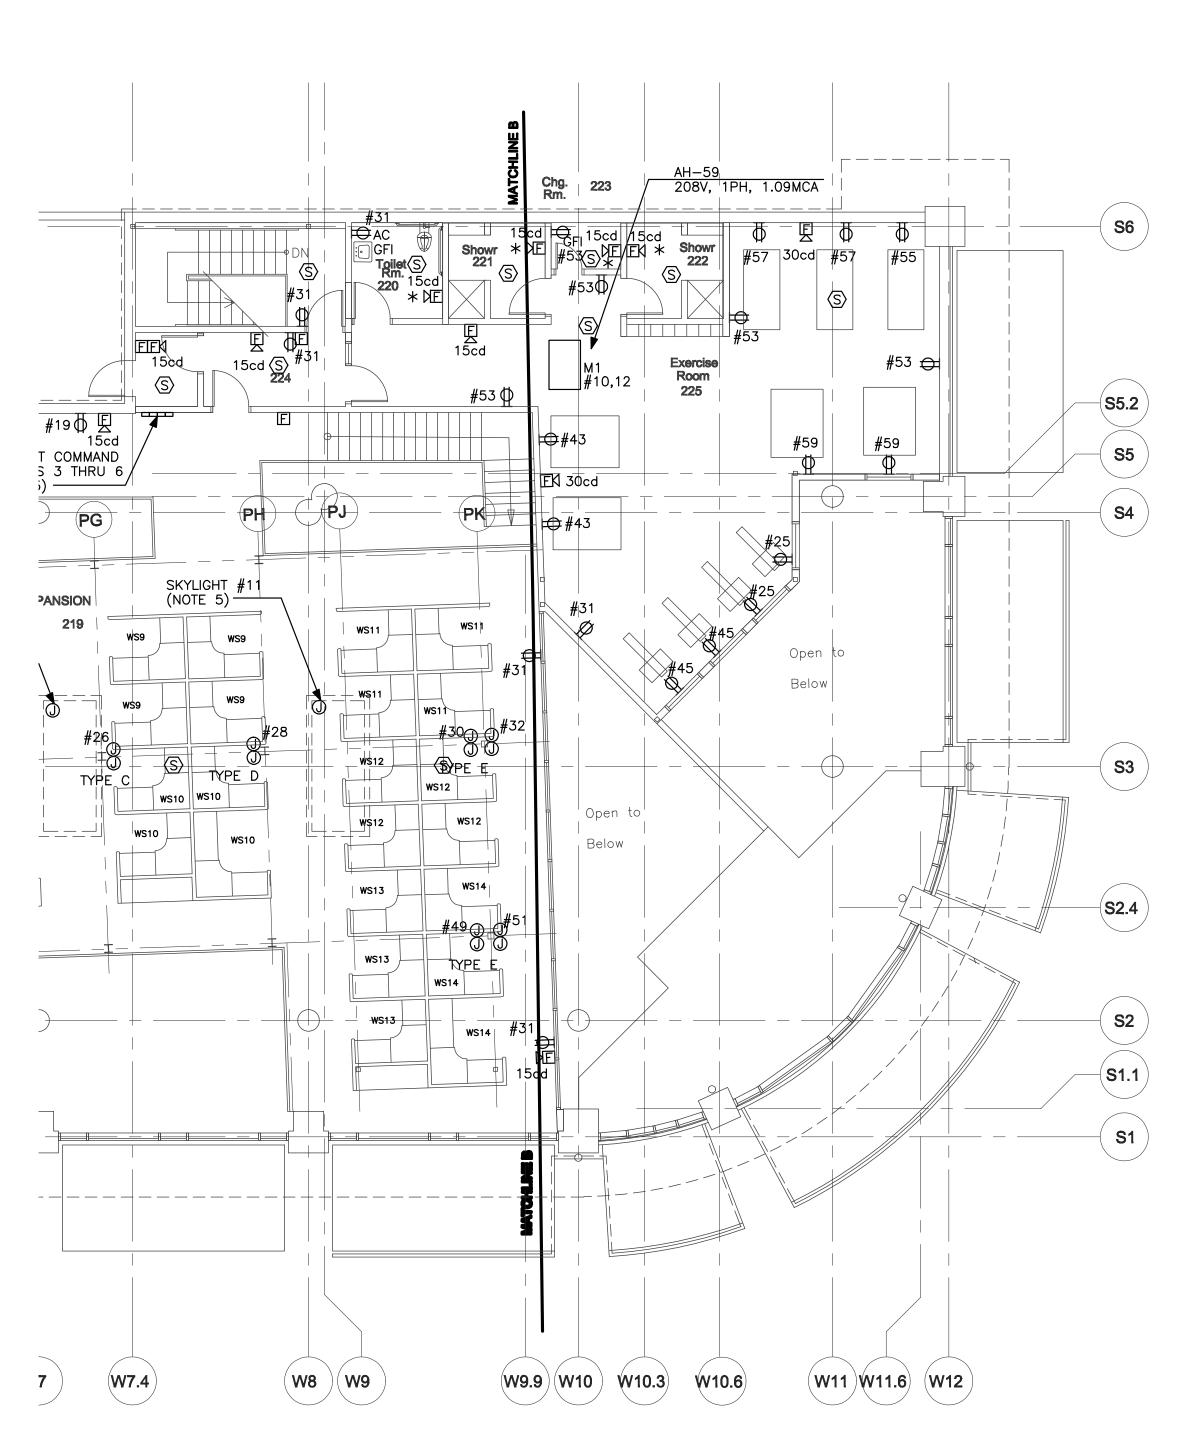

## SECOND FLOOR POWER PLAN — PART C 1/8" = 1'-0"

Winton Scott **Architects** 5 Milk Street Portland, ME 04101

Wright Ryan Construction, Inc. 10 Danforth Street Portland, ME 04101

**Becker Structural** Engineers, Inc. 75 York Street Portland, Maine 04101

Mechanical Systems Engineers 10 Royal River Center Yarmouth, Maine 04096

Bartlett Design 942 Washington St. Bath, Maine 04530

**Fore Solutions** 386 Fore Street Portland, Maine 04101

SECOND FLOOR **POWER** PLAN-PART C

Scale: 1/8" = 1'-0"

Date: 03-20-09