
PROJECT ARCHITECT:

MW

DRAWN BY:

DRAWN BY:
SO, BR
PROJECT #:
300506

A2.5

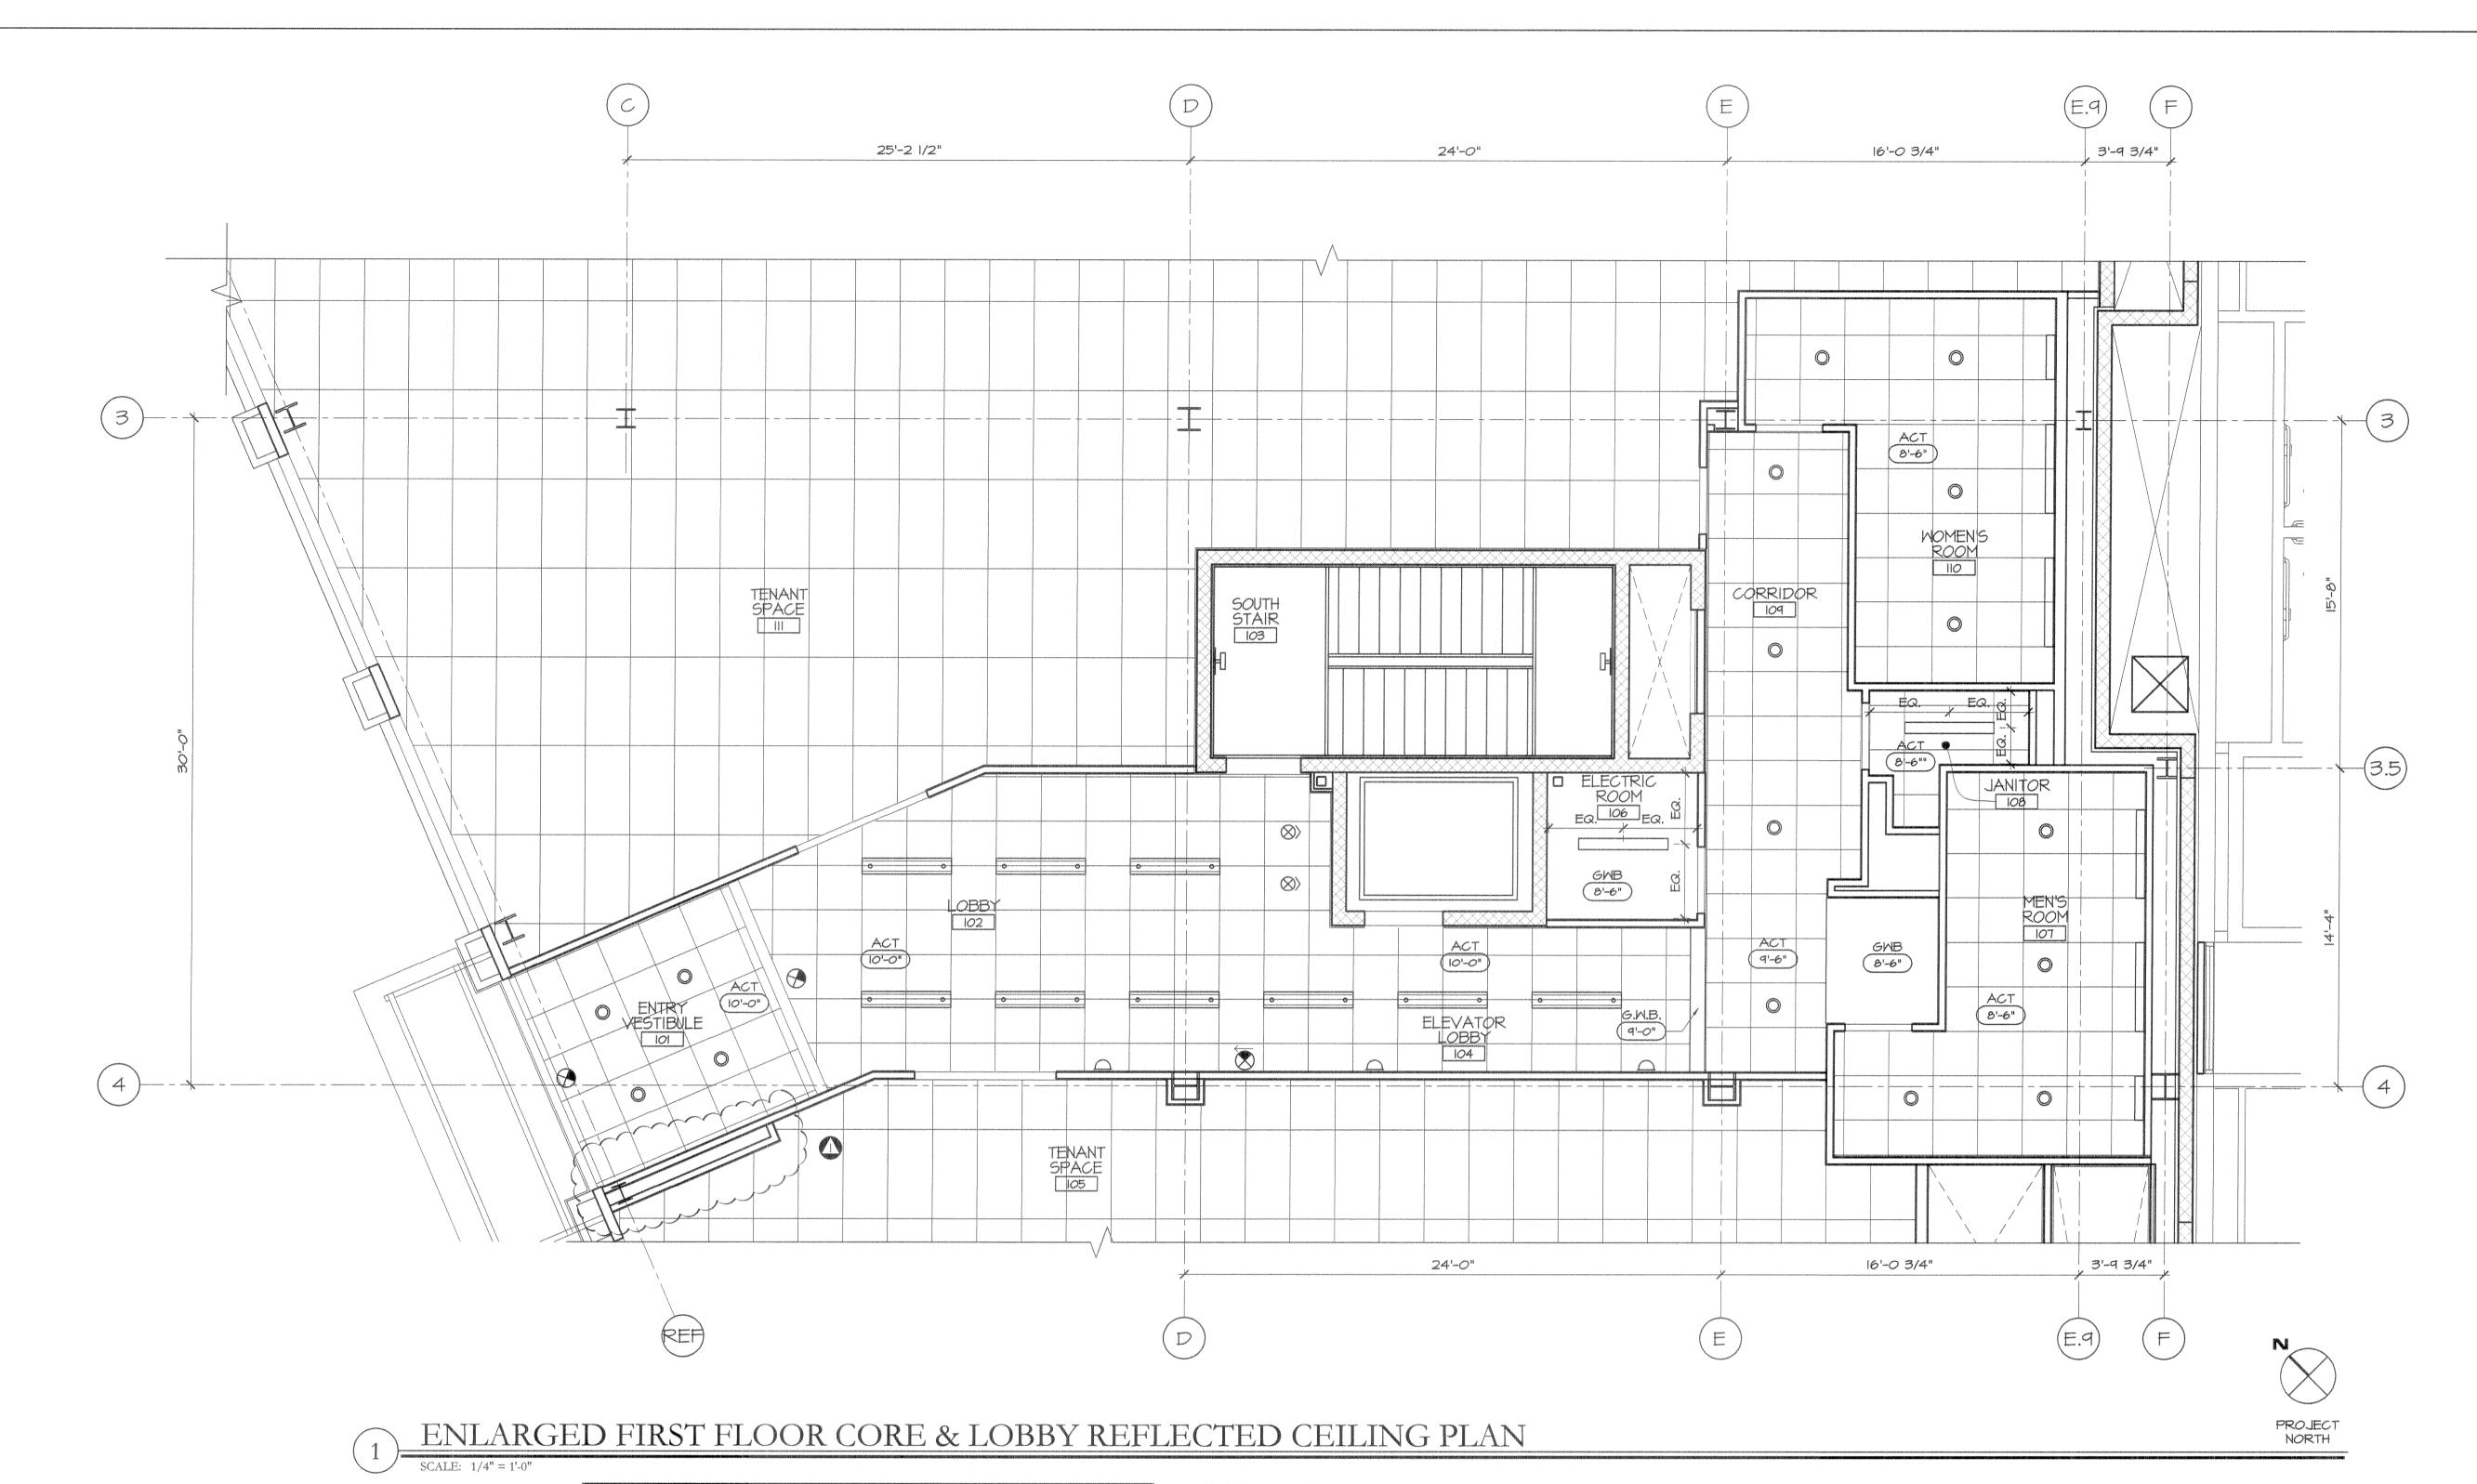

## GENERAL REFLECTED CEILING PLAN NOTES

- I. ALL CONDUIT, MC CABLE, TEL/DATA WIRING, etc. LOCATED IN EXPOSED CEILING AREAS ARE TO BE MOUNTED, ROUTED AND BUNDLED IN A NEAT AND PROFESSIONAL MANNER, AND COORDINATED WITH ALL MECHANICAL, PLUMBING AND SPRINKLER ITEMS IN EXPOSED CEILING
- I. CENTER ALL SPRINKLER HEADS, LIGHTS & FIXTURES IN CEILING TILES.
- LIGHTS ARE SHOWN TO HELP ESTABLISH RELATIONSHIP OF SPRINKLER HEAD LOCATIONS TO OTHER CEILING ELEMENTS. FOR INFORMATION ON ALL CEILING AND WALL MOUNTED LIGHT FIXTURES AND DEVICES, REFER TO ELECTRICAL DRAWINGS AND CUT SHEETS.
- 3. REFER TO ELECTRICAL DOCUMENTS FOR ADDITIONAL LIGHT FIXTURE INFORMATION.
- 4. LIGHT FIXTURE LOCATIONS AND QUANTITIES ARE THE RESPONSIBILITY OF THE DESIGN/ BUILD ELECTRICAL ENGINEER. ENGINEER TO ENSURE THAT THE LIGHTING LEVELS MEET ALL APPLICABLE CODES.
- 5. LIGHT FIXTURES SHALL BE LOCATED IN THE CENTER OF THE STAIR LANDINGS.
- 6. LIGHT FIXTURES IN RATED CEILING ASSEMBLY REQUIRE 5/8" RATED ACOUSTICAL MATERIAL BOX ABOVE CEILING.
- 7. ALL FIXTURES TO BE SUSPENDED AND STABILIZED PER UL#216
- 8. AIR DUCTS REQUIRE DAMPERS

REFLECTED CEILING LEGEND			
SYMBOL	DESCRIPTION	SYMBOL	DESCRIPTION
terroconsisting developments from construction and constr	WALL SCONCE LIGHT FIXTURE		FLUORESCENT STRIP FIXTURE
Lauren	WALL SCONCE FLUORESCENT LIGHT FIXTURE	0-1	WALL MOUNTED EXTERIOR LIGHT FIXTURE
	DECORATIVE CEILING MOUNTED LIGHT FIXTURE	8	EXIT LIGHT (EXACT LOCATION TO BE DETERMINED BY ELECTRICAL ENGINEER)
0	RECESSED FLUORESCENT LIGHT FIXTURE	[6]	EXHAUST FAN
$\widehat{\otimes}$	RECESSED FLUORESCENT WALL WASHER		ACCESS PANEL TO CEILING FIRE DAMPERS
O O	PENDANT MOUNT FLUORESCENT FIXTURE	9	JUNCTION BOX
	24" × 48" RECESSED FLUORESCENT FIXTURE		ELECTRIC POWER PANEL
	24" × 24" RECESSED FLUORESCENT FIXTURE		SUPPLY DIFFUSER
	8" × 48" RECESSED FLUORESCENT FIXTURE	Section of the sectio	RETURN AIR DIFFUSER

NOTE: REFER TO ELECTRICAL DRAWINGS, LIGHT FIXTURE MANUFACTURERS, AND MODEL NUMBERS