# CIEE

# COUNCIL ON INTERNATIONAL EDUCATIONAL EXCHANGE HEADQUARTERS BUILDING RENOVATIONS

	DRAWING LIST			
DWG	DRAWING	ISSUE	E OF	₹
	DICAWING	MODIFICATION		ION
NUM	TITLE	DATE		
		FOR	:	i
T-1.1	TITLE SHEET			
G -Ø.1	GENERAL NOTES			
G -1.0	CODE REVIEW LIFE SAFETY PLAN			
A -Ø.1	BASEMENT PLAN			
A -1.1	FIRST FLOOR PLAN			
A -2.1	SECOND FLOOR PLANS			
A -4.1	4TH FLOOR PLAN			
A -4.2	4TH FLOOR FURNITURE PLAN			
A -4.3	4TH FLOOR POWER AND DATA PLAN			
A -4.5	4TH FLOOR MECHANICAL PLAN			

#### PROJECT CONTACTS

ARCHITECT:
CHARETTE DESIGN
41 YORK STREET
PORTLAND, MAINE Ø41Ø1
TEL: 207-831-7757
JOHN CHARETTE
EMAIL: JOHN@CHARETTE-DESIGN.COM

CONSTRUCTION MANAGER

CONSIGLI CONSTRUCTION

15 FRANKLIN STREET

PORTLAND, MAINE Ø41Ø1

TEL: 2Ø1-113-3ØØØ

DAYE THOMAS


EMAIL: DTHOMAS@CONSIGLI.COM



## TYPICAL ABBREVIATIONS


DWG DRAWING	FT GA GALV GC GL GWB HGT HM	GENERAL CONTRACTOR GLASS GYPSUM WALL BOARD HEIGHT HOLLOW METAL HORIZONTAL HOUR	PLAS PLBG PLYWD PSI PT	NOT IN CONTRACT NUMBER NOT TO SCALE ON CENTER OVER HEAD PARALLEL PRECAST CONCRETE PERFORATED PERPENDICULAR PLATE PLASTIC LAMINATE PLASTER PLUMBING PLYWOOD POUNDS PER SQUARE INCH PRESSURE TREATED PAINT QUANTITY RISER OF RADIUS RADIUS REFLECTED CEILING PLAN ROOF DRAIN	SUSP SYMM T & B TEL THICK TI T.O. TOJ TOS TYP	STANDARD STEEL STRUCTURAL SUSPENDED SYMMETRICAL THERMOSTAT TOP AND BOTTOM TELEPHONE TEMPERED GLASS THICKNESS TENANT IMPROVEMENTS TOP OF TOP OF JOIST TOP OF STEEL TYPICAL UNDERWRITERS LABORATORIES, INC UNLESS NOTED OTHERWISE VINYL BASE VINYL COMPOSITE TILE VERTICAL VERIFY IN FIELD WIDE OF WEST WOOD
DS DOWN SPOUT DW DISH WASHER						
<u></u>						
DUG DRAWING				ROOF DRAIN		
E EAST	LAM	LAMINATED	REF	REFRIGERATOR	WC	WATER COOLER
		— · · · · · · · — —	REINF	REINFORCED	W/	WITH
EA EACH	LB	POUNDS				
			REQD	REQUIRED	Ш/О	
	LF.	LINEAR FEET				
EJ EXPANSION JOINT					X	EXISTING
	□1.					
		LINEAR FEET	REQD	REQUIRED	W/O	WITHOUT

## LEGEND

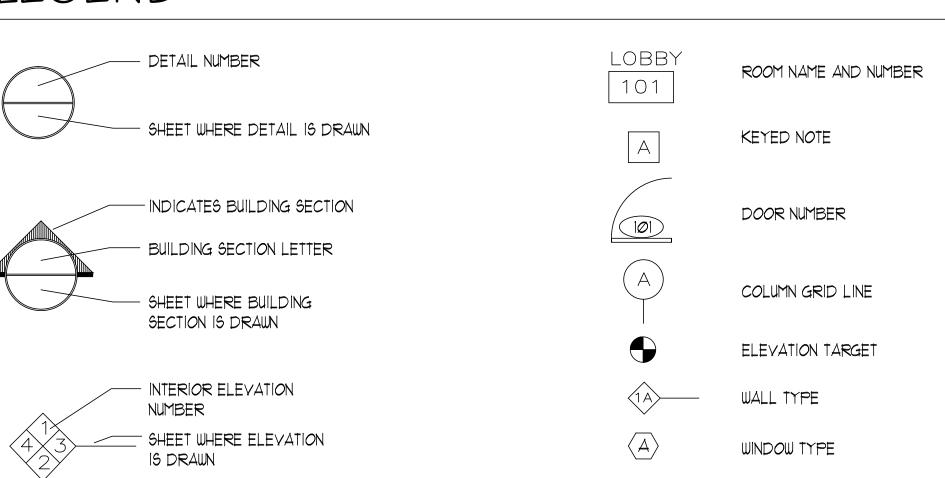



41 YORK STREET
PORTLAND, MAINE 04101
207.831.7757
CHARETTE-DESIGN.COM

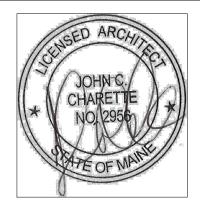

HEADQUARTERS

300 FORE STREET
PORTLAND, MAINE

# DATE DESCRIPTION
REVISIONS

Date Issued 07.23.13
Project Number 13105

Drawing Scale AS NOTED
SHEET NAME

OFFICE INAME

COVER SHEET

JCC

COPYRIGHT: Reuse or reproduction of the contents of this document is not permitted without written permission of CHARETTE DESIGN, LLC

Checked By A0.0