
## NOTES:

1. SEE EO.O FOR LEGEND, ABBREVIATIONS AND GENERAL NOTES.

## **KEYED NOTES:**

(1) CONNECT LIGHTING CIRCUIT TO NEW 1-POLE 20 AMP BREAKER IN EXISTING PANEL P1. FURNISH NEW TO MATCH MANUFACTURER PART NUMBER AND KAIC RATING AS IN PANEL. MARK BREAKER "CORRIDOR AND COMMON ROOM LIGHTS." LOAD IS 0.3 KVA.

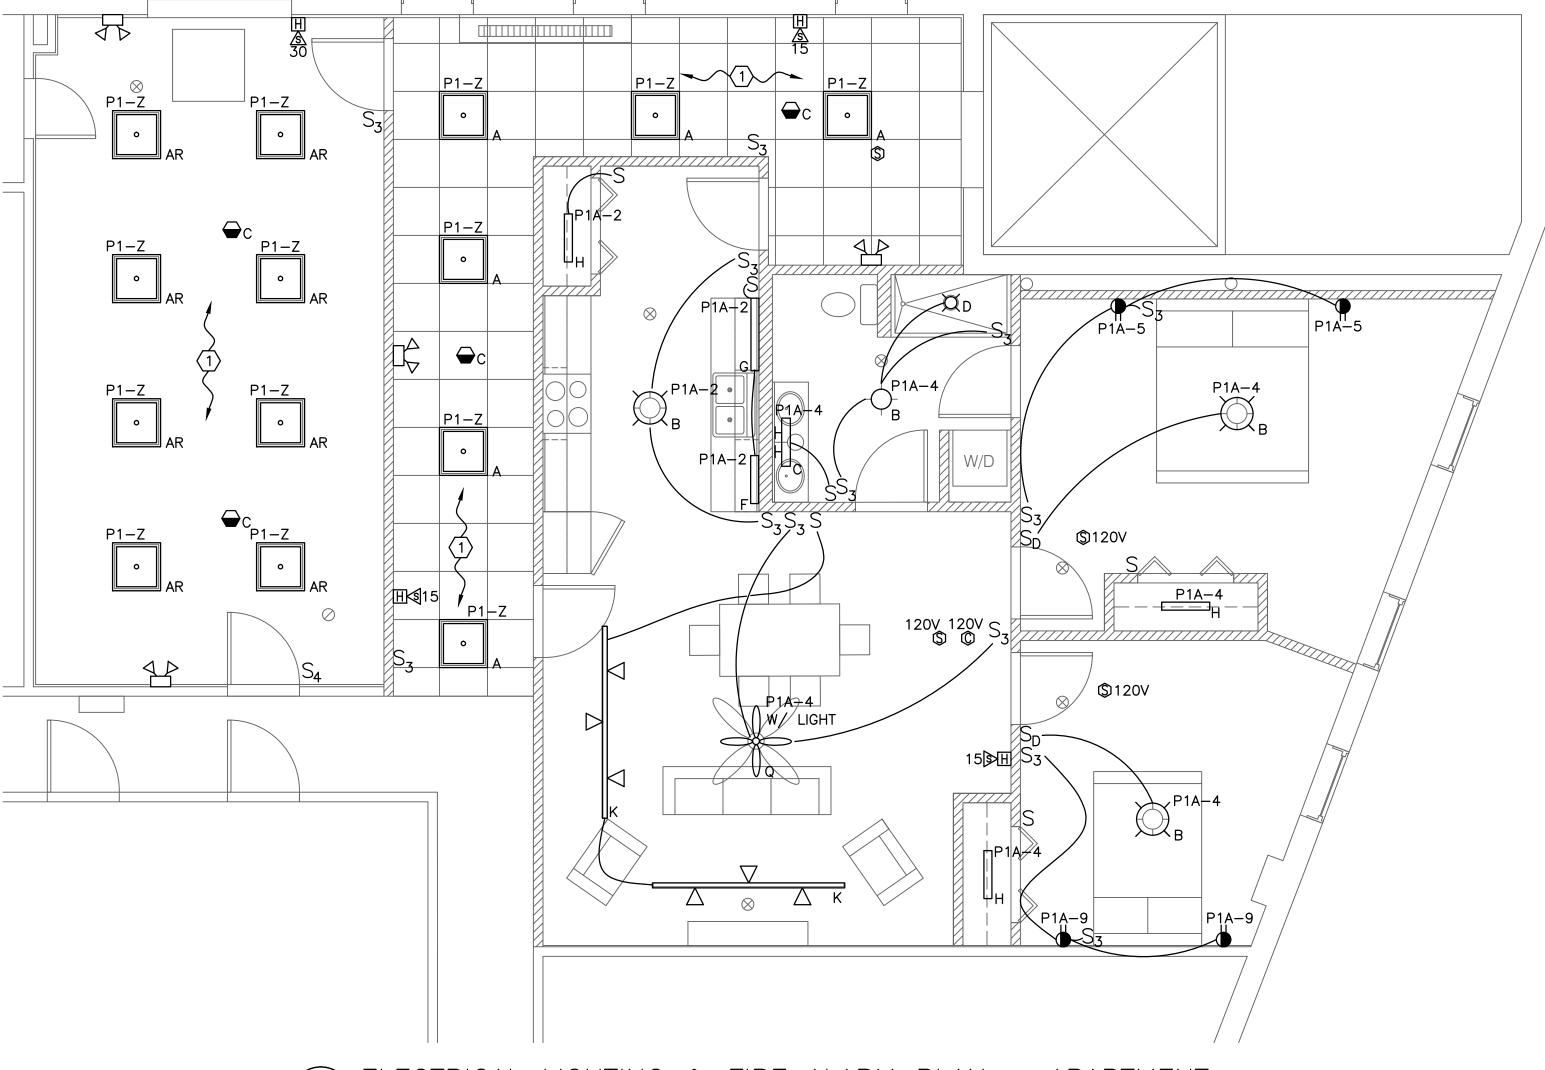

ELECTRICAL LIGHTING & FIRE ALARM PLAN - APARTMENT

SCALE: 1/4" = 1'

**SWIFTCURRENT** 10 Forest Falls Dr. Unit 4B Yarmouth, ME 04096 Tel: (207) 847-9280

LIGHTING SCHEDULE

DUAL-LITE

DUAL-LITE

120V

120V

FINISH.

LED EXIT SIGN EMERGENCY BATTERY UNIT

COMBINATION WITH REMOTE CAPACITY

(2) 1W LED

(2) 1W LED

SURFACE

CEILING SURFACE

MODEL #: EVCU-R-W-D4

**Bild A**PO Box 85
Portland,
04104
207.408.0
evan@bild

1 1 1 1 1 

CONSTRUCTION DOCUMENTS SHEET TITLE

LIGHTING | FIRE ALARM PLAN 
COMMUNITY ROOM | APARTMEN

E DATE
725/
T SCAL 10/3 SHEET

E201