

E

D


C

B

A

GENERAL NOTES:

1. ALL EMERGENCY LIGHTS (☐) SHALL BE CONNECTED TO THE UNSWITCHED PHASE CONDUCTOR OF THE CIRCUIT SERVING THE RESPECTIVE AREA.
2. LOWERCASE LETTER BESIDE EACH APPLICABLE LIGHT FIXTURE REPRESENTS CORRESPONDING SWITCH, SWITCH BANK LOCATED IN MERCHANDISE STORAGE AREA.
3. ELECTRICAL CONTRACTOR TO REUSE EXISTING LIGHTING CIRCUITS WHERE APPLICABLE.

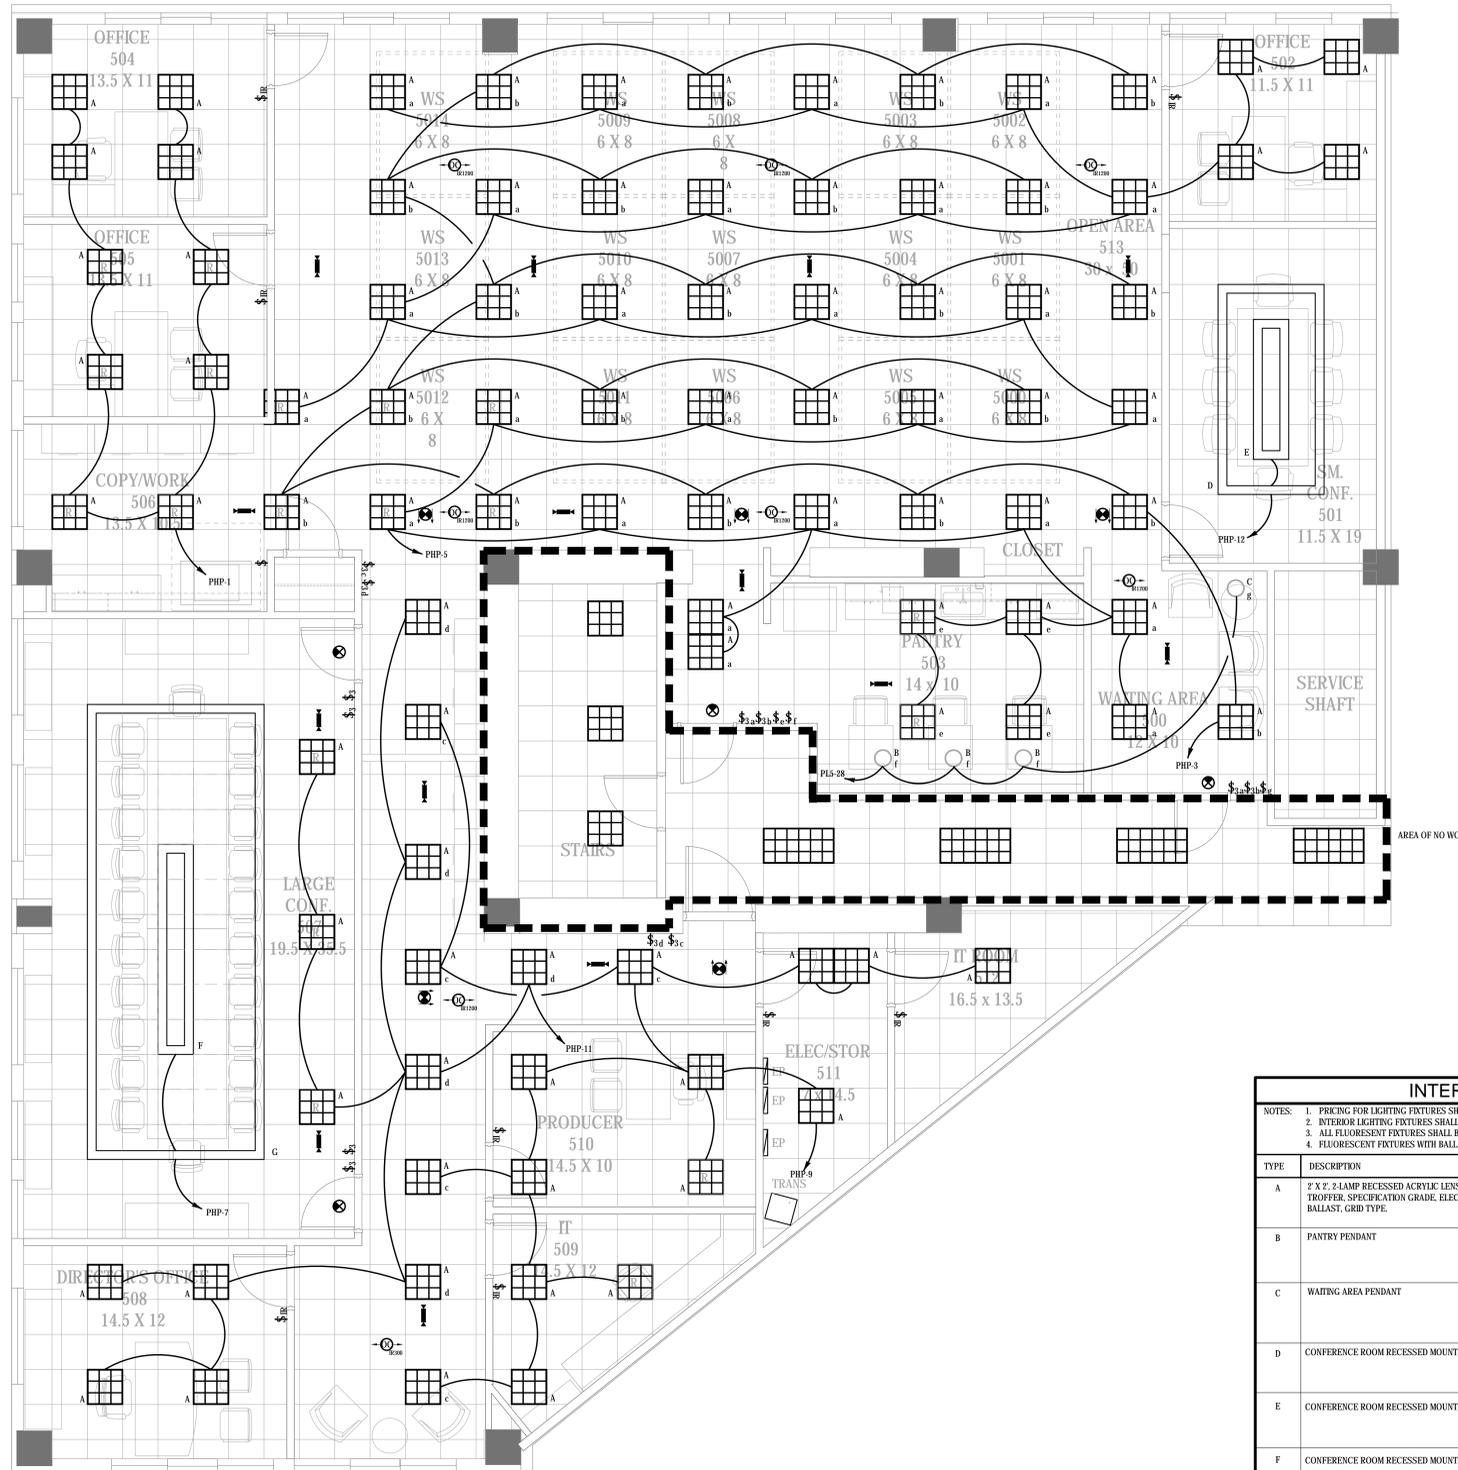

**1** ELECTRICAL LIGHTING FLOOR PLAN  
SCALE: 1/4" = 1'-0"

INTERIOR LIGHTING FIXTURE SCHEDULE				
NOTES: 1. PRICING FOR LIGHTING FIXTURES SHALL BE SEPARATE FROM PRICING FOR LIGHTING CONTROLS (OCC SENSORS, RELAY CONTROLS, DIMMING). 2. INTERIOR LIGHTING FIXTURES SHALL BE PRICED SEPARATELY FROM EXTERIOR LIGHTING FIXTURES. 3. ALL FLUORESCENT FIXTURES SHALL BE EQUIPPED WITH PROGRAM START BALLASTS. MULTI LAMP BALLASTS SHALL BE PARALLEL WIRED. 4. FLUORESCENT FIXTURES WITH BALLASTS AND DOUBLE ENDED LAMPS SHALL HAVE AN INTERNAL DISCONNECT PER NEC REQUIREMENTS.				
TYPE	DESCRIPTION	MANUFACTURER CATALOG NO.	LAMPS	NOTES
A	2' X 2', 2-LAMP RECESSED ACRYLIC LENS TROFFER, SPECIFICATION GRADE, ELECTRONIC BALLAST, GRID TYPE.	METALUX 2P2GAX OR EQUIVALENT	2-FR28/SPX35	GC TO CONFIRM WITH OWNER TO MATCH BUILDING STANDARD FIXTURE
B	PANTRY PENDANT	TOURNE ROUND PENDANT NUE471320	7 1.5 WATT G4 LED	
C	WAITING AREA PENDANT	TOURNE ROUND PENDANT NUE471319	12 1.5 WATT G4 LED	
D	CONFERENCE ROOM RECESSED MOUNT 6' X 12'	SCR 400 90 30 FLK(10X12) W UNV DP 1 MFTB9 OS	LED	
E	CONFERENCE ROOM RECESSED MOUNT 2' X 8'	SCR 400 90 30 FL2X8 W UNV DP 1 MFTB9 OS	LED	
F	CONFERENCE ROOM RECESSED MOUNT 2' X 12'	SCR 400 90 30 FL2X12 W UNV DP 1 MFTB9 OS	LED	
G	CONFERENCE ROOM RECESSED MOUNT 10' X 20'	SCR 400 90 30 FLK(10X20) W UNV DP 1 MFTB9 OS	LED	
☐	LED EXIT SIGN WITH POLYCARBONATE HOUSING, RED LETTERS.	SURELITES LPX 4-R PRESOLUBLE SVS-R A-C WH PHILIPS CLORIDE VERW LITHONIA LQMSW3R	LED	
⚡	COMMERCIAL GRADE 4 VOLT TWIN-HEAD BATTERY LIGHT, NOMINAL 500 LUMEN, SURFACE MOUNTED.	LITHONIA ELM2	LED	

THIS DOCUMENT HAS BEEN PREPARED BY PROGRESSIVE AS AN INSTRUMENT OF SERVICE AND PROGRESSIVE SHALL RETAIN ALL COPYRIGHT, PATENT, TRADEMARK, AND OTHER RESERVED RIGHTS, INCLUDING THE COPYRIGHT THEREIN.