


## NOTE:

- 1. THE PROPOSED ELECTRICAL LAYOUT IS INTENDED TO SHOW THE TENANT REQUIRED POWER LOCATIONS. THIS DOES NOT OMIT THE POWER REQUIRED TO MEET THE STANDARDS OF THE ELECTRICAL CODE.
- 2. ALL DATA RUNS TO RETURN TO SERVER ROOM

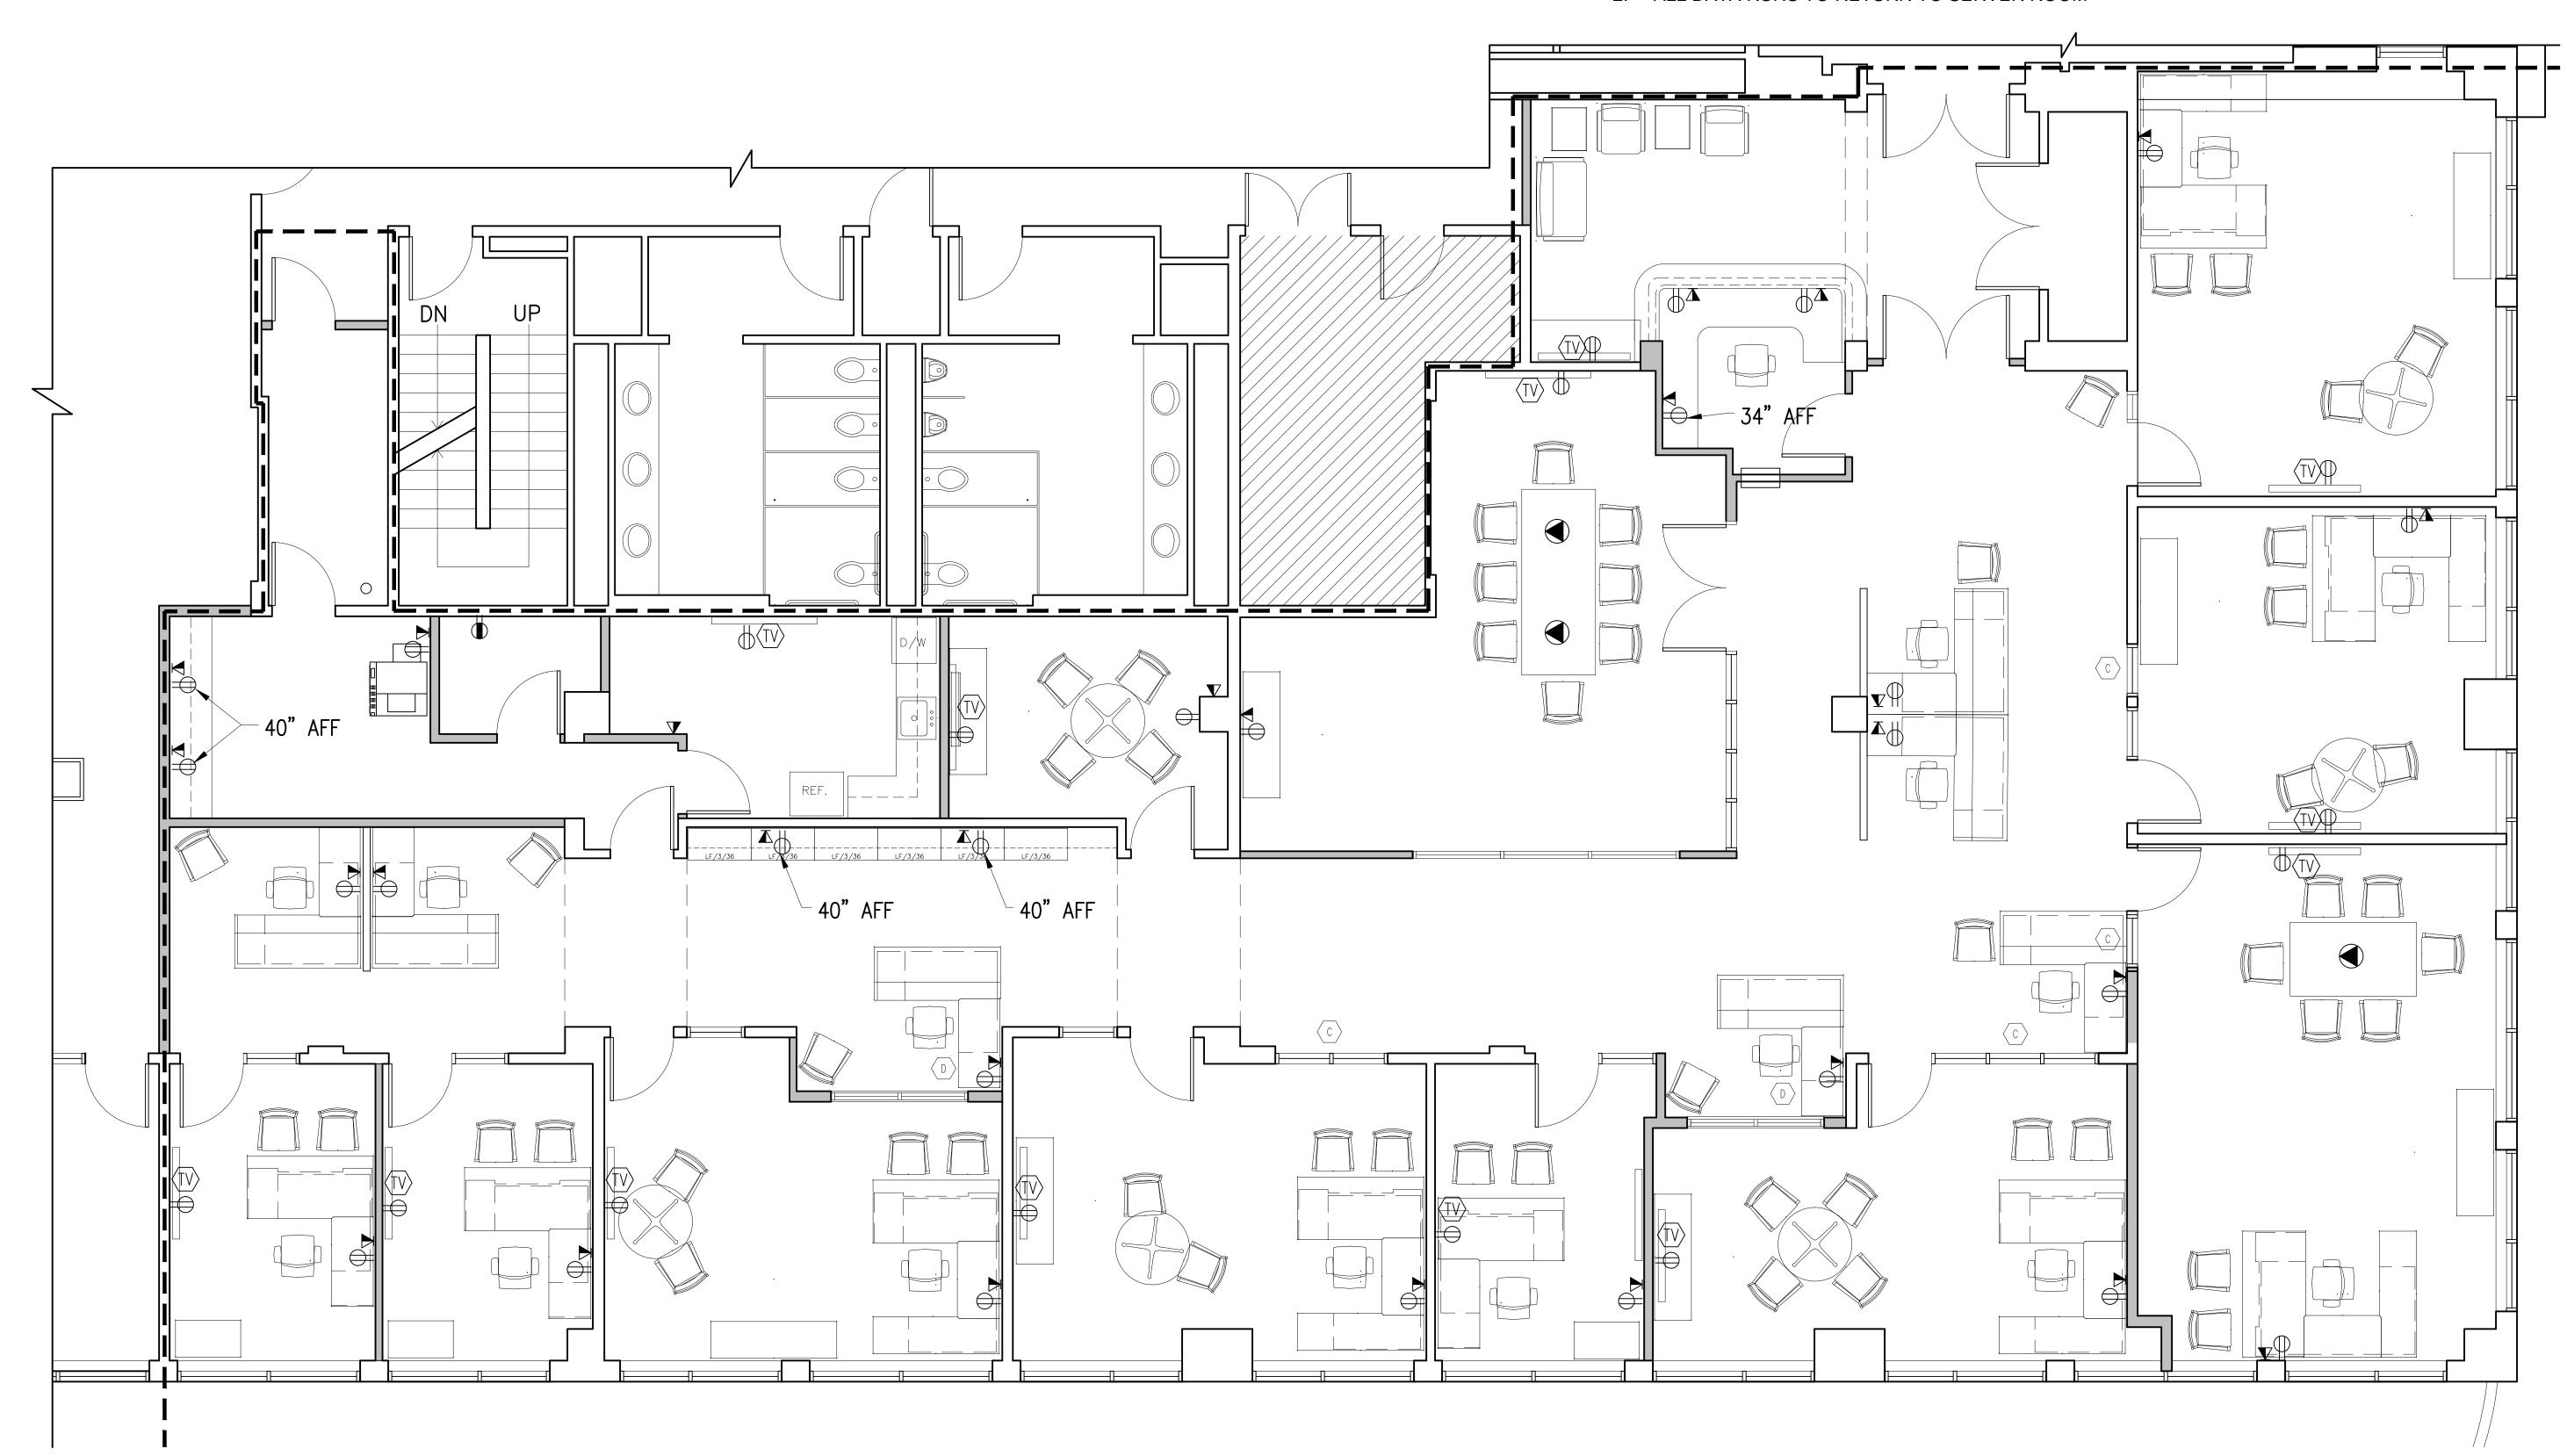

POWER AND DATA PLAN



## Graham Architects

Kennebunkport, Maine T:207.967.8850 F:207.967.8851

www.grahamarchitects.com

PROJECT

2 Portland Square
2 Market Street
7th Floor Renovation
Portland, Maine 04101



## Issued for Construction 02.12.13

CLIENT
CBRE
1 Portland Square
Kennebunkport, ME 04046

CONTRACTOR

STRUCTURAL ENGINEER

INFORMATION

Path: m:\architecture\CBRE\

Issue Date: 02.12.13

Drawn By: DG Checked By: DG

Revision:

1.

POWER AND DATA PLAN

SCALE: 1/4"=1'-0"

©2013 Graham Architects All rights reserved. Information, material, and designs in this document are proprietary to and owned by Graham Architects and may not be disclosed to any third party, reproduced, posted on a global computer information network, or distributed in any way without the written consent from Graham Architects.

E1.1