

POWER WORK NOTES

√NOT USED.

2 CONTRACTOR SHALL PROVIDE JUNCTION BOX AND (3)
CIRCUITS TO CONNECT INTO BASE INFEED OF
FURNITURE SYSTEM. COORDINATE WITH FURNITURE
SUPPLIER AND TENANT'S REPRESENTATIVE FOR FINAL
CONNECTION REQUIREMENTS PRIOR TO ROUGH-IN.

3 EXISTING RELOCATED DEVICES ASSOCIATED WITH SECURITY
SYSTEM. REFER TO ARCHITECTURAL DRAWING SET, SHEET
O-102, LOW VOLTAGE CONTRACTORS SECURITY SYSTEMS
PLAN FOR FURTHER INFORMATION. LOW VOLTAGE
CONTRACTORS CONTACT: DAVID BIENEK 952-278-1078. 4200
WEST 76TH ST., MINNEAPOLIS, MN 55435

4 CONTRACTOR SHALL CONNECT (3) EXISTING RELOCATED
HORN/STROBES AND ALL NEW FIRE ALARM DEVICES TO
EXISTING NOTIFIER FIRE ALARM SYSTEM.

5 EXISTING VAV BOX: CONNECT TO EXISTING 277V CIRCUITING
FED FROM EXISTING PANEL L7B1. REFER TO MECHANICAL
PLAN SHEET M101 FOR CONTROLS AND FURTHER INFO.

6 VAV BOX E: CONTRACTOR SHALL PROVIDE NEW 20A,
1-POLE BRANCH CIRCUIT BREAKER LOCATED AT SLOT *2
IN EXISTING PANEL L7B1 AND CONNECT NEW EQUIPMENT
PER NEC AND MANUFACTURER'S SPECIFICATIONS.

7 CONTRACTOR SHALL CONNECT NEW RECEPTACLE TO
NEAREST EXISTING GENERAL USE RECEPTACLE CIRCUITING
LOCATED AT ADMIN AREA 703.

8 CONTRACTOR SHALL PROVIDE NEW AIPHONE INTERCOM MASTER STATION. COORDINATE WITH ARCHITECTURAL SET SECURITY SYSTEMS SHEET 0-102 PRIOR TO ROUGH-IN. WIRE PER MANUFACTURER'S SPECIFICATIONS.

RSP

RSP Architects, Ltd


1220 Marshall Street NE
Minneapolis
MN 55413-1036

612.677.7100
612.677.7499 fa
www.rsparch.

Minneapolis 612.677.7499 fax www.rsparch.com

PROJECT CONTACT:
Bob Pick, Job Captain 612-677-7245

BENNETT ENGINEERING

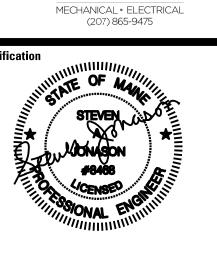

Signature
Steven A. Jonason
Registration No. Expiration Da
8468
Signing Date

Project For



AMPF Project #
17621008028E

AMPF Cost Center #
3071

AMPF Project Name
PORTLAND

TENANT IMPROVEMENT

AMERIPRISE FINANCIAL 2 PORTLAND SQUARE 7TH FLOOR SUITE # 701 PORTLAND, ME 04101

	17021000020
Drawn By	CAT
Checked By	SAJ
Date	9/16/16


NOTICE: The designs shown and described herein including all technical drawings, graphics, and models thereof, are proprietary and cannot be copied, duplicated or commercially exploited, in whole or in part, without express written permission of RSP Architects, Ltd. These are available for limited review and evaluation by clients, consultants, contractors, government agencies, vendors and office personnel only in accordance with this Notice.

© Copyright RSP Architects, Ltd. 2016. All rights reserved.

evisions		
Vo.	Date	Description
	9/16/16	PERMIT BID SET

LEVEL 7 POWER PLAN

E-201

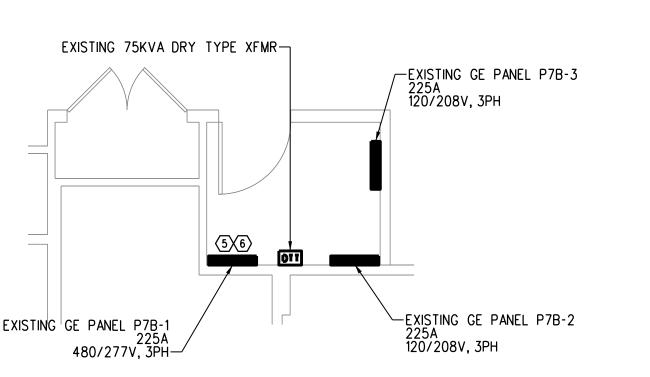

EXISTING ELECTRICAL CLOSET PARTIAL PLAN
SCALE: 1/4"=1'-0"