



## 

## ALL NEW SUPPLY DIFFUSERS SHALL BE 'A' ALL NEW RETURN/TRANSFER GRILLES SHALL BE 'AA'

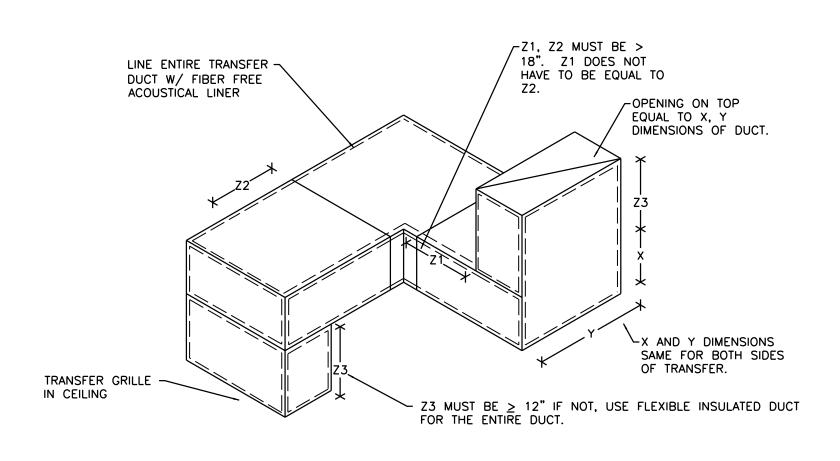

3 TRANSFER DUCT DETAIL (SPEECH BAFFLE)


NO SCALE - FOR ROOMS WITH FINISHED CEILINGS

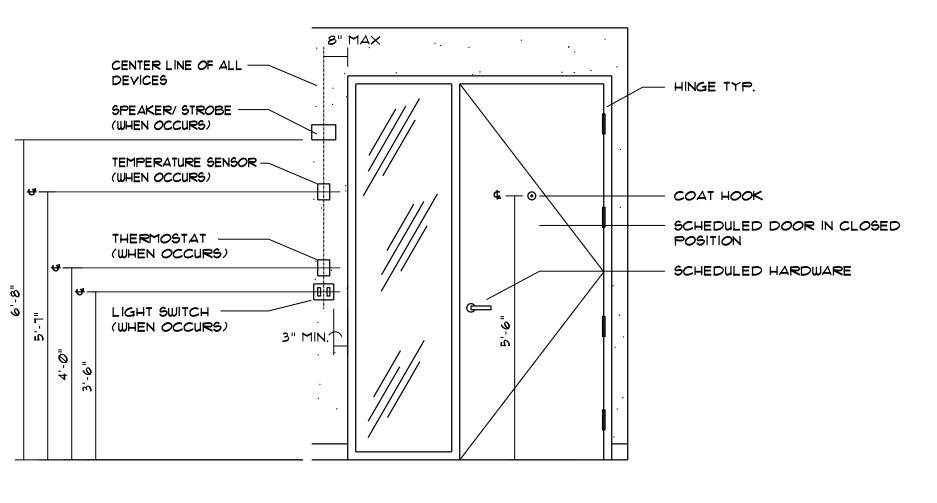

TYPICAL DEVICE MOUNTING HEIGHT LOCATIONS

AT DOORS W/ SIDELIGHTS

1/2"=1'-0"

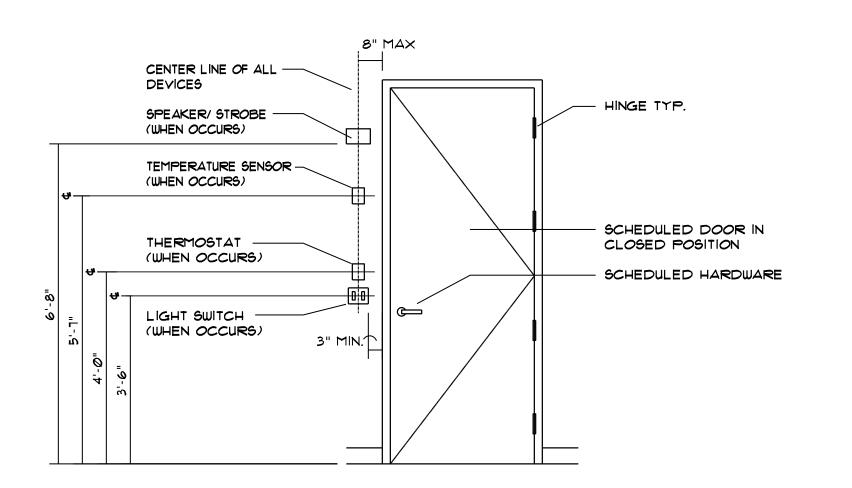

TYPICAL DEVICE MOUNTING HEIGHT LOCATIONS

AT NON-SIDELIGHT DOORS

5 1/2"=1"-0"

RSP

RSP Architects, Ltd


1220 Marshall Street NE
Minneapolis
MN 55413-1036

612.677.7100
612.677.7499 fax
www.rsparch.com

PROJECT CONTACT:
Bob Pick, Job Captain 612-677-7245

Consultants

BENNETT ENGINEERING MECHANICAL • ELECTRICAL (207) 865-9475

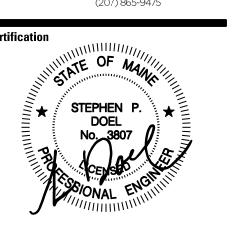

Signature
Stephen P. Doel
Registration No. Expiration Dat
3807

Project For

Signing Date



AMPF Project #
17621008028E

AMPF Cost Center #
3071

AMPF Project Name

TENANT IMPROVEMENT


PORTLAND

AMERIPRISE FINANCIAL 2 PORTLAND SQUARE 7TH FLOOR SUITE # 701 PORTLAND, ME 04101

Project No.	1/621008028
Drawn By	SMF
Checked By	SPD
Date	9/16/16

NOTICE: The designs shown and described herein including all technical drawings, graphics, and models thereof, are proprietary and cannot be copied, duplicated or commercially exploited, in whole or in part, without express written permission of RSP Architects, Ltd. These are available for limited review and evaluation by clients, consultants, contractors, government agencies, vendors and office personnel only in accordance with this Notice.

© Copyright RSP Architects, Ltd. 2016. All rights reserved.

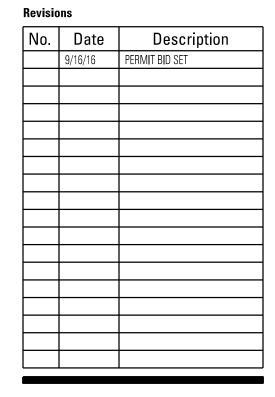

LEVEL 7 MECHANICAL PLANS

M-101