# CUMBERLAND COUNTY CIVIC CENTER RENOVATION

PORTLAND, MAINE



## **VOLUME 1:**

CIVIL DRAWINGS STRUCTURAL DRAWINGS

### VOLUME 2:

ARCHITECTURAL DRAWINGS FOOD SERVICE

#### VOLUME 3:

FIRE PROTECTION
PLUMBING DRAWINGS
MECHANICAL DRAWINGS
ELECTRICAL DRAWINGS

#### PROJECT ADDRESS:

SHEET No.

G0.01


ONE CIVIC CENTER SQUARE PORTLAND, ME 04101

## 

COMM No.

3757.00

CONSTRUCTION DOCUMENTS

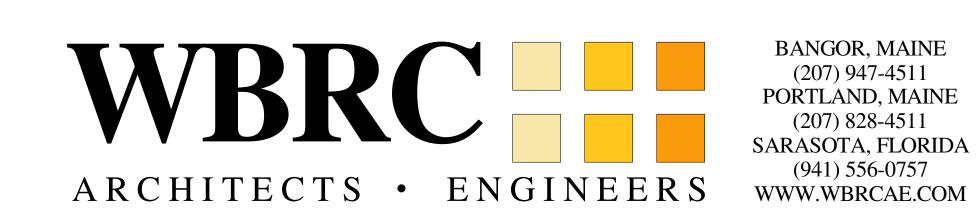





## **VOLUME 1**

**COVER SHEET VOLUME 1** 

DRAWING LIST VOLUME 1

SYMBOLS AND ABBREVIATIONS

**GENERAL DRAWINGS** 

G0.01

G0.02

G0.03

**CIVIL DRAWINGS** GI006 SITE GENERAL NOTES & ABBREVIATIONS 1 OF 1 TOPOGRAPHY SURVEY GR901 **CENTER STREET SITE PHOTOS** GR902 FREE STREET SITE PHOTOS GR903 **SPRING STREET SITE PHOTOS GR904 ELEVATED SITE PHOTOS** PH100 SITE PHASING PLAN - PHASE I PH101 SITE PHASING PLAN - PHASE II CD101 SITE REMOVALS PLAN CD102 SITE LEDGE REMOVALS PLAN CP101 SITE LAYOUT AND MATERIALS PLAN CG101 SITE GRADING AND EROSION CONTROL PLAN CU101 SITE UTILITY PLAN CU301 SITE LARGE SCALE UTILITY PLAN CU302 SITE UTILITY PLAN & PROFILE CU303 SITE UTILITY PLAN & PROFILE LP101 SITE PLANTING PLAN C501 SITE DETAILS C502 SITE DETAILS C503 SITE DETAILS C504 SITE DETAILS C505 SITE DETAILS C506 SITE DETAILS C601 SITE BORING LOGS C602 SITE BORING LOGS STRUCTURAL DRAWINGS STRUCTURAL GENERAL NOTES S0.02 STRUCTURAL TESTS AND SPECIAL INSPECTIONS S2.21A MAIN CONCOURSE LEVEL FOUNDATION PLAN - QUAD A S2.31A MID SUITE LEVEL FLOOR FRAMING PLAN - QUAD A S2.41A **UPPER SUITE LEVEL FLOOR FRAMING PLAN - QUAD A** S2.61A ROOF FRAMING PLAN S2.71A **ENLARGED FRAMING PLANS** S2.03B MECHANICAL LEVEL FOUNDATION PLAN - QUAD C S2.12B **EVENT LEVEL FOUNDATION PLAN - QUAD B** S2.13B **EVENT LEVEL FLOOR FRAMING PLAN - QUAD C** S2.14B **EVENT LEVEL FOUNDATION PLAN - QUAD D** S2.22B LOADING DOCK ROOF FRAMING PLAN - QUAD B S2.23B MAIN CONCOURSE LEVEL FLOOR FRAMING PLAN - QUAD C S2.24B MAIN CONCOURSE LEVEL FLOOR FRAMING PLAN - QUAD D S2.33B SOUTH EAST ENTRY ROOF FRAMING PLAN - QUAD C S2.34B MID SUITE LEVEL FLOOR AND ROOF FRAMING PLANS - QUAD D S2.44B UPPER SUITE LEVEL FLOOR AND ROOF FRAMING PLANS - QUAD D S2.70B **EXISTING ROOF FRAMING PART PLANS** S2.75B ENLARGED PLANS **ENLARGED PLANS & ELEVATIONS ENLARGED PLANS & ELEVATIONS** S2.77B S2.78B **ENLARGED PLANS & ELEVATIONS** TYPICAL CONCRETE FOUNDATION SECTIONS AND DETAILS S3.00 S3.01 TYPICAL CONCRETE FOUNDATION SECTIONS AND DETAILS S3.02 CONCRETE FOUNDATION SECTIONS AND DETAILS S3.03 CONCRETE FOUNDATION SECTIONS AND DETAILS S3.04 CONCRETE FOUNDATION SECTIONS AND DETAILS S3.05 CONCRETE FOUNDATION SECTIONS AND DETAILS S3.06 CONCRETE FOUNDATION SECTIONS AND DETAILS S3.07 **NOT USED** S3.08 **NOT USED** S3.09 **NOT USED** S3.10 FOUNDATION ELEVATIONS S4.00 TYPICAL BOWL DETAILS S4.01 TYPICAL FRAMING DETAILS S4.02 STEEL FLOOR FRAMING SECTIONS AND DETAILS S4.03 STEEL FLOOR FRAMING SECTIONS AND DETAILS S4.04 STEEL FLOOR FRAMING SECTIONS AND DETAILS S4.05 STEEL FLOOR FRAMING SECTIONS AND DETAILS S5.00 TYPICAL STEEL FRAMING SECTIONS AND DETAILS S5.01 STEEL FLOOR FRAMING SECTIONS AND DETAILS S5.02 STEEL FLOOR FRAMING SECTIONS AND DETAILS S5.03 TYPICAL STEEL FRAMING SECTIONS AND DETAILS S5.04 STEEL ROOF FRAMING SECTIONS AND DETAILS S5.05 STEEL ROOF FRAMING SECTIONS AND DETAILS S5.06 STEEL ROOF FRAMING SECTIONS AND DETAILS S5.07 STEEL ROOF FRAMING SECTIONS AND DETAILS S5.08 STEEL ROOF FRAMING SECTIONS AND DETAILS

## VOLUME 2

A6.21A

A6.31A

A6.41A

A6.03B

A6.14B

A6.21B

A6.22B

A6.23B

A6.24B

A6.31B

A6.34B

A6.41B

A6.44B

A7.10

A7.11

A7.13

A7.14

A7.15

A7.16

A7.17

A7.20

A7.30

A7.40

A7.41

A8.11

A8.20

A8.21

A8.22

A8.30

A8.31

A8.32

A8.40

A8.41

A8.42

A8.43

A8.44

A8.50

A9.00

A9.01

A9.10

A9.11

A9.60

A9.61

A9.63

A9.64

A9.65

A9.66

A9.67

A9.68

A9.70

A9.71

A9.72

A9.73

A9.80

A9.81

A9.82

A9.85

A9.86

A9.90

A9.91

A9.92

A9.95

A9.96

A9.97

FS0.1

FS0.2

FS0.3

FS1.1

FS1.2

FS1.3

FS1.4

FS1.5

FS2.1

FS2.2

FS2.3

FS2.4

FS2.5

FS3.1

FS3.2

FS3.3

FS3.4

FS3.5

FS4.1

FS4.2

FS4.3

FS4.4

FS4.5

FS5.1

FS5.2

FS5.3

FS5.4

FOOD SERVICE DRAWINGS

HOOD DRAWINGS

GENERAL DRAW G0.04	INGS COVER SHEET VOLUME 2
G0.05 LSA.00	DRAWING LIST VOLUME 2 MECHANICAL LEVEL - LIFE SAFETY PLAN
LSA.10 LSA.20	EVENT LEVEL - LIFE SAFETY PLAN CONCOURSE LEVEL - LIFE SAFETY PLAN
LSA.30	MID SUITES LEVEL - LIFE SAFETY PLAN
LSA.40 LSB.00	UPPER SUITE LEVEL - LIFE SAFETY PLAN MECH. LEVEL - LIFE SAFETY PLAN - CENTER STAGE
LSB.10 LSB.20	EVENT LEVEL - LIFE SAFETY PLAN - CENTER STAGE CONCOURSE LEVEL - LIFE SAFETY PLAN - CENTER STAGE
LSB.30 LSB.40	MID SUITES LEVEL - LIFE SAFETY PLAN - CENTER STAGE UPPER SUITES LEVEL - LIFE SAFETY PLAN - CENTER STAGE
ARCHITECTURAL	_ DRAWINGS
AD2.21A AD2.31A	CONCOURSE LEVEL REMOVALS PLAN QUAD A MID SUITES LEVEL REMOVALS PLAN QUAD A
AD2.41A AD3.01	UPPER SUITES LEVEL REMOVALS PLAN QUAD A EXTERIOR REMOVAL ELEVATIONS AND DETAILS
AD2.03B AD2.12B	MECHANICAL LEVEL REMOVALS PLAN - PHASE 2 EVENT LEVEL REMOVALS PLAN - QUAD B
AD2.13B AD2.14B	EVENT LEVEL REMOVALS PLAN - QUAD C EVENT LEVEL REMOVALS PLAN - QUAD D
AD2.21B AD2.22B	CONCOURSE LEVEL REMOVALS PLAN - QUAD A CONCOURSE LEVEL REMOVALS PLAN - QUAD B
AD2.23B AD2.24B	CONCOURSE LEVEL REMOVALS PLAN - QUAD C CONCOURSE LEVEL REMOVALS PLAN - QUAD D
AD2.30B	MID SUITES LEVEL REMOVALS PLAN - PHASE 2
AD2.40B AD3.10	UPPER SUITES LEVEL REMOVALS PLAN - PHASE 2 EXTERIOR REMOVAL ELEVATIONS
AD3.11 A2.21A	EXTERIOR REMOVAL ELEVATIONS CONCOURSE LEVEL FLOOR PLAN - PHASE 1
A2.31A A2.41A	MID SUITES LEVEL FLOOR PLAN - PHASE 1 UPPER SUITES LEVEL FLOOR PLAN - PHASE 1
A2.61A A2.00B	ROOF LEVEL PHASE 1 MECHANICAL LEVEL
A2.03B A2.10B	MECHANICAL LEVEL - QUAD C FLOOR PLAN EVENT LEVEL FLOOR PLAN
A2.12B A2.13B	EVENT LEVEL - QUAD B FLOOR PLAN EVENT LEVEL - QUAD C FLOOR PLAN
A2.14B A2.20B	EVENT LEVEL - QUAD D FLOOR PLAN CONCOURSE LEVEL FLOOR PLAN
A2.21B A2.22B	CONCOURSE LEVEL - QUAD A FLOOR PLAN CONCOURSE LEVEL - QUAD B FLOOR PLAN
A2.23B	CONCOURSE LEVEL - QUAD C FLOOR PLAN
A2.24B A2.30B	CONCOURSE LEVEL - QUAD D FLOOR PLAN MID SUITES LEVEL FLOOR PLAN
A2.31B A2.34B	MID SUITES LEVEL - QUAD A FLOOR PLAN MID SUITES LEVEL - QUAD D FLOOR PLAN
A2.40B A2.41B	UPPER SUITES LEVEL FLOOR PLAN UPPER SUITE LEVEL - QUAD A FLOOR PLAN
A2.44B A2.60B	UPPER SUITE LEVEL - QUAD D FLOOR PLAN ROOF PLAN
A2.62B A2.63B	ROOF PLAN - QUAD B ROOF PLAN - QUAD C
A2.64B A3.01	ROOF PLAN - QUAD D BUILDING ELEVATIONS PHASE 1
A3.02 A3.03	BUILDING ELEVATIONS - PHASE 2 BUILDING ELEVATIONS - PHASE 2
A3.10 A3.11	ENLARGED BUILDING ELEVATIONS ENLARGED BUILDING ELEVATIONS
A3.12 A3.13	ENLARGED BUILDING ELEVATIONS ENLARGED BUILDING ELEVATIONS
A3.14 A3.15	ENLARGED BUILDING ELEVATIONS ENLARGED BUILDING ELEVATIONS
A3.20 A3.21	BUILDING SECTIONS BUILDING SECTIONS
A3.22 A3.23	BUILDING SECTIONS BUILDING SECTIONS
A3.24 A3.25	BUILDING SECTIONS BUILDING SECTIONS
A3.30 A3.31	ENLARGED BUILDING SECTIONS ENLARGED BUILDING SECTIONS
A3.32 A3.33	ENLARGED BUILDING SECTIONS ENLARGED BUILDING SECTIONS
A3.34	ENLARGED BUILDING SECTIONS
A3.35 A3.36	ENLARGED BUILDING SECTIONS ENLARGED BUILDING SECTIONS
A3.37 A3.38	ENLARGED BUILDING SECTIONS ENLARGED BUILDING SECTIONS
A3.40 A3.41	WALL SECTIONS WALL SECTIONS
A3.42 A3.43	WALL SECTIONS WALL SECTIONS
A3.44 A3.45	WALL SECTIONS WALL SECTIONS
A3.46 A3.47	WALL SECTIONS WALL SECTIONS
A3.48 A3.49	WALL SECTIONS WALL SECTIONS
A3.50 A3.51	WALL SECTIONS WALL SECTIONS
A4.01 A4.12	ENLARGED PLANS - TICKET LOBBIES ENLARGED PLANS - EVENT LEVEL
A4.13 A4.14	ENLARGED PLANS - EVENT LEVEL ENLARGED PLANS - EVENT LEVEL
A4.15 A4.20	ENLARGED PLAN - HOME TEAM LOCKER ROOM ENLARGED PLANS - LOGE SEATING
A4.21 A4.22	ENLARGED PLANS - CONCOURSE LEVEL ENLARGED PLANS - SW SUITES
A4.23 A4.24	ENLARGED PLANS - NW SUITES ENLARGED PLANS - CONCOURSE RESTROOMS
A4.25 A4.26	ENLARGED PLANS - CONCOURSE - SE GRILL ENLARGED PLANS - CONCOURSE LEVEL
A4.31 A4.41	ENLARGED PLANS ENLARGED PLANS
A4.42	ENLARGED PLANS - BOOTH
A5.00 A5.03	TOILET DETAILS AND ACCESSORIES  INTERIOR ELEVATIONS - MECHANICAL LEVEL  INTERIOR ELEVATIONS - EVENT LEVEL
A5.13 A5.14	INTERIOR ELEVATIONS - EVENT LEVEL INTERIOR ELEVATIONS - EVENT LEVEL
A5.15 A5.16	INTERIOR ELEVATIONS - EVENT LEVEL INTERIOR ELEVATIONS - EVENT LEVEL
A5.17 A5.18	INTERIOR ELEVATIONS - EVENT LEVEL INTERIOR ELEVATIONS - EVENT LEVEL
A5.21 A5.22	INTERIOR ELEVATIONS INTERIOR ELEVATIONS - MAIN CONCOURSE LEVEL
A5.23 A5.24	INTERIOR ELEVATIONS - MAIN CONCOURSE LEVEL INTERIOR ELEVATIONS - MAIN CONCOURSE LEVEL
A5.25 A5.26	INTERIOR ELEVATIONS - MAIN CONCOURSE LEVEL INTERIOR ELEVATIONS - MAIN CONCOURSE LEVEL
A5.31 A5.41	INTERIOR ELEVATIONS INTERIOR ELEVATIONS - UPPER SUITES LEVEL
A5.50	STANDARD MILLWORK DETAILS

LOCKER AND TICKETING MILLWORK DETAILS

## VOLUME 3

CONCOURSE LEVEL REFLECTED CEILING PLAN	GENERAL DRA	AWINGS
MID SUITES LEVEL REFLECTED CEILING PLAN - PHASE 1	G0.06	COVER SHEET VOLUME 3
UPPER SUITES LEVEL REFLECTED CEILING PLAN - PHASE 1	G0.07	DRAWING LIST VOLUME 3
MECHANICAL LEVEL REFLECTED CEILING PLAN - QUAD C		
EVENT LEVEL REFLECTED CEILING PLAN - QUAD B	FIRE PROTEC	
EVENT LEVEL REFLECTED CEILING PLAN - QUAD C EVENT LEVEL REFLECTED CEILING PLAN - QUAD D	FD2.20A FD2.03B	MAIN CONCOURSE FIRE PROTECTION REMOVALS PLAN - PHASE 1 MECHANICAL LEVEL FIRE PROTECTION REMOVALS PLAN - PHASE 2
CONCOURSE LEVEL REFLECTED CEILING PLAN - QUAD A	FD2.10B	EVENT LEVEL FIRE PROTECTION REMOVALS PLAN - PHASE 2
CONCOURSE LEVEL REFLECTED CEILING PLAN - QUAD B	FD2.20B	MAIN CONCOURSE FIRE PROTECTION REMOVALS PLAN - PHASE 2
CONCOURSE LEVEL REFLECTED CEILING PLAN - QUAD C	FP2.20A	MAIN CONCOURSE FIRE PROTECTION PLAN - PHASE 1
CONCOURSE LEVEL REFLECTED CEILING PLAN - QUAD D	FP2.30A	MID SUITES FIRE PROTECTION PLAN - PHASE 1
MID SUITES LEVEL REFLECTED CEILING PLAN - QUAD A	FP2.40A	UPPER SUITES FIRE PROTECTION PLAN - PHASE 1
MID SUITES LEVEL REFLECTED CEILING PLAN - QUAD D	FP2.03B	MECHANICAL LEVEL FIRE PROTECTION PLAN - PHASE 2
UPPER SUITES LEVEL REFLECTED CEILING PLAN - QUAD A UPPER SUITES LEVEL REFLECTED CEILING PLAN - QUAD D	FP2.10B FP2.20B	EVENT LEVEL FIRE PROTECTION PLAN - PHASE 2  MAIN CONCOURSE FIRE PROTECTION PLAN - PHASE 2
STAIR PLANS & SECTIONS	FP2.30B	MID SUITES FIRE PROTECTION PLAN - PHASE 2
ELEVATOR PLANS & SECTIONS	FP2.40B	UPPER SUITES FIRE PROTECTION PLAN - PHASE 2
STAIR PLANS & SECTIONS	FP5.01	FIRE PROTECTION RISER DIAGRAMS & ENLARGED PLANS
STAIR PLANS AND SECTIONS		
ESCALATOR SECTION	PLUMBING	
ELEVATOR PLANS & SECTIONS	PD2.11A	EVENT LEVEL PLUMBING REMOVALS PLAN - QUAD A - PHASE 1
ELEVATOR PLANS & SECTIONS	PD2.21A	CONCOURSE LEVEL PLUMBING REMOVALS PLAN - QUAD A - PHASE 1
STAIR / GUARDRAIL DETAILS HANDRAIL/ GUARDRAIL BOWL KEY PLAN	PD2.02B PD2.031B	EVENT LEVEL UNDERSLAB PLUMBING REMOVALS PLAN - QUAD B - PHASE 2  MECH LEVEL UNDERSLAB PLUMBING REMOVALS PLAN - QUAD C - PHASE 2
BOWL HANDRAIL/GUARDRAIL DETAILS	PD2.032B	MECHANICAL LEVEL PLUMBING REMOVALS PLAN - QUAD C - PHASE 2
RAIL ELEVATIONS	PD2.04B	EVENT LEVEL UNDERSLAB PLUMBING REMOVALS PLAN - QUAD D - PHASE 2
FOUNDATION DETAILS	PD2.11B	EVENT LEVEL PLUMBING REMOVALS PLAN - QUAD A - PHASE 2
FOUNDATION DETAILS	PD2.12B	EVENT LEVEL PLUMBING REMOVALS PLAN - QUAD B - PHASE 2
PLAN DETAILS	PD2.13B	EVENT LEVEL PLUMBING REMOVALS PLAN - QUAD C - PHASE 2
PLAN DETAILS	PD2.14B	EVENT LEVEL PLUMBING REMOVALS PLAN - QUAD D - PHASE 2
PLAN DETAILS SECTION DETAILS	PD2.21B PD2.22B	CONCOURSE LEVEL PLUMBING REMOVALS PLAN - QUAD A - PHASE 2 CONCOURSE LEVEL PLUMBING REMOVALS PLAN - QUAD B - PHASE 2
SECTION DETAILS	PD2.23B	CONCOURSE LEVEL PLUMBING REMOVALS PLAN - QUAD C - PHASE 2
SECTION DETAILS	PD2.24B	CONCOURSE LEVEL PLUMBING REMOVALS PLAN - QUAD D - PHASE 2
ROOF DETAILS	P2.11A	EVENT LEVEL PLUMBING PLAN - QUAD A - PHASE 1
ROOF DETAILS	P2.21A	CONCOURSE LEVEL PLUMBING PLAN - QUAD A - PHASE 1
ROOF DETAILS	P2.31A	MID SUITES LEVEL PLUMBING PLAN - QUAD A - PHASE 1
ROOF DETAILS	P2.41A	UPPER SUITES LEVEL PLUMBING PLAN - QUAD A - PHASE 1
ROOF DETAILS	P2.02B	EVENT LEVEL UNDERSLAB PLUMBING PLAN - QUAD B - PHASE 2
PRECAST CONCRETE SHEET WALL TYPE TYPICAL	P2.031B P2.032B	MECHANICAL LEVEL UNDERSLAB PLUMBING PLAN - QUAD C - PHASE 2 MECHANICAL LEVEL PLUMBING PLAN - QUAD C - PHASE 2
PARTITION FRAMING CRITERIA	P2.04B	EVENT LEVEL UNDERSLAB PLUMBING PLAN - QUAD D - PHASE 2
TYPICAL CEILING DETAILS	P2.11B	EVENT LEVEL PLUMBING PLAN - QUAD A - PHASE 2
TYPICAL CEILING DETAILS	P2.12B	EVENT LEVEL PLUMBING PLAN - QUAD B - PHASE 2
MECHANICAL LEVEL - QUAD C FINISH FLOOR PLAN	P2.13B	EVENT LEVEL PLUMBING PLAN - QUAD C - PHASE 2
EVENT LEVEL - QUAD & FINISH FLOOR PLAN	P2.14B	EVENT LEVEL PLUMBING PLAN - QUAD D - PHASE 2
EVENT LEVEL - QUAD C FINISH FLOOR PLAN EVENT LEVEL - QUAD D FINISH FLOOR PLAN	P2.21B P2.22B	CONCOURSE LEVEL PLUMBING PLAN - QUAD A - PHASE 2 CONCOURSE LEVEL PLUMBING PLAN - QUAD B - PHASE 2
CONCOURSE LEVEL - QUAD A FINISH FLOOR PLAN	P2.23B	CONCOURSE LEVEL PLUMBING PLAN - QUAD C - PHASE 2
CONCOURSE LEVEL - QUAD B FINISH FLOOR PLAN	P2.24B	CONCOURSE LEVEL PLUMBING PLAN - QUAD D - PHASE 2
CONCOURSE LEVEL - QUAD C FINISH FLOOR PLAN	P2.34B	MID SUITES LEVEL PLUMBING PLAN - QUAD D - PHASE 2
CONCOURSE LEVEL - QUAD D FINISH FLOOR PLAN	P2.44B	UPPER SUITES LEVEL PLUMBING PLAN - QUAD D - PHASE 2
MID SUITES LEVEL - QUAD A FINISH FLOOR PLAN	P5.01	PLUMBING DETAILS
ROOM FINISH SCHEDULE	P6.01	PLUMBING SCHEDULES
ROOM FINISH SCHEDULE PHASE 2 ROOM FINISH SCHEDULE PHASE 2 - CONT.	PFS1.0 PFS1.1	ENLARGED CONCESSIONS PLUMBING PLANS ENLARGED COMMISSARY WASTE & VENT PLANS
STANDARD FLOORING TRANSITION DETAILS	PFS1.2	ENLARGED COMMISSARY DOMESTIC WATER & GAS PIPING PLANS
DOOR & FRAME SCHEDULE - PHASE 1	PFS1.3	EVENT LEVEL CO2 OVERALL PLAN
DOOR & FRAME SCHEDULE - PHASE 2		
DOOR & FRAME SCHEDULE - PHASE 2	MECHANICAL	
DOOR DETAILS	M0.01	MECHANICAL LEGEND
DOOR DETAILS WINDOW SCHEDULE - EXTERIOR GLAZING	MD2.03A MD2.03B	MECHANICAL LEVEL MECHANICAL REMOVALS PLAN MECHANICAL LEVEL MECHANICAL REMOVALS PLAN
WINDOW SCHEDULE - EXTERIOR GLAZING WINDOW SCHEDULE - EXTERIOR	MD2.11B	EVENT LEVEL MECHANICAL DEMO PLAN - QUAD A
WINDOW SCHEDULE - INTERIOR	MD2.11B	EVENT LEVEL MECHANICAL DEMO PLAN - QUAD B
WINDOW FRAME DETAILS	MD2.13B	EVENT LEVEL MECHANICAL DEMO PLAN - QUAD C
WINDOW FRAME DETAILS	MD2.14B	EVENT LEVEL MECHANICAL DEMO PLAN - QUAD D
WINDOW FRAME DETAILS	MD2.21B	CONCOURSE LEVEL MECHANICAL DEMO PLAN - QUAD A
OF DRAWINGS	MD2.22B	CONCOURSE LEVEL MECHANICAL DEMO PLAN - QUAD B
CENERAL PECION NOTES	MD2.23B	CONCOURSE LEVEL MECHANICAL DEMO PLAN - QUAD C
GENERAL DESIGN NOTES FOOD SERVICE EVENT LEVEL MIX PLAN	MD2.24B M2.21A	CONCOURSE LEVEL MECHANICAL DEMO PLAN - QUAD D CONCOURSE LEVEL MECHANICAL PLAN - QUAD A PHASE 1
FOOD SERVICE MAIN CONCOURSE MIX PLAN	M2.31A	MIDSUITES LEVEL MECHANICAL LEVEL - QUAD A PHASE 1
EQUIPMENT PLAN AND SCHEDULE	M2.41A	UPPER SUITES LEVEL MECHANICAL PLAN - QUAD A PHASE 1
BUILDING CONDITIONS PLAN	M2.03B	MECHANICAL LEVEL MECHANICAL PLAN
PLUMBING ROUGH-IN PLAN	M2.11B	EVENT LEVEL MECHANICAL PLAN - QUAD A
ELECTRICAL ROUGH-IN PLAN	M2.12B	EVENT LEVEL MECHANICAL PLAN - QUAD B
VENTILATION ROUGH-IN PLAN EQUIPMENT PLAN AND SCHEDULE	M2.13B M2.14B	EVENT LEVEL MECHANICAL PLAN - QUAD C EVENT LEVEL MECHANICAL PLAN - QUAD D
BUILDING CONDITIONS PLAN	M2.21B	CONCOURSE LEVEL MECHANICAL PLAN - QUAD A
PLUMBING ROUGH-IN PLAN	M2.22B	CONCOURSE LEVEL MECHANICAL PLAN - QUAD A CONCOURSE LEVEL MECHANICAL PLAN - QUAD B
ELECTRICAL ROUGN-IN PLAN	M2.23B	CONCOURSE LEVEL MECHANICAL PLAN - QUAD C
VENTILATION ROUGH-IN PLAN	M2.24B	CONCOURSE LEVEL MECHANICAL PLAN - QUAD D
EQUIPMENT PLAN AND SCHEDULE	M2.31B	MIDSUITES LEVEL MECHANICAL PLAN - QUAD A
BUILDING CONDITIONS PLAN	M2.32B	NOT USED
PLUMBING ROUGH-IN PLAN ELECTRICAL ROUGN-IN PLAN	M2.33B M2.34B	MIDSUITES LEVEL MECHANICAL PLAN - QUAD C MIDSUITES LEVEL MECHANICAL PLAN - QUAD D
VENTILATION ROUGH-IN PLAN	M2.34B M2.41B	FAN ROOM MECHANICAL PLAN - QUAD D
EQUIPMENT PLAN AND SCHEDULE	M2.42B	FAN ROOM MECHANICAL PLAN - QUAD B
BUILDING CONDITIONS PLAN	M2.43B	FAN ROOM MECHANICAL PLAN - QUAD C
PLUMBING ROUGH-IN PLAN	M2.44B	FAN ROOM MECHANICAL PLAN - QUAD D
ELECTRICAL ROUGN-IN PLAN	M4.01	MECHANICAL ENLARGED PLAN
VENTILATION ROUGH-IN PLAN	M5.01	MECHANICAL SCHEMATICS
HOOD DRAWINGS HOOD DRAWINGS	M5.02 M5.03	MECHANICAL SCHEMATIC MECHANICAL DETAILS
HOOD DRAWINGS HOOD DRAWINGS	M6.01	MECHANICAL SCHEDULES

MECHANICAL SCHEDULES

MECHANICAL SMOKE CONTROL SCHEMATICS

#### SINK COMBS DETHLEFS

Suite 100

303 308 0200 475 Lincoln Street, FAX 308 0222 Denver, Colorado 80203

E2.31A	MID SUITES LEVEL POWER PLAN - QUAD A
E2.41A	UPPER SUITES LEVEL POWER PLAN - QUAD A
E3.21A E3.31A	CONCOURSE LEVEL SYSTEMS PLAN - QUAD A MID SUITES LEVEL SYSTEMS PLAN - QUAD A
E3.41A	UPPER SUITES LEVEL SYSTEMS PLAN - QUAD A
E4.01A	ENLARGED ELECTRICAL PLANS
ED.03B	MECHANICAL LEVEL ELECTRICAL DEMO PLAN
ED.11B	EVENT LEVEL DEMO PLAN - QUAD R
ED.12B ED.13B	EVENT LEVEL DEMO PLAN - QUAD B EVENT LEVEL DEMO PLAN - QUAD C
ED.14B	EVENT LEVEL DEMO PLAN - QUAD D
ED.21B	CONCOURSE LEVEL DEMO PLAN - QUAD A
ED.22B	CONCOURSE LEVEL DEMO PLAN - QUAD B
ED.23B	CONCOURSE LEVEL DEMO PLAN - QUAD C
ED.24B ED.50B	CONCOURSE LEVEL DEMO PLAN - QUAD D CATWALK LEVEL DEMO PLAN
E1.03B	MECHANICAL LEVEL LIGHTING PLAN
E1.11B	EVENT LEVEL LIGHTING PLAN - QUAD A
E1.12B	EVENT LEVEL LIGHTING PLAN - QUAD B
E1.13B E1.14B	EVENT LEVEL LIGHTING PLAN - QUAD C EVENT LEVEL LIGHTING PLAN - QUAD D
E1.21B	CONCOURSE LEVEL LIGHTING PLAN - QUAD A
E1.22B	CONCOURSE LEVEL LIGHTING PLAN - QUAD B
E1.23B	CONCOURSE LEVEL LIGHTING PLAN - QUAD C
E1.24B	CONCOURSE LEVEL LIGHTING PLAN - QUAD D
E1.31B E1.34B	MID SUITES LEVEL LIGHTING PLAN - QUAD A MID SUITES LEVEL LIGHTING PLAN - QUAD D
E1.41B	UPPER SUITES LEVEL LIGHTING PLAN - QUAD A
E1.42B	UPPER SUITES LEVEL LIGHTING PLAN - QUAD B
E1.43B	UPPER SUITES LEVEL LIGHTING PLAN - QUAD C
E1.44B	UPPER SUITES LEVEL LIGHTING PLAN - QUAD D
E1.50B E2.03B	CATWALK LEVEL LIGHTING PLAN MECHANICAL LEVEL POWER PLAN
E2.11B	EVENT LEVEL POWER PLAN - QUAD A
E2.12B	EVENT LEVEL POWER PLAN - QUAD B
E2.13B	EVENT LEVEL POWER PLAN - QUAD C
E2.14B E2.21B	EVENT LEVEL POWER PLAN - QUAD D CONCOURSE LEVEL POWER PLAN - QUAD A
E2.22B	CONCOURSE LEVEL POWER PLAN - QUAD B
E2.23B	CONCOURSE LEVEL POWER PLAN - QUAD C
E2.24B	CONCOURSE LEVEL POWER PLAN - QUAD D
E2.31B E2.32B	MID SUITES LEVEL POWER PLAN - QUAD A MID SUITES LEVEL POWER PLAN - QUAD B
E2.33B	MID SUITES LEVEL POWER PLAN - QUAD B
E2.34B	MID SUITES LEVEL POWER PLAN - QUAD D
E2.41B	UPPER SUITES LEVEL POWER PLAN - QUAD A
E2.44B	UPPER SUITES LEVEL POWER PLAN - QUAD D
E2.51B E2.52B	CATWALK LEVEL POWER PLAN - QUAD A CATWALK LEVEL POWER PLAN - QUAD B
E2.53B	CATWALK LEVEL POWER PLAN - QUAD C
E2.54B	CATWALK LEVEL POWER PLAN - QUAD D
E3.03B	MECHANICAL LEVEL SYSTEMS PLAN
E3.12B	EVENT LEVEL SYSTEMS PLAN - QUAD B
E3.13B E3.14B	EVENT LEVEL SYSTEMS PLAN - QUAD C EVENT LEVEL SYSTEMS PLAN - QUAD D
E3.21B	CONCOURSE LEVEL SYSTEMS PLAN - QUAD A
E3.22B	CONCOURSE LEVEL SYSTEMS PLAN - QUAD B
E3.23B	CONCOURSE LEVEL SYSTEMS PLAN - QUAD C
E3.24B E3.34B	CONCOURSE LEVEL SYSTEMS PLAN - QUAD D MID SUITES LEVEL SYSTEMS PLAN - QUAD D
E3.41B	UPPER SUITES LEVEL SYSTEMS PLAN - QUAD A
E3.44B	UPPER SUITES LEVEL SYSTEMS PLAN - QUAD D
E3.50B	CATWALK LEVEL SYSTEMS PLAN
E4.01B E4.02B	ENLARGED ELECTRICAL PLANS ENLARGED ELECTRICAL PLANS
E5.01	ELECTRICAL DETAILS
E5.02	ELECTRICAL DETAILS
E5.03	ELECTRICAL DETAILS
E5.04	ELECTRICAL DETAILS PANELBOARD SCHEDULES
E6.01A E6.01B	PANELBOARD SCHEDULES PANELBOARD SCHEDULES
E6.02B	PANELBOARD SCHEDULES
E6.03B	PANELBOARD SCHEDULES
E6.04B	PANELBOARD SCHEDULES
E6.05B E6.06B	PANELBOARD SCHEDULES PANELBOARD SCHEDULES
E6.07B	PANELBOARD SCHEDULES
FA.03	MECHANICAL LEVEL FIRE ALARM PLAN - QUAD C
FA.12B	
EV 40D	EVENT LEVEL FIRE ALARM PLAN - QUAD B
FA.13B FA 14B	EVENT LEVEL FIRE ALARM PLAN - QUAD C
FA.13B FA.14B FA.21B	
FA.14B	EVENT LEVEL FIRE ALARM PLAN - QUAD C EVENT LEVEL FIRE ALARM PLAN - QUAD D
FA.14B FA.21B FA.22B FA.23B	EVENT LEVEL FIRE ALARM PLAN - QUAD C EVENT LEVEL FIRE ALARM PLAN - QUAD D CONCOURSE LEVEL FIRE ALARM PLAN - QUAD A CONCOURSE LEVEL FIRE ALARM PLAN - QUAD B CONCOURSE LEVEL FIRE ALARM PLAN - QUAD C
FA.14B FA.21B FA.22B FA.23B FA.24B	EVENT LEVEL FIRE ALARM PLAN - QUAD C EVENT LEVEL FIRE ALARM PLAN - QUAD D CONCOURSE LEVEL FIRE ALARM PLAN - QUAD A CONCOURSE LEVEL FIRE ALARM PLAN - QUAD B CONCOURSE LEVEL FIRE ALARM PLAN - QUAD C CONCOURSE LEVEL FIRE ALARM PLAN - QUAD D
FA.14B FA.21B FA.22B FA.23B FA.24B FA.31B	EVENT LEVEL FIRE ALARM PLAN - QUAD C EVENT LEVEL FIRE ALARM PLAN - QUAD D CONCOURSE LEVEL FIRE ALARM PLAN - QUAD A CONCOURSE LEVEL FIRE ALARM PLAN - QUAD B CONCOURSE LEVEL FIRE ALARM PLAN - QUAD C CONCOURSE LEVEL FIRE ALARM PLAN - QUAD D MID SUITES LEVEL FIRE ALARM PLAN - QUAD A
FA.14B FA.21B FA.22B FA.23B FA.24B	EVENT LEVEL FIRE ALARM PLAN - QUAD C EVENT LEVEL FIRE ALARM PLAN - QUAD D CONCOURSE LEVEL FIRE ALARM PLAN - QUAD A CONCOURSE LEVEL FIRE ALARM PLAN - QUAD B CONCOURSE LEVEL FIRE ALARM PLAN - QUAD C CONCOURSE LEVEL FIRE ALARM PLAN - QUAD D
FA.14B FA.21B FA.22B FA.23B FA.24B FA.31B FA.34B FA.41B FA.44B	EVENT LEVEL FIRE ALARM PLAN - QUAD C EVENT LEVEL FIRE ALARM PLAN - QUAD D CONCOURSE LEVEL FIRE ALARM PLAN - QUAD A CONCOURSE LEVEL FIRE ALARM PLAN - QUAD B CONCOURSE LEVEL FIRE ALARM PLAN - QUAD C CONCOURSE LEVEL FIRE ALARM PLAN - QUAD D MID SUITES LEVEL FIRE ALARM PLAN - QUAD A MID SUITES LEVEL FIRE ALARM PLAN - QUAD D UPPER SUITES LEVEL FIRE ALARM PLAN - QUAD A UPPER SUITES LEVEL FIRE ALARM PLAN - QUAD D
FA.14B FA.21B FA.22B FA.23B FA.24B FA.31B FA.34B FA.41B	EVENT LEVEL FIRE ALARM PLAN - QUAD C EVENT LEVEL FIRE ALARM PLAN - QUAD D CONCOURSE LEVEL FIRE ALARM PLAN - QUAD A CONCOURSE LEVEL FIRE ALARM PLAN - QUAD B CONCOURSE LEVEL FIRE ALARM PLAN - QUAD C CONCOURSE LEVEL FIRE ALARM PLAN - QUAD D MID SUITES LEVEL FIRE ALARM PLAN - QUAD A MID SUITES LEVEL FIRE ALARM PLAN - QUAD D UPPER SUITES LEVEL FIRE ALARM PLAN - QUAD A
FA.14B FA.21B FA.22B FA.23B FA.24B FA.31B FA.34B FA.41B FA.44B	EVENT LEVEL FIRE ALARM PLAN - QUAD C EVENT LEVEL FIRE ALARM PLAN - QUAD D CONCOURSE LEVEL FIRE ALARM PLAN - QUAD A CONCOURSE LEVEL FIRE ALARM PLAN - QUAD B CONCOURSE LEVEL FIRE ALARM PLAN - QUAD C CONCOURSE LEVEL FIRE ALARM PLAN - QUAD D MID SUITES LEVEL FIRE ALARM PLAN - QUAD A MID SUITES LEVEL FIRE ALARM PLAN - QUAD D UPPER SUITES LEVEL FIRE ALARM PLAN - QUAD A UPPER SUITES LEVEL FIRE ALARM PLAN - QUAD D

ELECTRICAL LEGEND, ABBREVIATIONS AND LIGHT FIXTURE SCHEDULE

CONCOURSE LEVEL DEMO PLAN - QUAD A

CONCOURSE LEVEL LIGHTING PLAN - QUAD A

MID SUITES LEVEL LIGHTING PLAN - QUAD A


CONCOURSE LEVEL POWER PLAN - QUAD A

MID SUITES LEVEL POWER PLAN - QUAD A

UPPER SUITES LEVEL LIGHTING PLAN - QUAD A

ELECTRICAL DRAWINGS

E2.31A

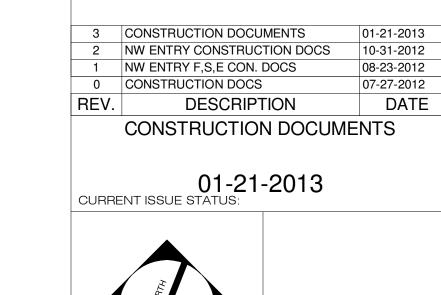



PORTLAND, MAINE 207-828-4511

**CUMBERLAND COUNTY CIVIC CENTER RENOVATION** 

PORTLAND, MAINE

DRAWING LIST VOLUME 1

SHEET TITLE:		
WBRC CAD FILE:	C:\Revit Local\375700 - CCCC Archite	cture_bob.dubois.rvt
PROJECT No.	3757.00	GRAPHIC SCALE: 0"
SCALE:		
PROJECT MANAGE	ER: JRB	SHEET No.
DRAWN BY:	RAD	G0.02

CHECKED BY:

ACOUSTIC AIR CONDITIONING, ASPHALTIC CONCRETE GENERAL CONTRACTOR GF/GI GOVT. FURNISHED/GOVT. INSTALLED R RADIUS, RISER ACCESS DOOR ADD ALT ADDITIVE ALTERNATE GF/CI GOVT. FURNISHED/CONTRACTOR INSTALLED RCP REFLECTED CEILING PLAN ADJ ADJUSTABLE GI GALVANIZED IRON ROOF DRAIN, ROAD AFF ABOVE FINISH FLOOR GOV'T GOVERNMENT RECEP RECEPTACLE REF REFRIGERATOR GPM GALLONS PER MINUTE AHU AIR HANDLING UNIT ALT ALTERNATE GR GRADE REINF REINFORCEMENT GRAN GRANULAR ALUM ALUMINUM REQ'D REQUIRED GRD GROUND ANOD ANODIZE REV REVISION GWB GYPSUM WALLBOARD AP ACCESS PANEL RESINOUS FLOOR APC ACOUSTIC PANEL CEILING GYP GYPSUM RAIN LEADER APPROX APPROXIMATE ROOM HGT HEIGHT ARCH ARCHITECTURAL **ROUGH OPENING** H&V HEATING AND VENTILATING RESILIENT STAIR ACCESSORY ASB ASBESTOS HB HOSE BIB RUBBER TILE ASPH ASPHALT AUTO AUTOMATIC HC HANDICAPPED AWP ACOUSTIC WALL PANEL HCWD HOLLOW CORE WOOD DOOR HDC HANDICAPPED S SOUTH HDW HARDWARE S DISP SOAP DISPENSER BDRM BEDROOM HDWD HARDWOOD S&V STAIN AND VARNISH BIT. CONC BITUMINOUS CONCRETE HM HOLLOW METAL SCONC SEALED CONCRETE BJ BAR JOIST HVAC HEATING, VENTILATING, AND AIR CONDITIONING SCWD SOLID CORE WOOD DOOR BLDG BUILDING SCH SCHEDULE BLK BLOCK SCR SUPPLY CEILING REGISTER SECT SECTION
SF SQUARE FE
SH SINGLE HUI BM BEAM, BENCHMARK IN INSIDE DIAMETER BOT BOTTOM BRD BOARD INCL INCLUSIVE SQUARE FEET SINGLE HUNG INFO INFORMATION BRG BEARING INSUL INSLUATION, INSULATED BS BOTTOM OF STEP INT INTERIOR SIM SIMILAR IWP IMPACT RESISTANT WALL PROTECTION BSMT BASEMENT SLOPE BTWN BETWEEN SPECS SPECIFICATIONS BW BOTTOM OF WALL SQ SQUARE JAN JANITOR CLOSET JCT JUNCTION SQ FT SQUARE FEET SS SERVICE SINK, SERVICE SINK, SANITARY SEWER, STAINLESS STEEL CAB CABINET CAP CAPACITY SSURFACE SOLID SURFACE ST STREET
STA STATION
STD STANDARD CAPACITY CC CENTER TO CENTER KV KILOVOLT CEM CEMENT KW KILOWATT CFM CUBIC FEET PER MINUTE STL STEEL CFS CUBIC FEET PER SECOND LAB LABORATORY STOR STORAGE LAV LAVATORY CORNER GUARD STRUCT STRUCTURAL CAST IRON LBS POUNDS SUP SUPPORT SUSP SUSPEND CIRCULATING LINEAR FEET LFC LINOLEUM FLOOR COVERING LGR LEDGER SV SHEET VINYL SYM SYMMETRICAL CONSTRUCTION JOINT, CONTROL JOINT CLG CEILING CLO CLOSET LOW POINT TOP, TANGENT, THERMOMETER CLR CLEAR LR LIVING ROOM CENTERLINE LIGHT TACK BOARD LWC LIGHT WEIGHT CONCRETE CMU CONCRETE MASONRY UNITS TBA TOILET BATH ACCESSORIES T&B TOP AND BOTTOM CMU G1 GLAZED CMU, ONE SIDE CMU G2 GLAZED CMU, TWO SIDES T&G TONGUE AND GROOVE CO CLEANOUT COL COLUMN T.O.C. TOP OF CONCRETE MACH MACHINE MANUF MANUFACTURER T.O.M. TOP OF MASONRY COMP'T COMPARTMENT MAS MASONRY T.O.S. TOP OF STEEL CONC CONCRETE MATL MATERIAL T.O.W. TOP OF WALL MAX MAXIMUM CONN CONNECTION TEL TELEPHONE CONST CONSTRUCTION MB MARKER BOARD TEMP TEMPERATURE, TEMPORARY CONT CONTINUOUS MC MEDICINE CABINET TERM TERMINAL CPT CARPET CS/CI CONTRACTOR SUPPLIED/ CONTRACTOR INSTALLED MCB METAL CORNER BEAD MECH MECHANICAL THK THICK THRU THROUGH CS/OI CONTRACTOR SUPPLIED/OWNER INSTALLED MIN MINIMUM TP TOILET PARTITION CSK COUNTER SUNK MIR MIRROR TPH TOILET PAPER HOLDER MISC MISCELLANEOUS TRAN TRANSOM CT CERAMIC TILE CTE CONNECT TO EXISTING MM MILLIMETER TS TOP OF STEP, TOP OF SILL MO MASONRY OPENING CTR CENTER TV TELEVISION TYP TYPICAL CUH CABINET UNIT HEATER MR MOISTURE RESISTANT TYPE "X" UL APPROVED GWB MS METAL STRIP MTD MOUNTED DIAMETER MTL METAL U&D UP AND DOWN DRINKING FOUNTAIN DFD DOOR FRAME DIMENSION UC UNDERCUT DH DOUBLE HUNG N NORTH UV UNIT VENTILATOR N.I.C. NOT IN CONTRACT DIA DIAMETER DIM DIMENSION NO NUMBER DN DOWN NOM NOMINAL VB VAPOR BARRIER DTL DETAIL NTS NOT TO SCALE VCT VINYL COMPOSITION TILE DWG DRAWING VERT VERTICAL VEST VESTIBULE OA OVER ALL VIF VERIFY IN FIELD E EAST OB GL OBSCURE GLASS VTR VENT THROUGH ROOF OC ON CENTER EA EACH EL, ELEV ELEVATION OD OUTSIDE DIAMETER ELEC ELECTRIC OPNG OPENING W WEST EMERG EMERGENCY OPP OPPOSITE WAIN WAINSCOT WB RESILIENT WALL BASE
WC WALL COVERING OS/CI OWNER SUPPLIED/CONTRACTOR INSTALLED EPS EXTRUDED POLYSTYRENE EQ EQUAL OS/OI OWNER SUPPLIED/OWNER INSTALLED EQUIP EQUIPMENT OVHD, OH OVERHEAD WITH ETC ETCETERA W/O WITHOUT EW EACH WAY WC WATER CLOSET P-1 PLUMBING FIXTURE TYPE WD WIDTH, WINDOW DIMENSION, WOOD EXIST EXISTING EXP EXPANSION, EXPOSED PART PARTITION WGL WIRE GLASS WP WATERPROOF, WEATHERPROOF
WS WEATHERSTRIPPING
WT WEIGHT EXP JT EXPANSION JOINT PL PLATE EXT EXTERIOR PLAM PLASTIC LAMINATE PLAS PLASTER PLAST PLASTIC WW WELDED WIRE FABRIC FBO FURNISHED BY OTHERS PLYWD PLYWOOD FCO FLOOR CLEAN-OUT PNL PANEL FD FLOOR DRAIN, FOOTING DRAIN PNTD PAINTED FE FIRE EXTINGUISHER POL POLISHED FF FINISH FLOOR PRELIM PRELIMINARY FFE FINISHED FLOOR ELEVATION PSF POUNDS PER SQUARE FOOT PSI POUNDS PER SQUARE INCH FG FINISH GRADE, FIBERGLASS PT PAINT, POINT, PRESSURE TREATED FHC FIRE HOSE CABINET FIG FIGURE PT DISP PAPER TOWEL DISPENSER FIN FINISH PVC POLY VINYL CHLORIDE FO FUEL OIL PVMT PAVEMENT FOF FACE OF FOUNDATION FOR FUEL OIL RETURN FOS FACE OF STUD, FUEL OIL SUPPLY FOUND FOUNDATION FP FIREPROOF FR FRAME, FIRE RESISTANT

GA GAUGE GALV GALVANIZED

AB ANCHOR BOLT, AUGER BORING

ALTERNATE BID ITEM

FS FLOOR SINK

FTG FOOTING

FT FOOT, FEET, FINNED TUBE

FWP FABRIC WALL PANEL


QT QUARRY TILE


NOTE: REFER TO STRUCTURAL, MECHANICAL, AND/OR ELECTRICAL DRAWINGS FOR

ABBREVIATIONS SPECIFIC TO EACH DISCIPLINE.

## SYMBOLS

#### **HATCH PATTERNS**

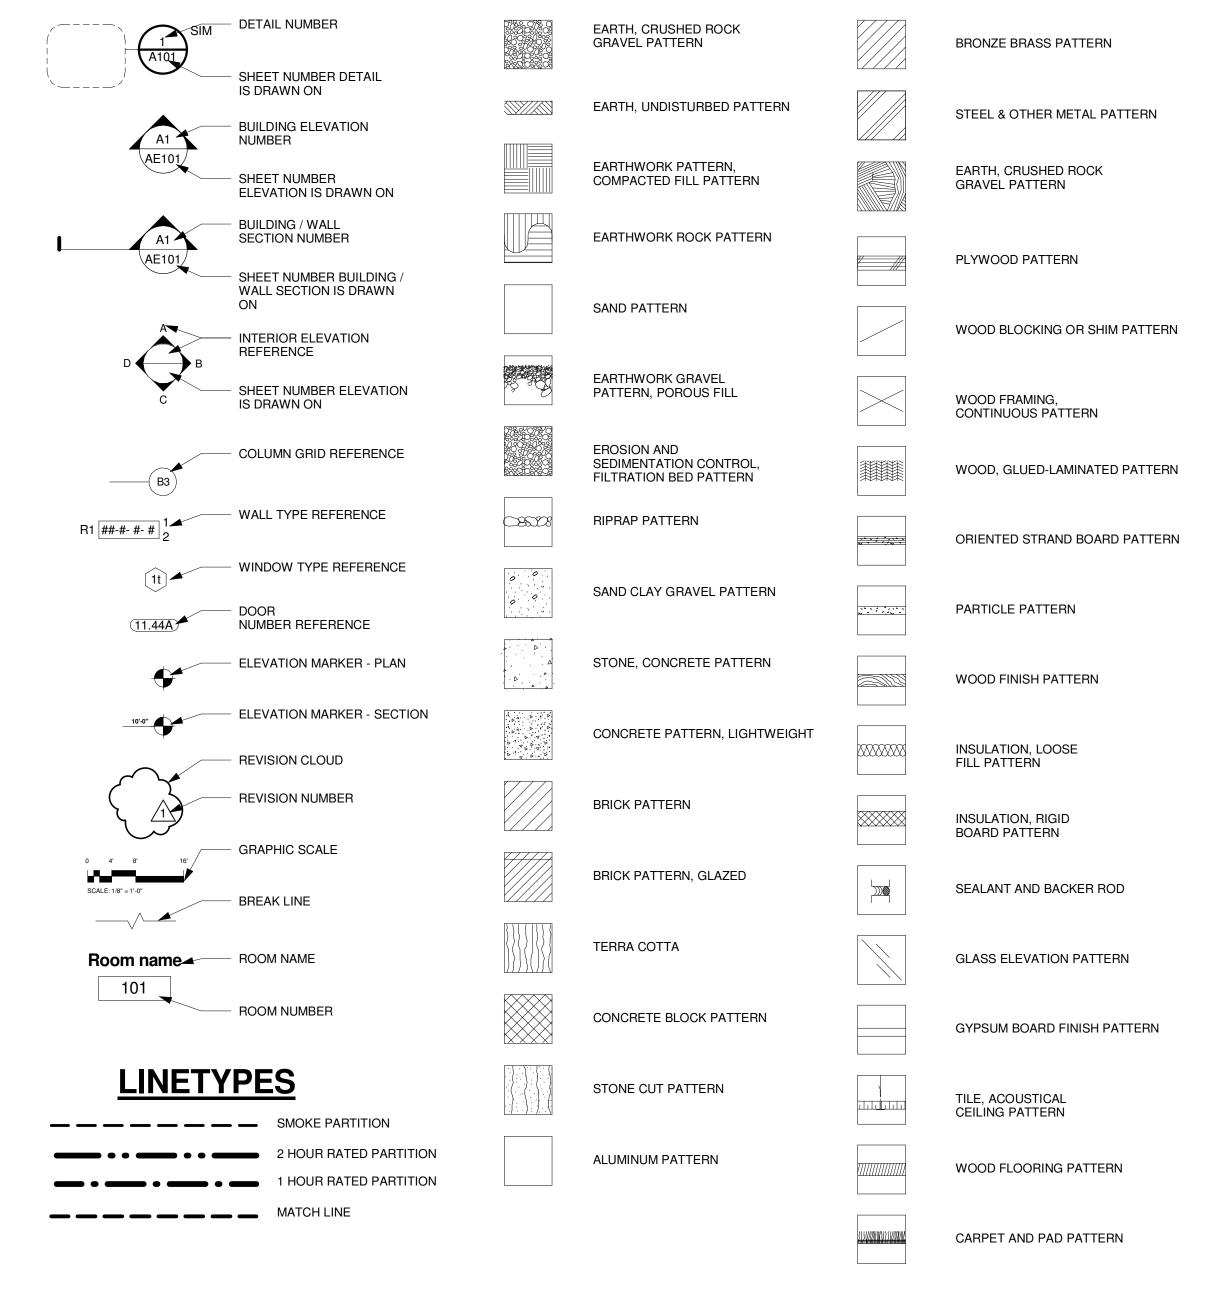

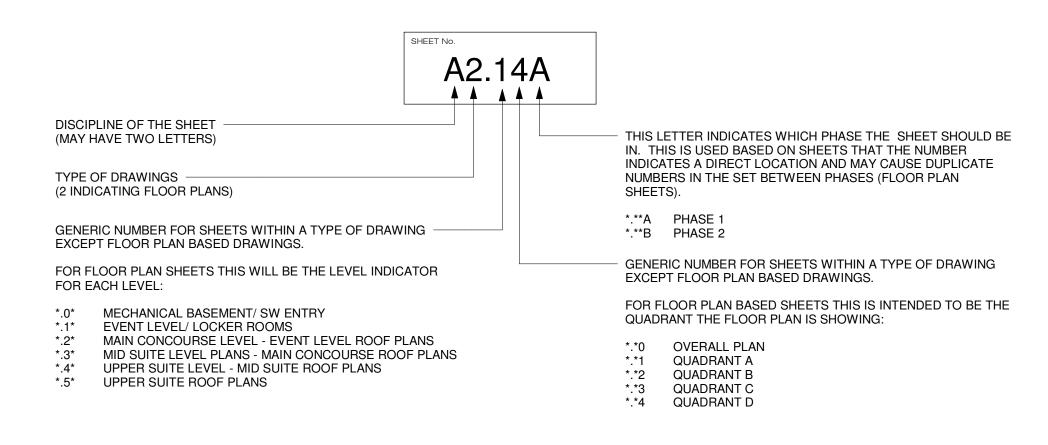

THIS DIAGRAM IS INTENDED TO BE A GENERAL GUIDE TO THE SHEET NUMBERING IN THE PROJECT, SPECIFICALLY THE FLOOR PLAN SHEETS. THIS WILL WORK WITH THE MAJORITY OF THE SHEETS WITHIN THIS SET.

3	CONSTRUCTION DOCUMENTS	01-21-2013		
2	NW ENTRY CONSTRUCTION DOCS	10-31-2012		
1	NW ENTRY F,S,E CON. DOCS	08-23-2012		
0	CONSTRUCTION DOCS	07-27-2012		
REV.	DESCRIPTION	DATE		
CONSTRUCTION DOCUMENTS				

01-21-2013
CURRENT ISSUE STATUS:

PROJECT NORTH

ARCHITECTS • ENGINEERS

WWW.WBRCAE.COM

BANGOR, MAINE 207-947-4511
PORTLAND, MAINE 207-828-4511

CENTER RENOVATION

CENTER RENOVATION

OJECT: PORTLAND, MAINE

SYMBOLS AND ABBREVIATIONS

SHEET TITLE:

WBRC CAD FILE: C:Revit Local/375700 - CCCC Architecture\_bob.dubois.rvt

PROJECT No. 3757.00 GRAPHIC SCALE:

O"

SCALE: As indicated

PROJECT MANAGER: JBB SHEET No.

DRAWN BY:

G0.03