

FLOOR FIRE DAMPER STYLE "B"
NO SCALE

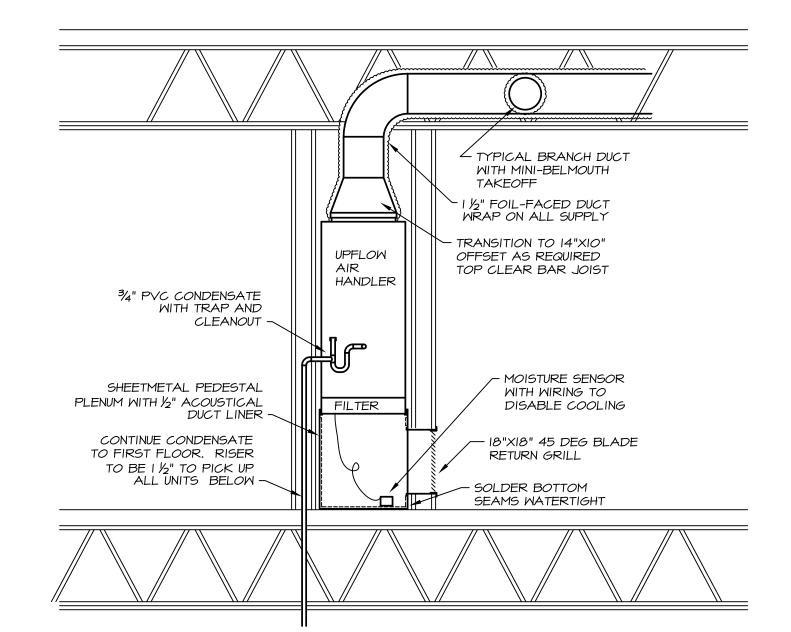


3 SECTION VIEW AIR HANDLER - DUCT IN ONE DIRECTON

SCALE: 1/8" = 1'-0"

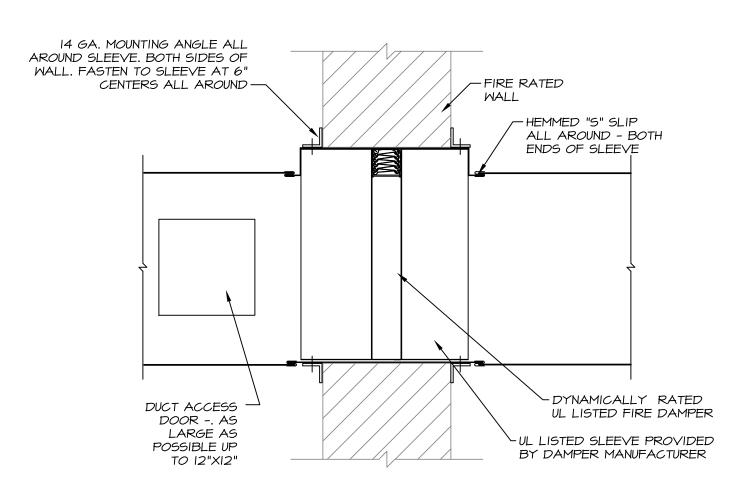


2 MALL FIRE DAMPER STYLE "B

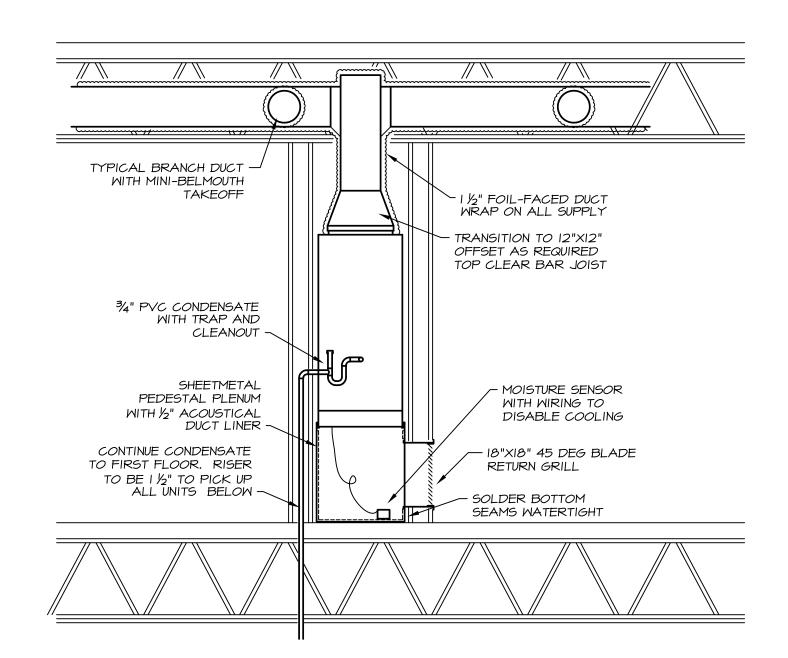

4 SECTION VIEW AIR HANDLER - DUCT IN TWO DIRECTIONS

SCALE: 1/8" = 1'-0"

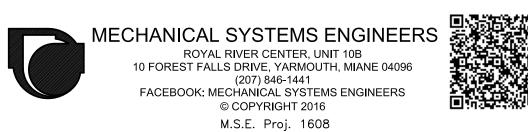



Kurt F. Magnusson 10257

evelopment

York & High Street Portland, Maine

ZEVISION:

SSUED: OR PERMITING 05/16/2016

project architect: KAK
drawn by: KFM

MECHANICAL DETAILS

sheet number: