

BAXTER ACADEMY

PORTLAND, MAINE

Job No. 2012-190
STATE PERMIT PACKAGE - 12/12/12
UPDATE 04-09-13

Project Architect & Consultants

ARCHITECT
Richard Renner | Architects
35 Pleasant Street
Portland, ME 04101
(207) 773-9699

CIVIL ENGINEER
SEBAGO TECHNICS
75 John Roberts Road
South Portland, ME 04106
207-200-2100

FIRE PROTECTION ENGINEER
SURV
4 Thomas Dr.
Westbrook, ME 04092
207-828-0022


Drawing List:

Cover sheet

Site Plan

CS - Code Summary
A1.0 - Lower Level Floor Plan
A1.1 - First Floor Plan
A1.2 - Second Floor Plan
A1.3 - Door Schedule and Details
A1.4 Ramp and Platform Details
A2.1 York Street Elevation

Fire Protection Plan - Lower Level
Fire Protection Plan - First Floor
Fire Protection Plan - Second Floor

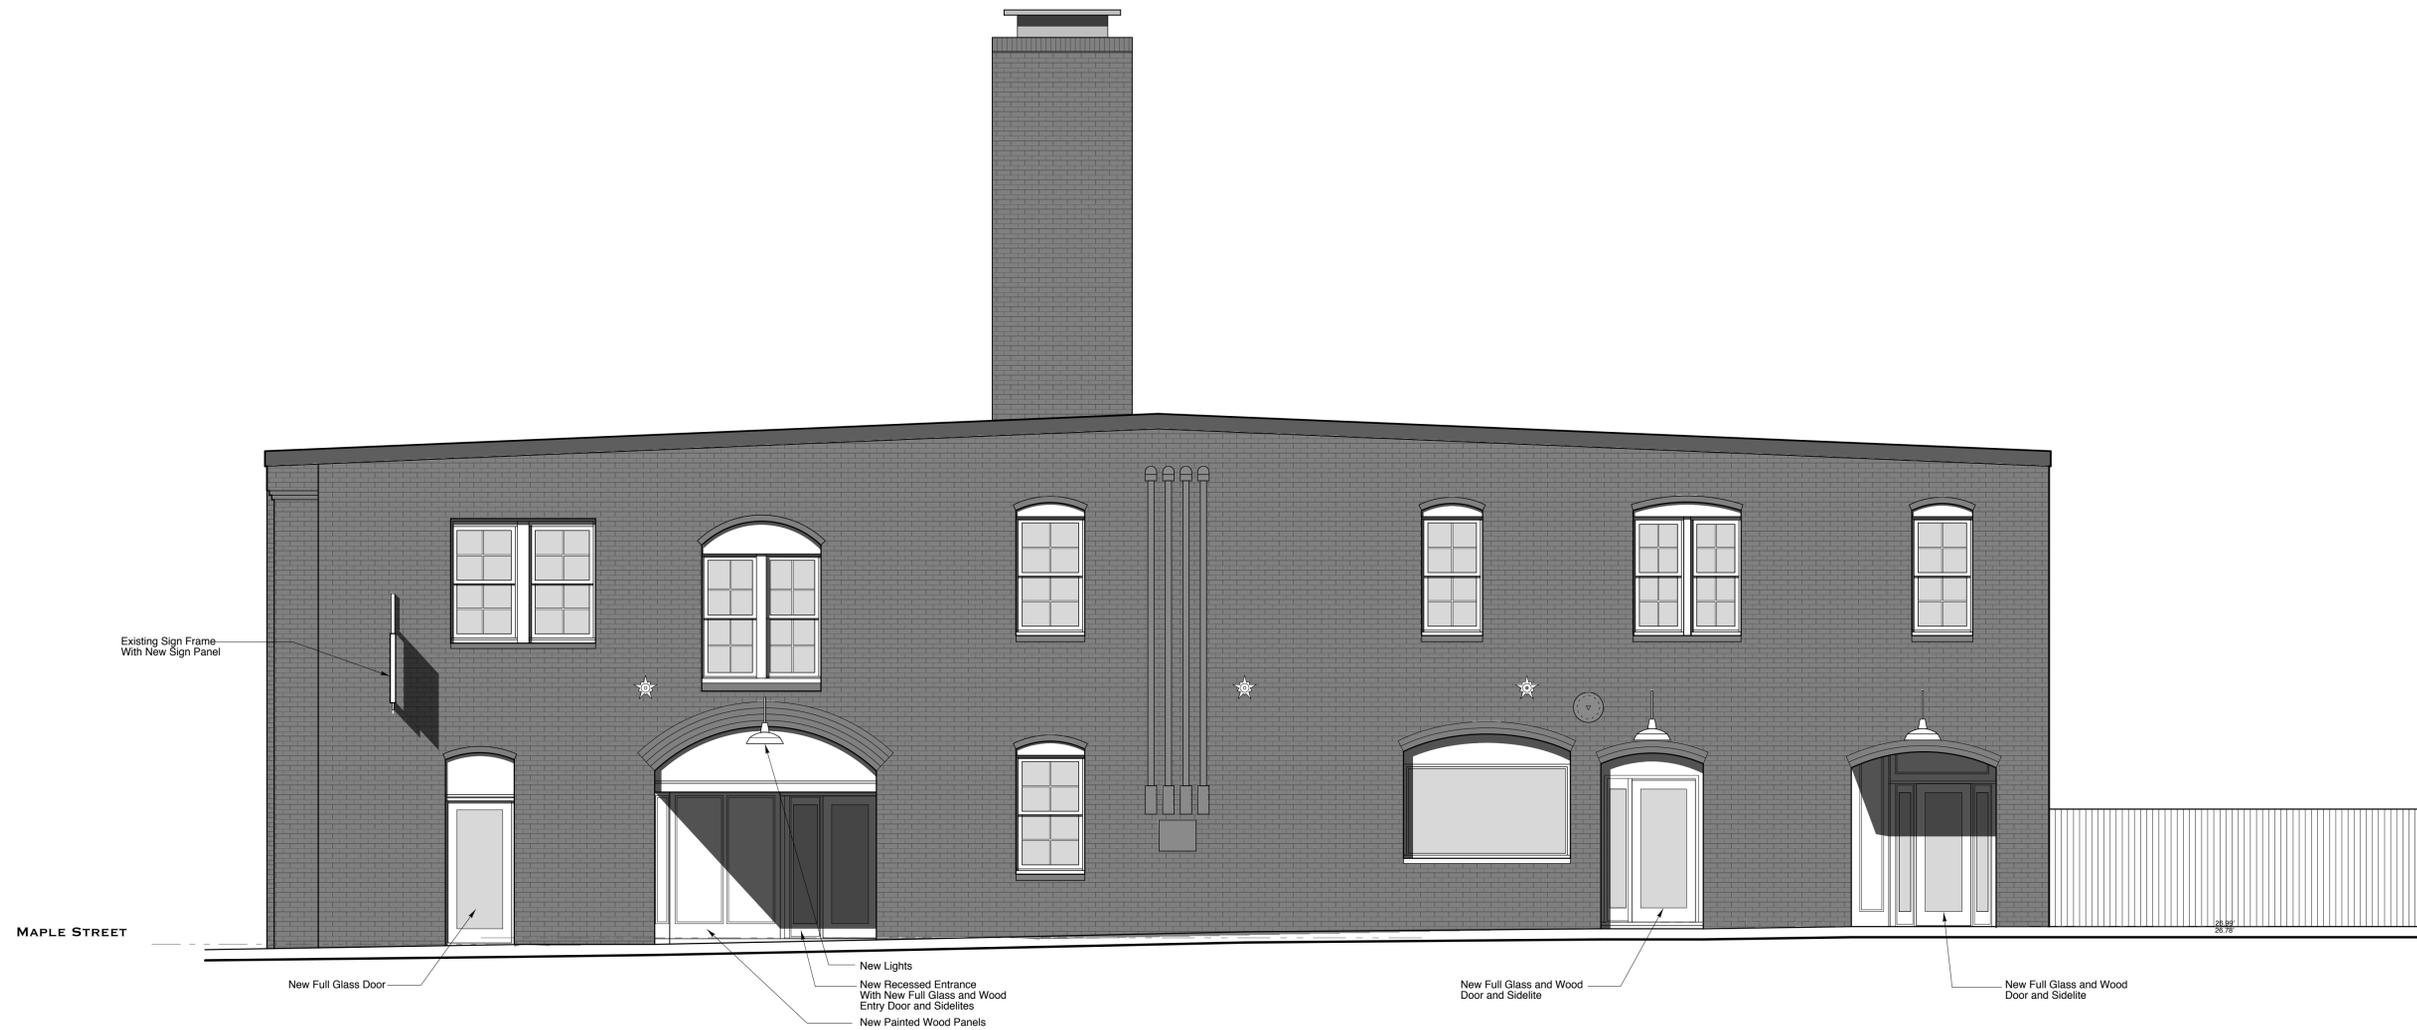

54 YORK STREET ELEVATION

Baxter Academy
Portland, Maine

0' 2' 4' 8'
Scale

Copyright 2012 Richard | Renner Architects

RRA

Richard Renner | Architects
Portland, ME
207.773.9699
Sherborn, MA
508.651.2385

Baxter Academy
54 York Street
Portland, Maine

York Street Elevation

Drawn by: RRA
File Name:
Scale: 1/4"=1'-0"
Date: 12-10-2012
Project No. 2012-10-00
Revised: 04-09-2013

Baxter
Academy