IRVING

PYRO-CHEM UL 1254 GAS ISLAND FIRE SUPPRESSION SYSTEM INSTALLATION

PROJECT
COMMERCIAL STREET PORTLAND IRVING

OWNER
IRVING OIL CORPORATION
190 COMMERCE WAY
PORTSMOUTH, NH 03801





P.O. BOX 187
GARDINER, NH 04345-0187

SALES: 1.800.649.9881 SERVICE: 1.800.649.9881

WEBSITE: www.interstatefire.com

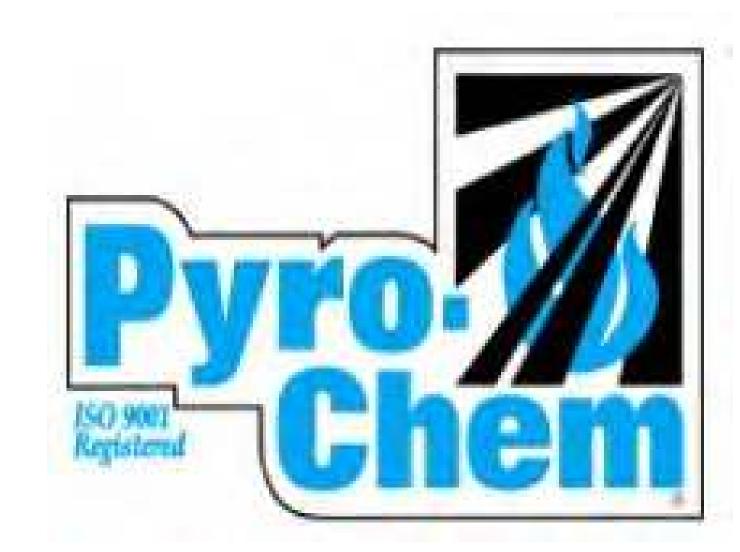


TABLE OF CONTENTS	
SHEET NO.	TITLE
01	COVER SHEET
02	MECHANICAL DETAIL
03	ELECTRICAL PLAN
04	PANEL PROGRAMMING

NOTES: 1. THIS INSTALLATION SHALL BE MADE IN STRICT ACCORDANCE WITH THE DRAWINGS, SPECIFICATIONS AND APPLICABLE NATIONAL FIRE PROTECTION ASSOCIATION STANDARDS. ALL EQUIPMENT AND DEVICES USED SHALL BE LISTED IN THE UL FIRE EQUIPMENT DIRECTORY.

- 2. DESIGN AND INSTALLATION OF THE DRY CHEMICAL GAS ISLAND FIRE SUPPRESSION SYSTEM WILL BE IN STRICT ACCORDANCE WITH THE FOLLOWING GUIDELINES AND REGULATORY AGENCIES:
- 2.1. NFPA 17 STANDARD FOR DRY CHEMICAL FIRE EXTINGUISHING SYSTEMS, 2013 EDITION 2.2. NFPA 72 NATIONAL FIRE ALARM AND SIGNALING CODE, 2016 EDITION
- 2.3. NFPA 70 NATIONAL ELECTRIC CODES, 2011 EDITION
- 2.4. AMERICANS WITH DISABILITIES ACT, TITLE 24, LATEST EDITION 2.5. THE LOCAL AUTHORITY HAVING JURISDICTION

System Information:

PYRO-CHEM ATTENDANT II UL 1254

DRY CHEMICAL FIRE SUPPRESSION

SYSTEM PROTECTING A SELF-SERVICE

GASOLINE FUELING FACILITY

Owner/Site:

IRVING OIL CORPORATION
IRVING
393 COMMERCIAL STREET

PORTLAND, ME 04101

P.O. BOX 1005 NORTH CONWAY, NH 03860

P.O. BOX 187

GARDINER. ME 04345

PYRO-CHEM GAS ISLAND FIRE SUPPRESSION SYSTEM COVER SHEET

Proj. no.:

CAD File: IrvingComSt.dwg

Drawn By: M. STEWARD

Created on: 05/01/2016

Designed by: M. STEWARD

Checked by: B. TWOMBLY

Approved by: B.TWOMBLY

Project Lead: T. MOONEY

Scale: SCALE AS NOTED

Revisions: Date:
ii 05/01/2016
SHEET: