


ELECTRICAL NOTES

- 1. Electrical contractor shall provide as part of this contract legible labeling of all
- breakers on panel board with typewritten or plastic embossed label. 2. The electrical installation shall meet the standards prescribed by the National Electrical Code and all local amendments, all applicable National Fire Protection Association (NFPA) codes, and local and state building codes. Construction shall in general be in accordance with standards and
- requirements of utilities and authorities having jurisdiction. 3. Verify electrical requirements if any for any equipment or appliances shown on plans prior to commencement of work. Provide isolated ground wires as
- required by equipment manufacturers.
 4. Center all receptacles 18" a.f.f. and switches 42" a.f.f. unless noted otherwise on plan or located above countertops.
- 5. The scope of the electrical work includes furnishing and installing all electrical
- work for a complete installation.6. Lighting in Upper Cabinets not shown for clarity coordinate with Kitchen drawings & switch locations on lighting plans.

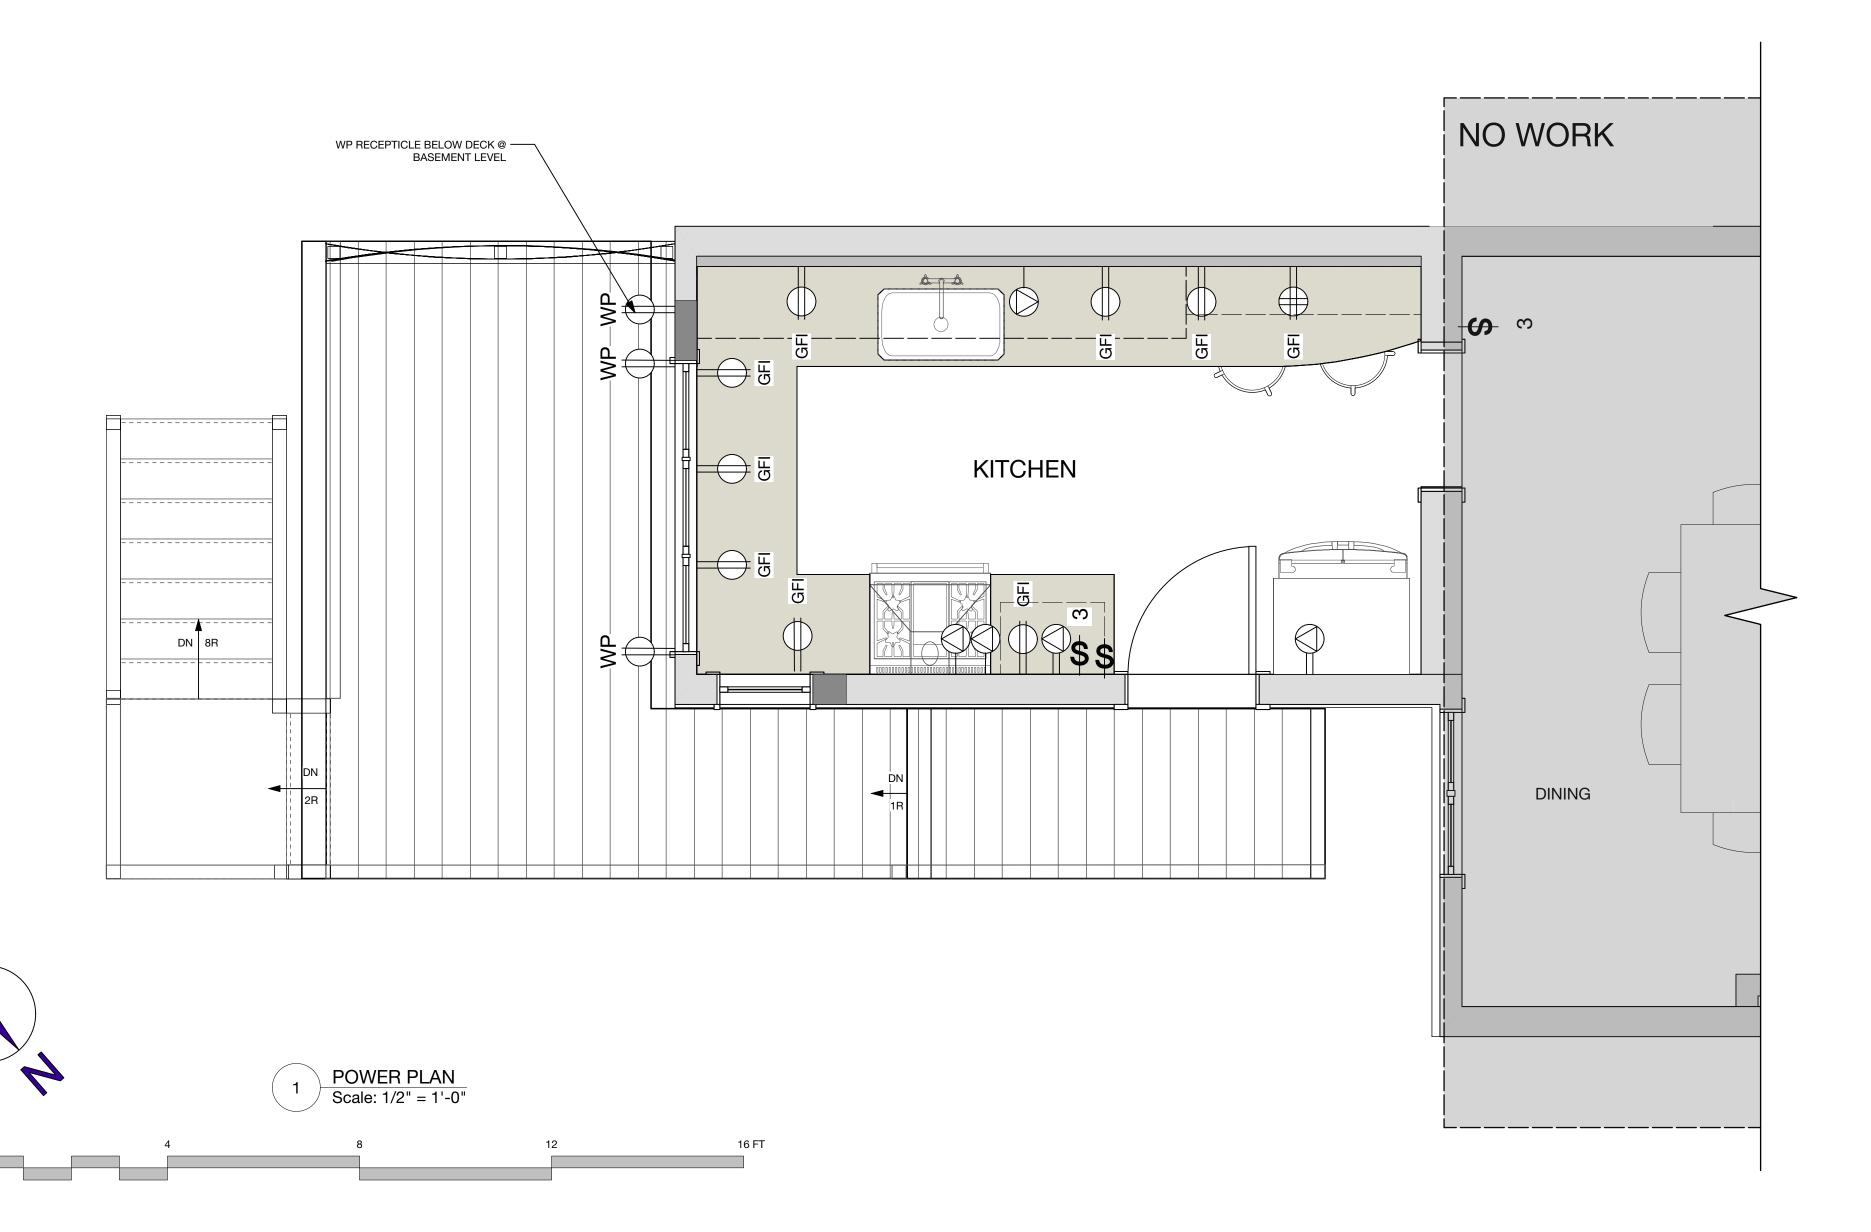

PERMIT SET

		1 61	XIIIII OLI	
SED ARCH	Design Firm DESIDENTIAL DESIGN STUDIO LLC	Project Title	Sheet Status PERMIT SET	
CAROL	RESIDENTIAL DESIGN STUDIO, LLC Carol A. Morrissette 21 Chestnut Street, Suite 506	DUNDON/CRAWFORD 5 STRATTON PLACE	Project Number Date 16.30 21	e I JULY 2016
MORRISSETTE	Portland, Maine 04101 T 207.699.4184 C 207.671.7965	PORTLAND, MAINE	Drawn By AC/CAM	eet No.
RESIDENTIAL No. 3769	Revisions 1 .	Sheet Title	Sheet Scale 1/2" = 1'-0"	E1.1
RESIDENTIAL DESIGN STUDIO	3	POWER PLAN	CAD File Number DundonA1	