



9

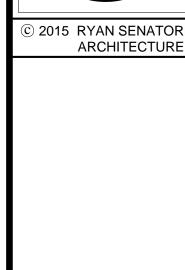

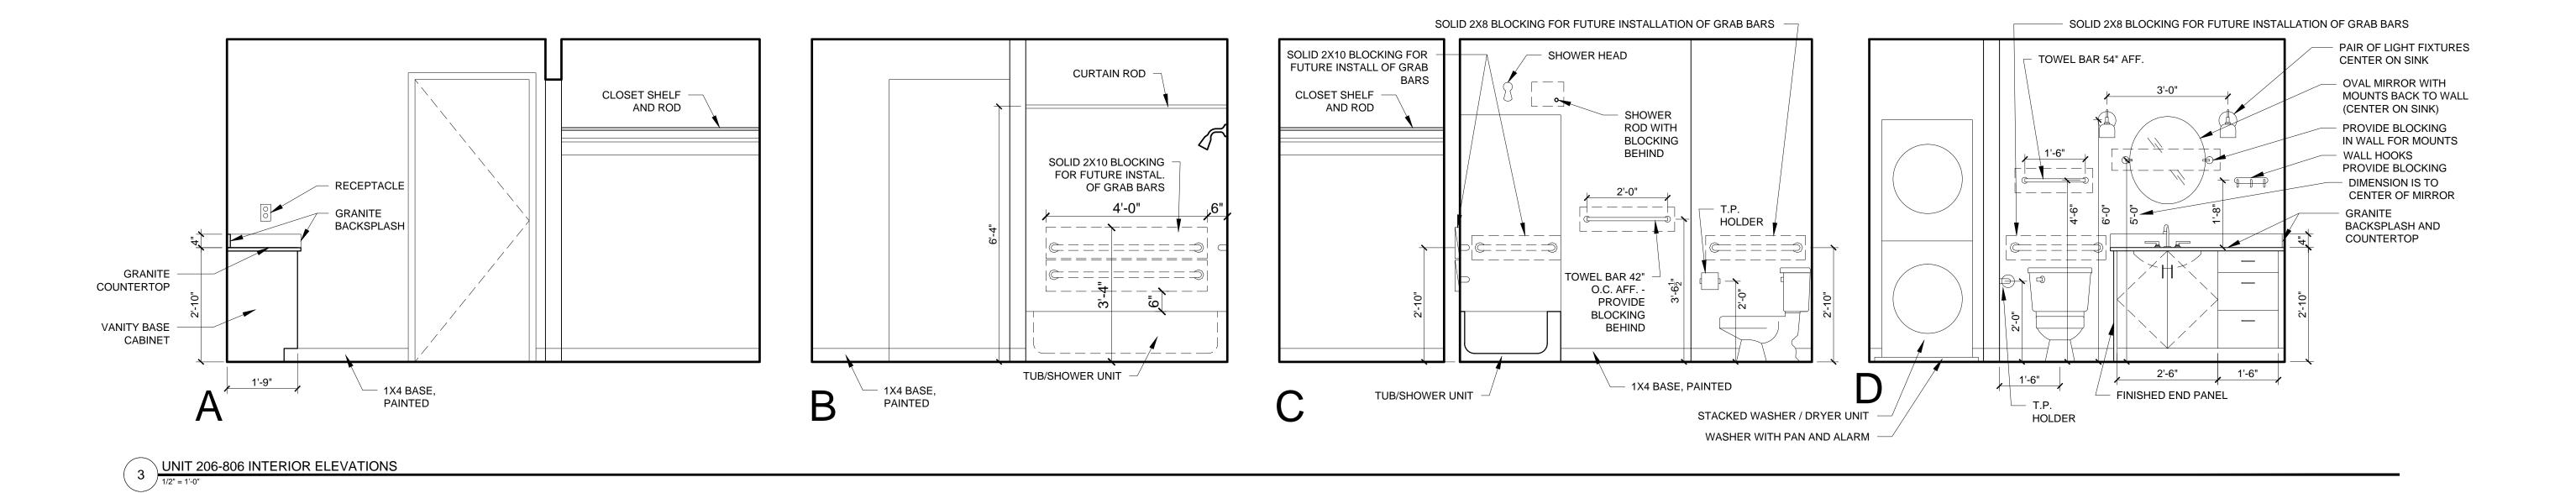



1.) G.C. TO COORDINATE LOCATIONS OF PLUMBING CLEAN OUTS WITH ACCESS PANELS AS SHOWN ON REFLECTED CEILING PLANS

2.) G.C. TO PROVIDE ACCESS PANELS AS REQUIRED FOR ALL ELEMENTS (SPRINKLER, VALVES, ETC) NOT SHOWN ON THIS REFLECTED CEILING PLAN)

3.) G.C. TO PROVIDE METAL FRAMING AND BLOCKING REQUIRED FOR ALL ACCESS PANELS AND CONTROL JOINTS

4.) ALL ACCESS PANELS TO BE FIRE RATED TO MATCH THE CEILING THEY ARE INSTALLED WITHIN

## UNIT NOTES

1.) CEILING HEIGHTS, WINDOW HEAD AND SILL HEIGHTS VARY FROM FLOOR TO FLOOR, INTERIOR ELEVATIONS GRAPHICALLY DEPICT ONE FLOOR ONLY, FOR HEIGHT INFORMATION REFER TO BUILDING SECTIONS AND WALL SECTIONS

 2.) G.C. TO CONFRIM AND COORDINATE ALL ROUGH FRAMING DIMENSIONS FOR TUBS, SHOWERS, BUILT-IN FIXTURES ETC.

G.C. TO CONFRIM AND COORDINATE ALL CABINETRY AND

APPLIANCES DIMENSIONS

3.) PROVIDE APPROPRIATE FIRE TREATED BLOCKING IN WALLS BEHIND ALL FIXTURES, PARTITIONS AND ACCESSORIES. BLOCKING FOR GRAB BARS TO BE PROVIDED IN WALLS OF BATHROOMS IN ALL UNITS

4.) PROVIDE MOISTURE RESISTANT GWB AT ALL WALLS AND CEILINGS IN BATHROOMS TYPICAL
5.) SET ALL CLOTHES WASHERS IN PANS WITH WATER SENSOR
6.) REFER TO ELECTRICAL AND MECHANICAL DRAWINGS FOR ADDITIONAL INFORMATION REGARDING, LIGHTING, DIFFUSERS,

7.) PROVIDE FIRE EXTINGUISHER ON BRACKET IN BASE CABINET BELOW KITCHEN SINK - TYPICAL
8.) HANG HOT WATER HEATER FROM DECK ABOVE. (SEE DETAIL ON TYPICAL UNIT DETAILS SHEET)

WHICH IS PART OF THE RATED ASSEMBLY

10.) WHERE PLUMBING VALVES (TUB, SHOWER, ETC) ARE LOCATED IN FIRE RATED WALLS, PROVIDE FIRE RATED BOX IN

9.) WHERE DROPPED SOFFITS AND CEILINGS ARE SHOWN, THESE ARE IN ADDITION TO THE FIRE RATED GWB CEILING ABOVE

## CABINETRY AND APPLIANCE ABBREVIATIONS

WALL FOR VALVE TO BE INSTALLED WITHIN

DB = DRAWER BASE DRB = DOOR BASE


SB = SINK BASE
WC = WALL CABINET
WC(24) = WALL CABINET 24" DEEP


PU = PANTRY UNIT 24" DEEP OS = OPEN SHELVES


RA = RANGE

DW = DISHWASHER
REF = REFRIGERATOR
REFLECTED CEILING PLAN AND LIG

REFLECTED CEILING PLAN AND LIGHTING LEGEND		
SYMBOL	TAG	DESCRIPTION
	Α	SURFACE MOUNT - TBD
$\bigcirc$	В	SURFACE MOUNTED - TBD
$\circ$	С	SURFACE MOUNT - IN CLOSETS
	D	SURFACE MOUNTED ON WALL ABOVE DOOR
	Е	WALL SCONCE IN BATHROOM OVER VANITY
$\circ$	F	SURFACE MOUNT - WET LOCATION
$\circ$	Н	SURFACE MOUNT CENTER IN BEDROOMS
$\circ$	J	SURFACE MOUNT - WET LOCATION
	K	EXTERIOR CUT OFF DOWN LIGHT
		CEILING GRILLE

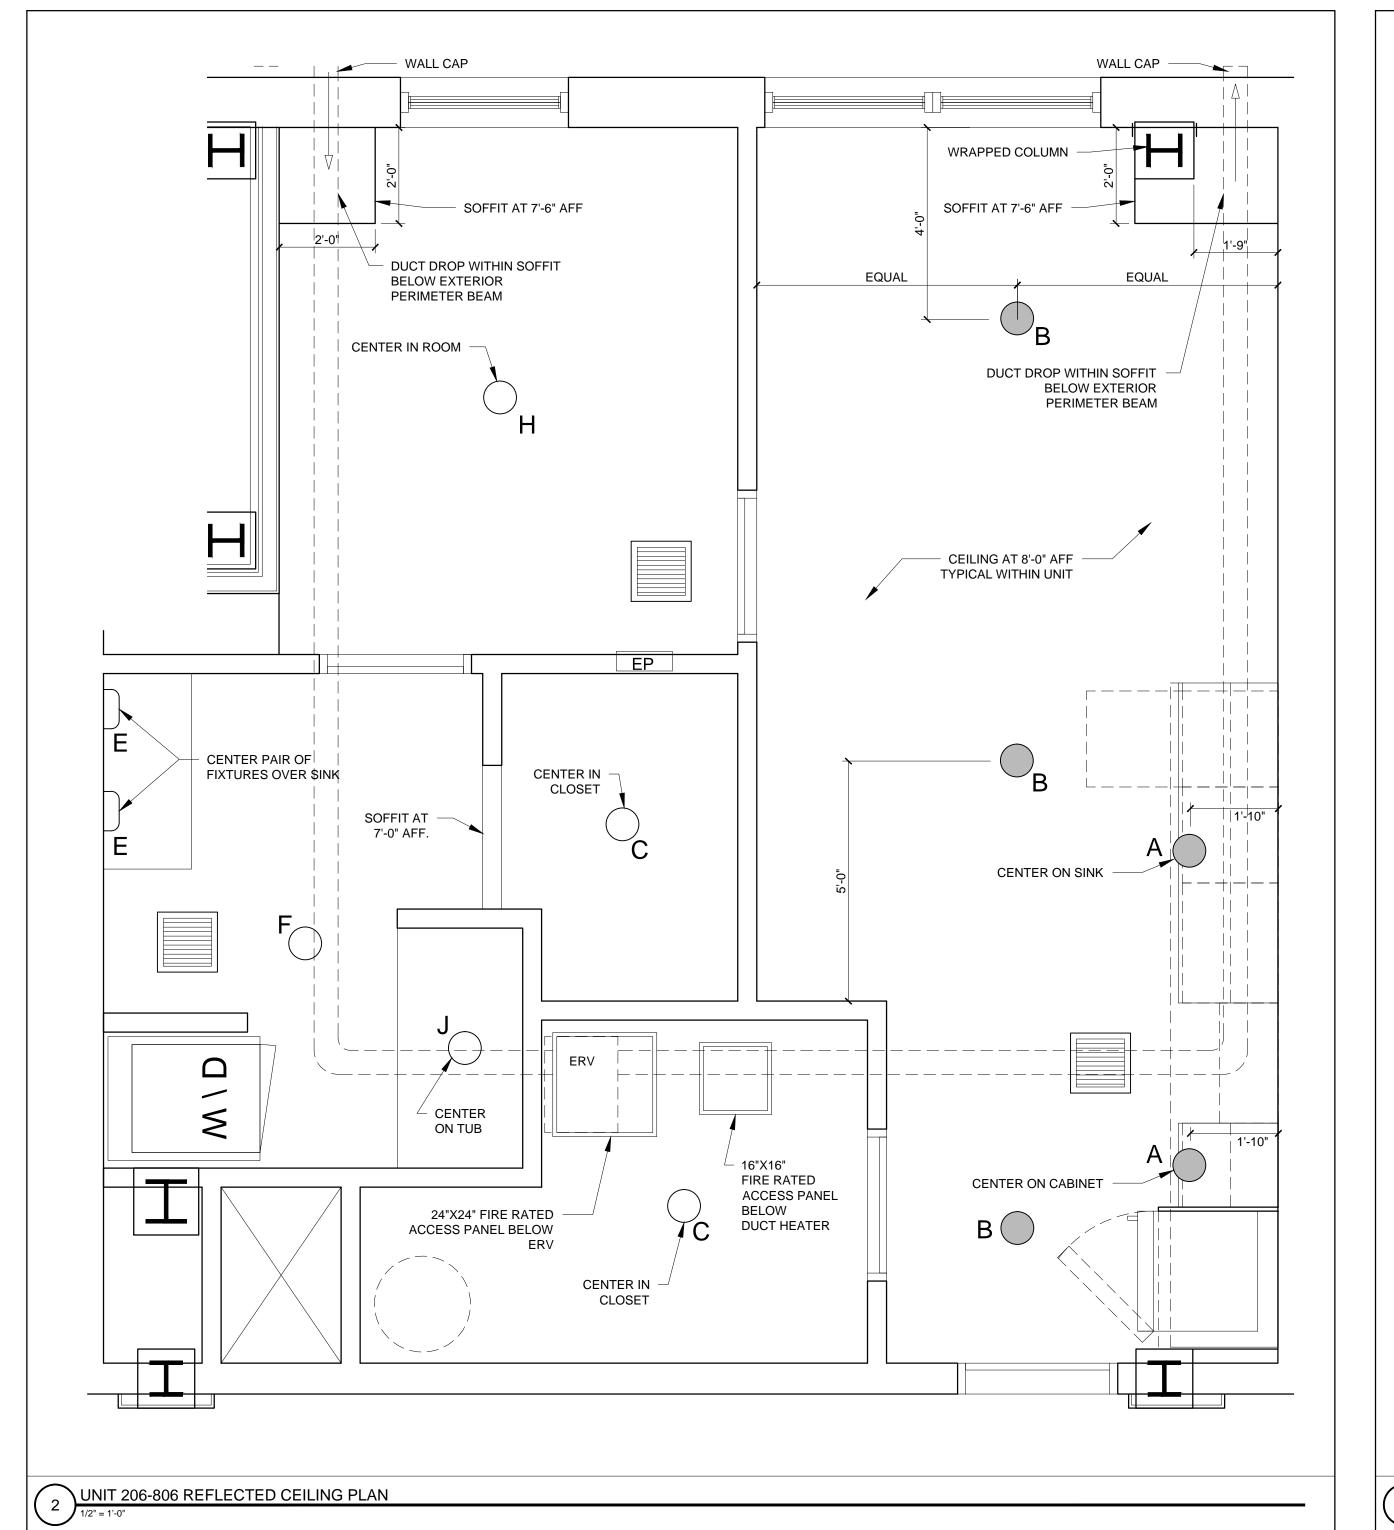

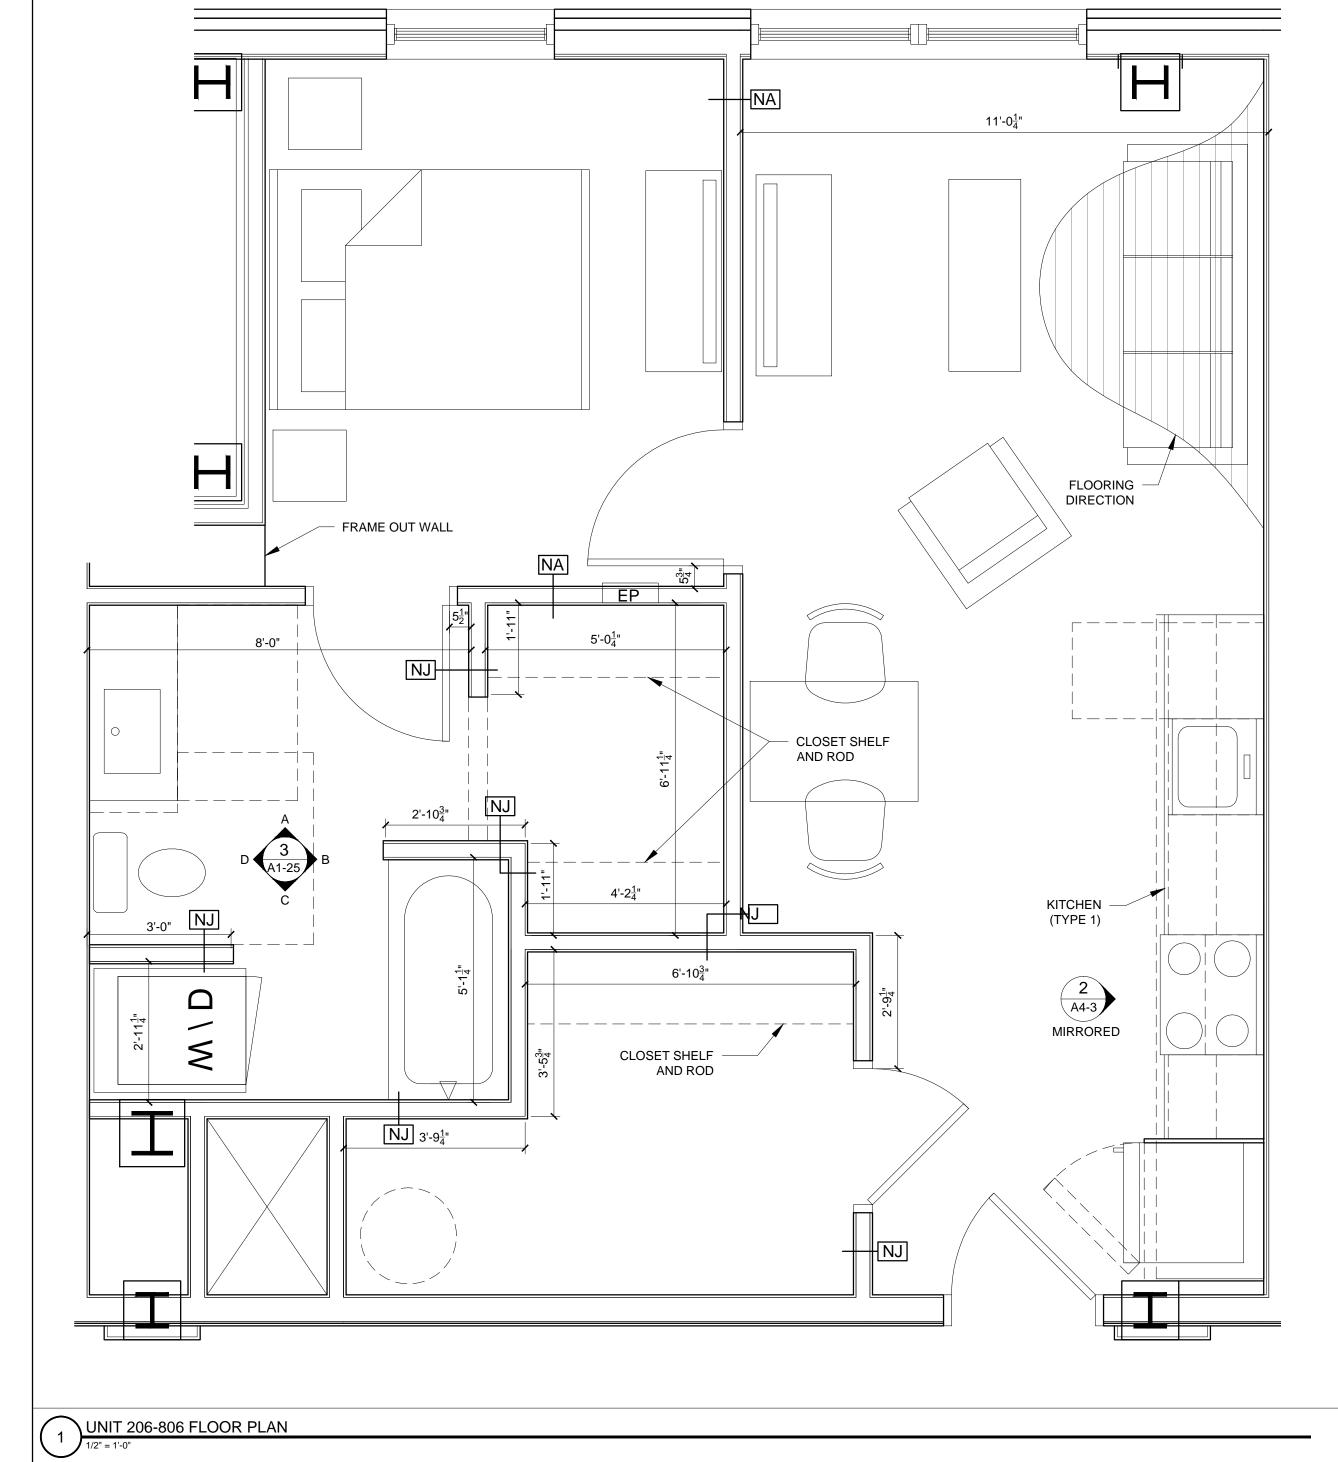

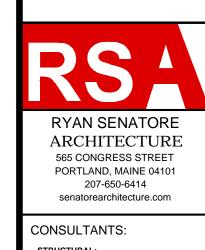

CONSULTANTS:

STRUCTURAL:
Structural Integrity
77 Oak Street
Portland, ME 04101
207-774-4614

REVISIONS:

DATE: 2 NOVEMBER 2015

PROJECT No. 1503

DRAWN BY: RJS / RRT

CHECKED BY: RJS

SCALE: AS NOTED

SHEET TITLE:

UNIT 206-806
PLANS AND

PLANS AND INTERIOR ELEVATIONS

A1-25