9

RYAN SENATORE

ARCHITECTURE

565 CONGRESS STREET PORTLAND, MAINE 04101

207-650-6414

senatorearchitecture.com

CONSULTANTS:

STRUCTURAL: Structural Integrity 77 Oak Street Portland, ME 04101 207-774-4614

REVISIONS:

PROJECT No.

DRAWN BY:

CHECKED BY:

SHEET TITLE:

UNIT 206-806

PLANS AND INTERIOR

ELEVATIONS


SCALE:


1\ REVISION #1 - 05/17/16

DATE: FEBRURAY 15, 20°

RJS / RR

AS NOTED

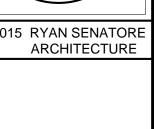

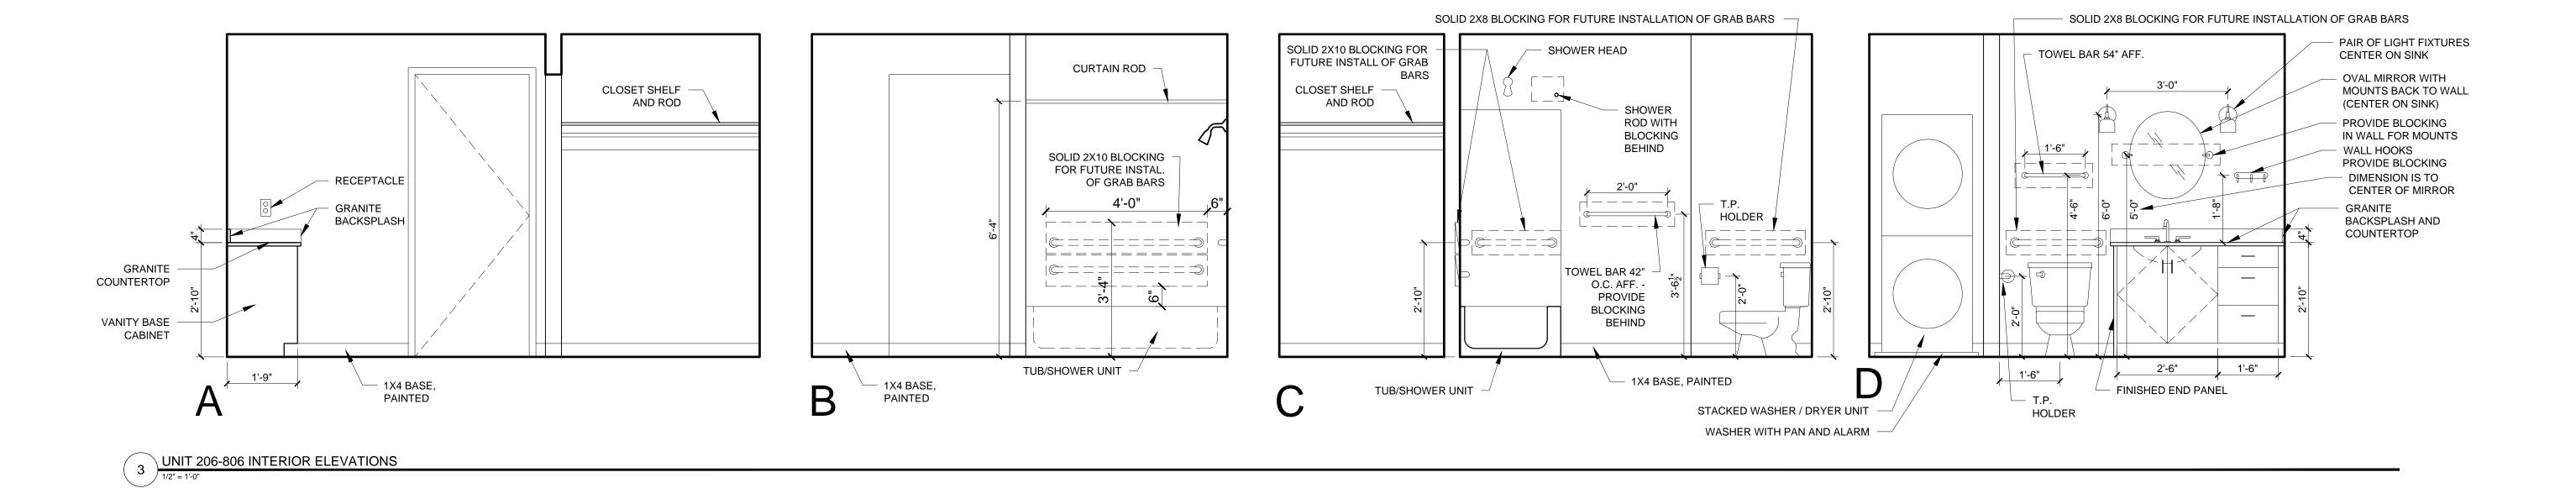

REFLECTED CEILING PLAN NOTES

1.) G.C. TO COORDINATE LOCATIONS OF PLUMBING CLEAN OUTS WITH ACCESS PANELS AS SHOWN ON REFLECTED CEILING PLANS

2.) G.C. TO PROVIDE ACCESS PANELS AS REQUIRED FOR ALL ELEMENTS (SPRINKLER, VALVES, ETC) NOT SHOWN ON THIS REFLECTED CEILING PLAN) 3.) G.C. TO PROVIDE METAL FRAMING AND

BLOCKING REQUIRED FOR ALL ACCESS PANELS AND CONTROL JOINTS

4.) ALL ACCESS PANELS TO BE FIRE RATED TO MATCH THE CEILING THEY ARE INSTALLED WITHIN

UNIT NOTES

APPLIANCES DIMENSIONS

BELOW KITCHEN SINK - TYPICAL

1.) CEILING HEIGHTS, WINDOW HEAD AND SILL HEIGHTS VARY FROM FLOOR TO FLOOR, INTERIOR ELEVATIONS GRAPHICALLY DEPICT ONE FLOOR ONLY, FOR HEIGHT INFORMATION REFER TO BUILDING SECTIONS AND WALL SECTIONS 2.) G.C. TO CONFRIM AND COORDINATE ALL ROUGH FRAMING DIMENSIONS FOR TUBS, SHOWERS, BUILT-IN FIXTURES ETC.

3.) PROVIDE APPROPRIATE FIRE TREATED BLOCKING IN WALLS BEHIND ALL FIXTURES, PARTITIONS AND ACCESSORIES. BLOCKING FOR GRAB BARS TO BE PROVIDED IN WALLS OF BATHROOMS IN ALL UNITS 4.) PROVIDE MOISTURE RESISTANT GWB AT ALL WALLS AND

G.C. TO CONFRIM AND COORDINATE ALL CABINETRY AND

CEILINGS IN BATHROOMS TYPICAL 5.) SET ALL CLOTHES WASHERS IN PANS WITH WATER SENSOR 6.) REFER TO ELECTRICAL AND MECHANICAL DRAWINGS FOR ADDITIONAL INFORMATION REGARDING, LIGHTING, DIFFUSERS,

7.) PROVIDE FIRE EXTINGUISHER ON BRACKET IN BASE CABINET

8.) HANG HOT WATER HEATER FROM DECK ABOVE. (SEE DETAIL ON TYPICAL UNIT DETAILS SHEET) 9.) WHERE DROPPED SOFFITS AND CEILINGS ARE SHOWN, THESE ARE IN ADDITION TO THE FIRE RATED GWB CEILING ABOVE

WHICH IS PART OF THE RATED ASSEMBLY 10.) WHERE PLUMBING VALVES (TUB, SHOWER, ETC) ARE LOCATED IN FIRE RATED WALLS, PROVIDE FIRE RATED BOX IN WALL FOR VALVE TO BE INSTALLED WITHIN

CABINETRY AND APPLIANCE ABBREVIATIONS

DB = DRAWER BASE DRB = DOOR BASE SB = SINK BASE

WC = WALL CABINET WC(24) = WALL CABINET 24" DEEP PU = PANTRY UNIT 24" DEEP

OS = OPEN SHELVES RA = RANGE

DW = DISHWASHER REF = REFRIGERATOR

CEILING GRILLE

REFLECTED CEILING PLAN AND LIGHTING LEGEND		
SYMBOL	TAG	DESCRIPTION
	Α	SURFACE MOUNT - TBD
	В	SURFACE MOUNTED - TBD
0	С	SURFACE MOUNT - IN CLOSETS
	D	SURFACE MOUNTED ON WALL ABOVE DOOR
	Е	WALL SCONCE IN BATHROOM OVER VANITY
0	F	SURFACE MOUNT - WET LOCATION
	Н	SURFACE MOUNT CENTER IN BEDROOMS
	J	SURFACE MOUNT - WET LOCATION
	K	EXTERIOR CUT OFF DOWN LIGHT
1		

