



232 MAINE MEDICAL CENTER

BRAMHALL CAMPUS: PORTLAND, MAINE

HOLDING, RADCU & PBC RENOVATION


Sheet Number	Sheet Name	
G- 001	GENERAL INFORMATION	
A- 001	BASEMENT LIFE SAFETY PLAN	
A- 100	DEMOLITION AND SCOPE OF WORK PLAN	
A- 101	BASEMENT FLOOR PLAN	
A- 102	LAYOUT PLAN, REFLECTED CEILING PLAN & DETAILS	
A - 200	INTERIOR ELEVATIONS	
A - 201	INTERIOR ELEVATIONS	
A - 500	INTERIOR ELEVATIONS AND DETAILS	
A - 600	INTERIOR FINISHES, SCHEDULES & DETAILS	
A - 601	DOOR SCHEDULE & DETAILS	

STRUCTURAL	
Sheet Number	Sheet Name
SF101	FOUNDATION AND FRAMING PLANS AND DETAILS

Sheet Number	Sheet Name
M-001	LEGEND AND ABBREVIATIONS
MD101	BASEMENT LEVEL HVAC DEMOLITION PLAN
MD102	BASEMENT LEVEL PIPING DEMOLITION PLAN
MH101	BASEMENT LEVEL HVAC DUCTWORK PLAN
MP101	BASEMENT LEVEL HVAC PIPING PLAN
M-501	DETAILS
M-601	SCHEDULES
P-001	PLUMBING LEGEND
PD101	BASEMENT LEVEL DWV DEMOLITION PLAN
PD102	BASEMENT LEVEL SUPPLY PIPING DEMOLITION PLAN
PL101	BASEMENT LEVEL DWV PIPING PLAN
PL102	BASEMENT LEVEL SUPPLY PIPING PLAN
PL601	PLUMBING SCHEDULES

ELECTRICAL	
Sheet Number	Sheet Name
E-001	LEGEND AND GENERAL NOTES
E-002	SPECIFICATIONS
E-003	SPECIFICATIONS SHEET 2
ED101	BASEMENT LEVEL POWER DEMOLITION PLAN
ED102	BASEMENT LEVEL LIGHTING DEMOLITION PLAN
ED103	BASEMENT LEVEL SYSTEMS DEMOLITION PLAN
EP101	BASEMENT LEVEL POWER PLAN
EL101	BASEMENT LEVEL LIGHTING PLAN
EY101	BASEMENT LEVEL SYSTEMS PLAN
EP401	ELECTRICAL DEVICE AND DIMENSION PLAN - BASEMENT FLOOR
EP402	ELECTRICAL RACEWAY PLAN - BASEMENT FLOOR
E601	SCHEDULES
EP651	ONE LINE DIAGRAM

Sheet Number	Sheet Name	
Q-001	VENDOR EQUIPMENT DRAWINGS SHEET 1	
Q-002	VENDOR EQUIPMENT DRAWINGS SHEET 2	
Q-003	VENDOR EQUIPMENT DRAWINGS SHEET 3	
Q-004	VENDOR EQUIPMENT DRAWINGS SHEET 4	
Q-005	VENDOR EQUIPMENT DRAWINGS SHEET 5	
Q-006	VENDOR EQUIPMENT DRAWINGS SHEET 6	
Q-007	VENDOR EQUIPMENT DRAWINGS SHEET 7	
Q-008	VENDOR EQUIPMENT DRAWINGS SHEET 8	
Q-009	VENDOR EQUIPMENT DRAWINGS SHEET 9	

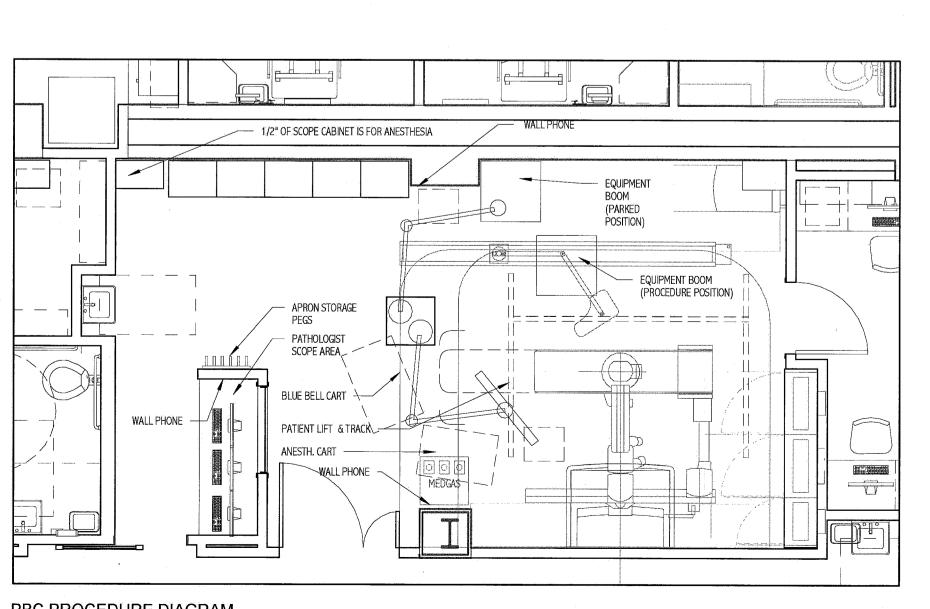



PBC PROCEDURE DIAGRAM

1/4" = 1' 0"

G-001



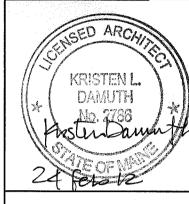

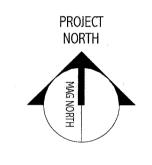

MAINE MEDICAL CENTER HOLDING, RADCU & PBC RENOVATION

PROJECT MANAGER: JC/DRAWN BY: A/E OF RECORD:

GENERAL INFORMATION

PROJECT NO: