

MAINE MEDICAL CENTER

ED CT FIT- UP AND READING ROOM RENOVATIONS

BRAMHALL CAMPUS - PORTLAND, MAINE

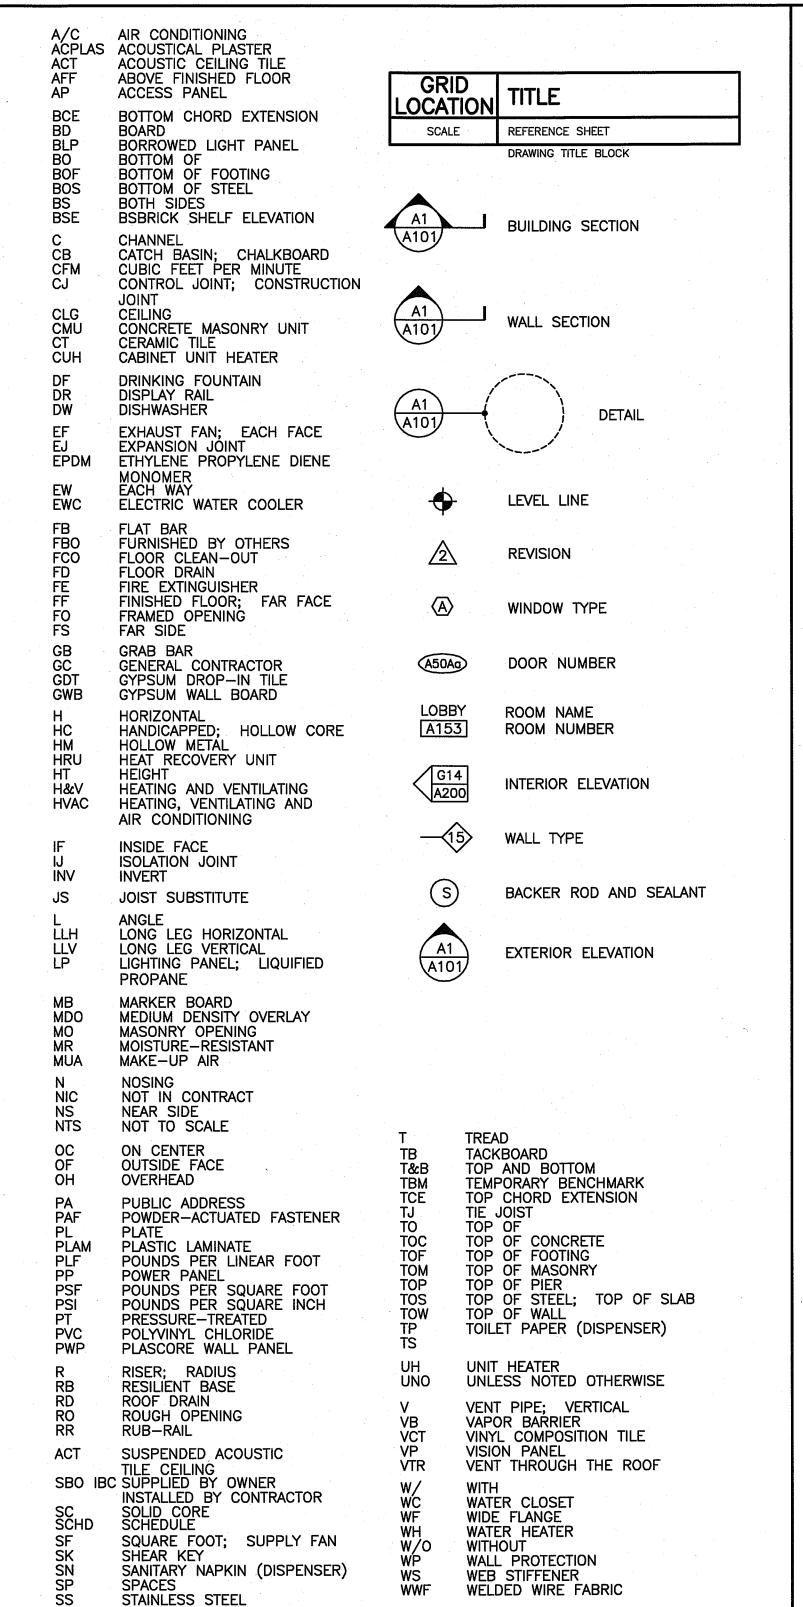

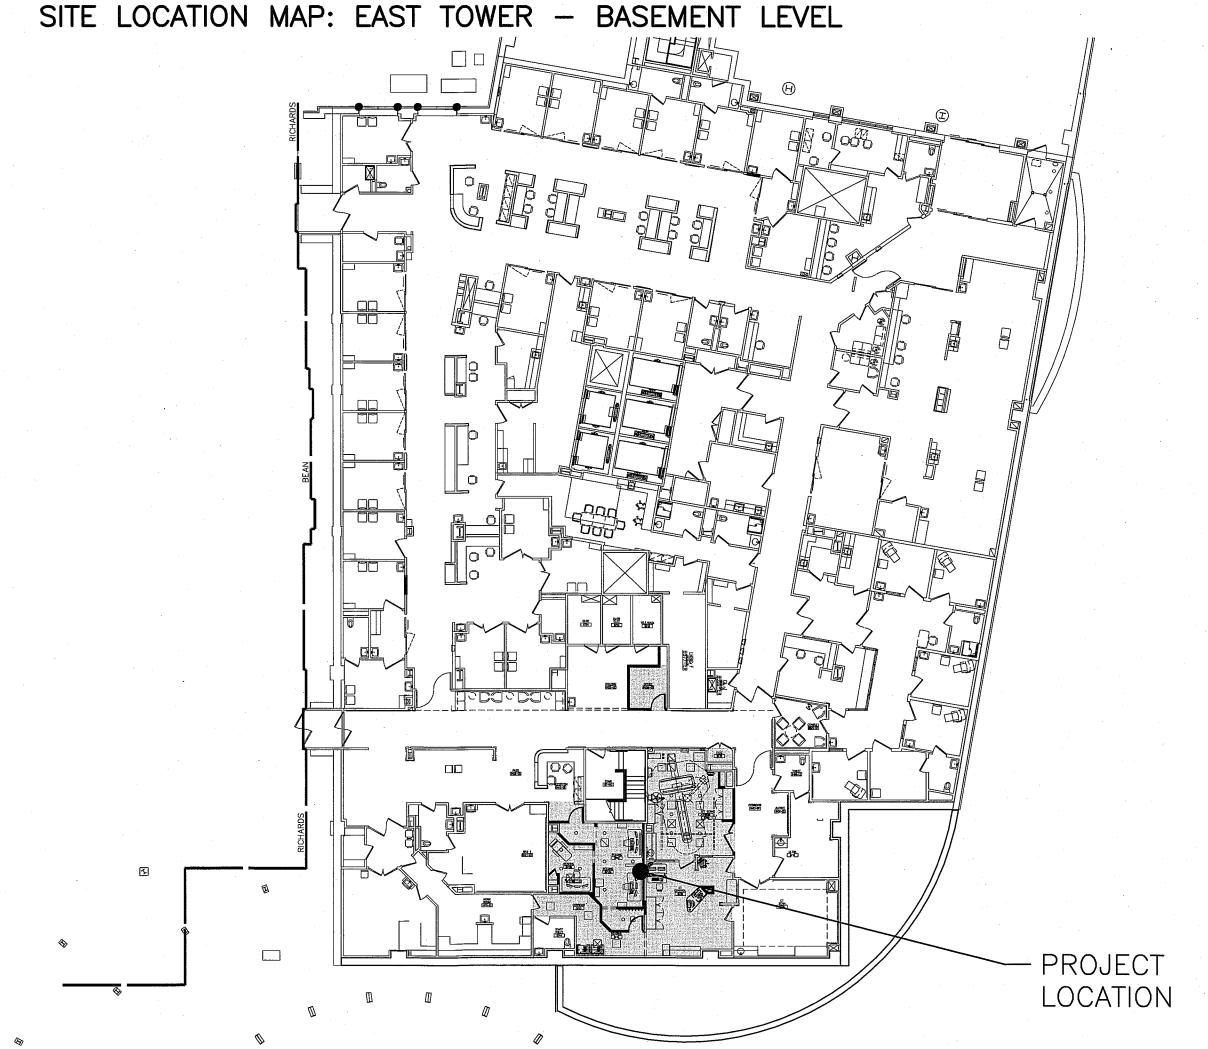

DRAWING LIST

<u>GENERAL</u>

COVER SHEET PARTITION TYPES AND TYPICAL MOUNTING HEIGHTS **ARCHITECTURAL**

PARTIAL FACILITY AND CODE COMPLIANCE PLAN

DEMOLITION FLOOR PLAN

FLOOR PLAN

REFLECTED CEILING PLAN

INTERIOR ELEVATIONS

SCHEDULES

FIRE PROTECTION PLAN, LEGEND AND SPECIFICATIONS

MECHANICAL

MECHANICAL LEGEND & ABBREVIATIONS MECHANICAL SPECIFICATIONS AND SCHEDULES

HVAC DUCTWORK DEMOLITION PLAN HVAC PIPING DEMOLITION PLAN

HVAC DUCTWORK PLAN

HVAC PIPING PLAN

M-501 MECHANICAL DETAILS

P-001 PLUMBING LEGEND AND ABBREVIATIONS P-002 PLUMBING SPECIFICATIONS

PLUMBING DWV PIPING PLANS

PLUMBING SUPPLY PIPING PLANS

PLUMBING MEDICAL GAS PIPING PLAN

P-501 PLUMBING DETAILS AND SCHEDULES

E-001 LEGEND AND GENERAL NOTES

ELECTRICAL DEMOLITION PLAN

POWER PLAN EP401 ENLARGED PLAN

LIGHTING PLAN

EY101 SYSTEMS PLAN

GE EQUIPMENT DRAWINGS - (REFERENCE ONLY)

C1 SITE READINESS

EQUIPMENT LAYOUT S1 STRUCTURAL LAYOUT

S2 STRUCTURAL DETAILS E1 ELECTRICAL LAYOUT

E2 ELECTRICAL SPECIFICATIONS

E3 ELECTRICAL DETAILS D1 EQUIPMENT DETAILS

D2 EQUIPMENT DETAILS

PROJECT NORTH VEILLEUX No. 3185 RENOVATIONS PERN -15 FOR 1-12 MAINE ED CT GRAPHIC SCALE: PROJECT MANAGER: JC/DRAWN BY: A/E OF RECORD: CAD FILE: GI001-14150

PROJECT NO:

COVER SHEET