


PERKINS +WILL

## HYBRID OR & OR #6

Maine Medical Center 22 Bramhall Street, Portland, Maine 04102

## **ISSUE FOR PERMIT**

AUGUST 21, 2015

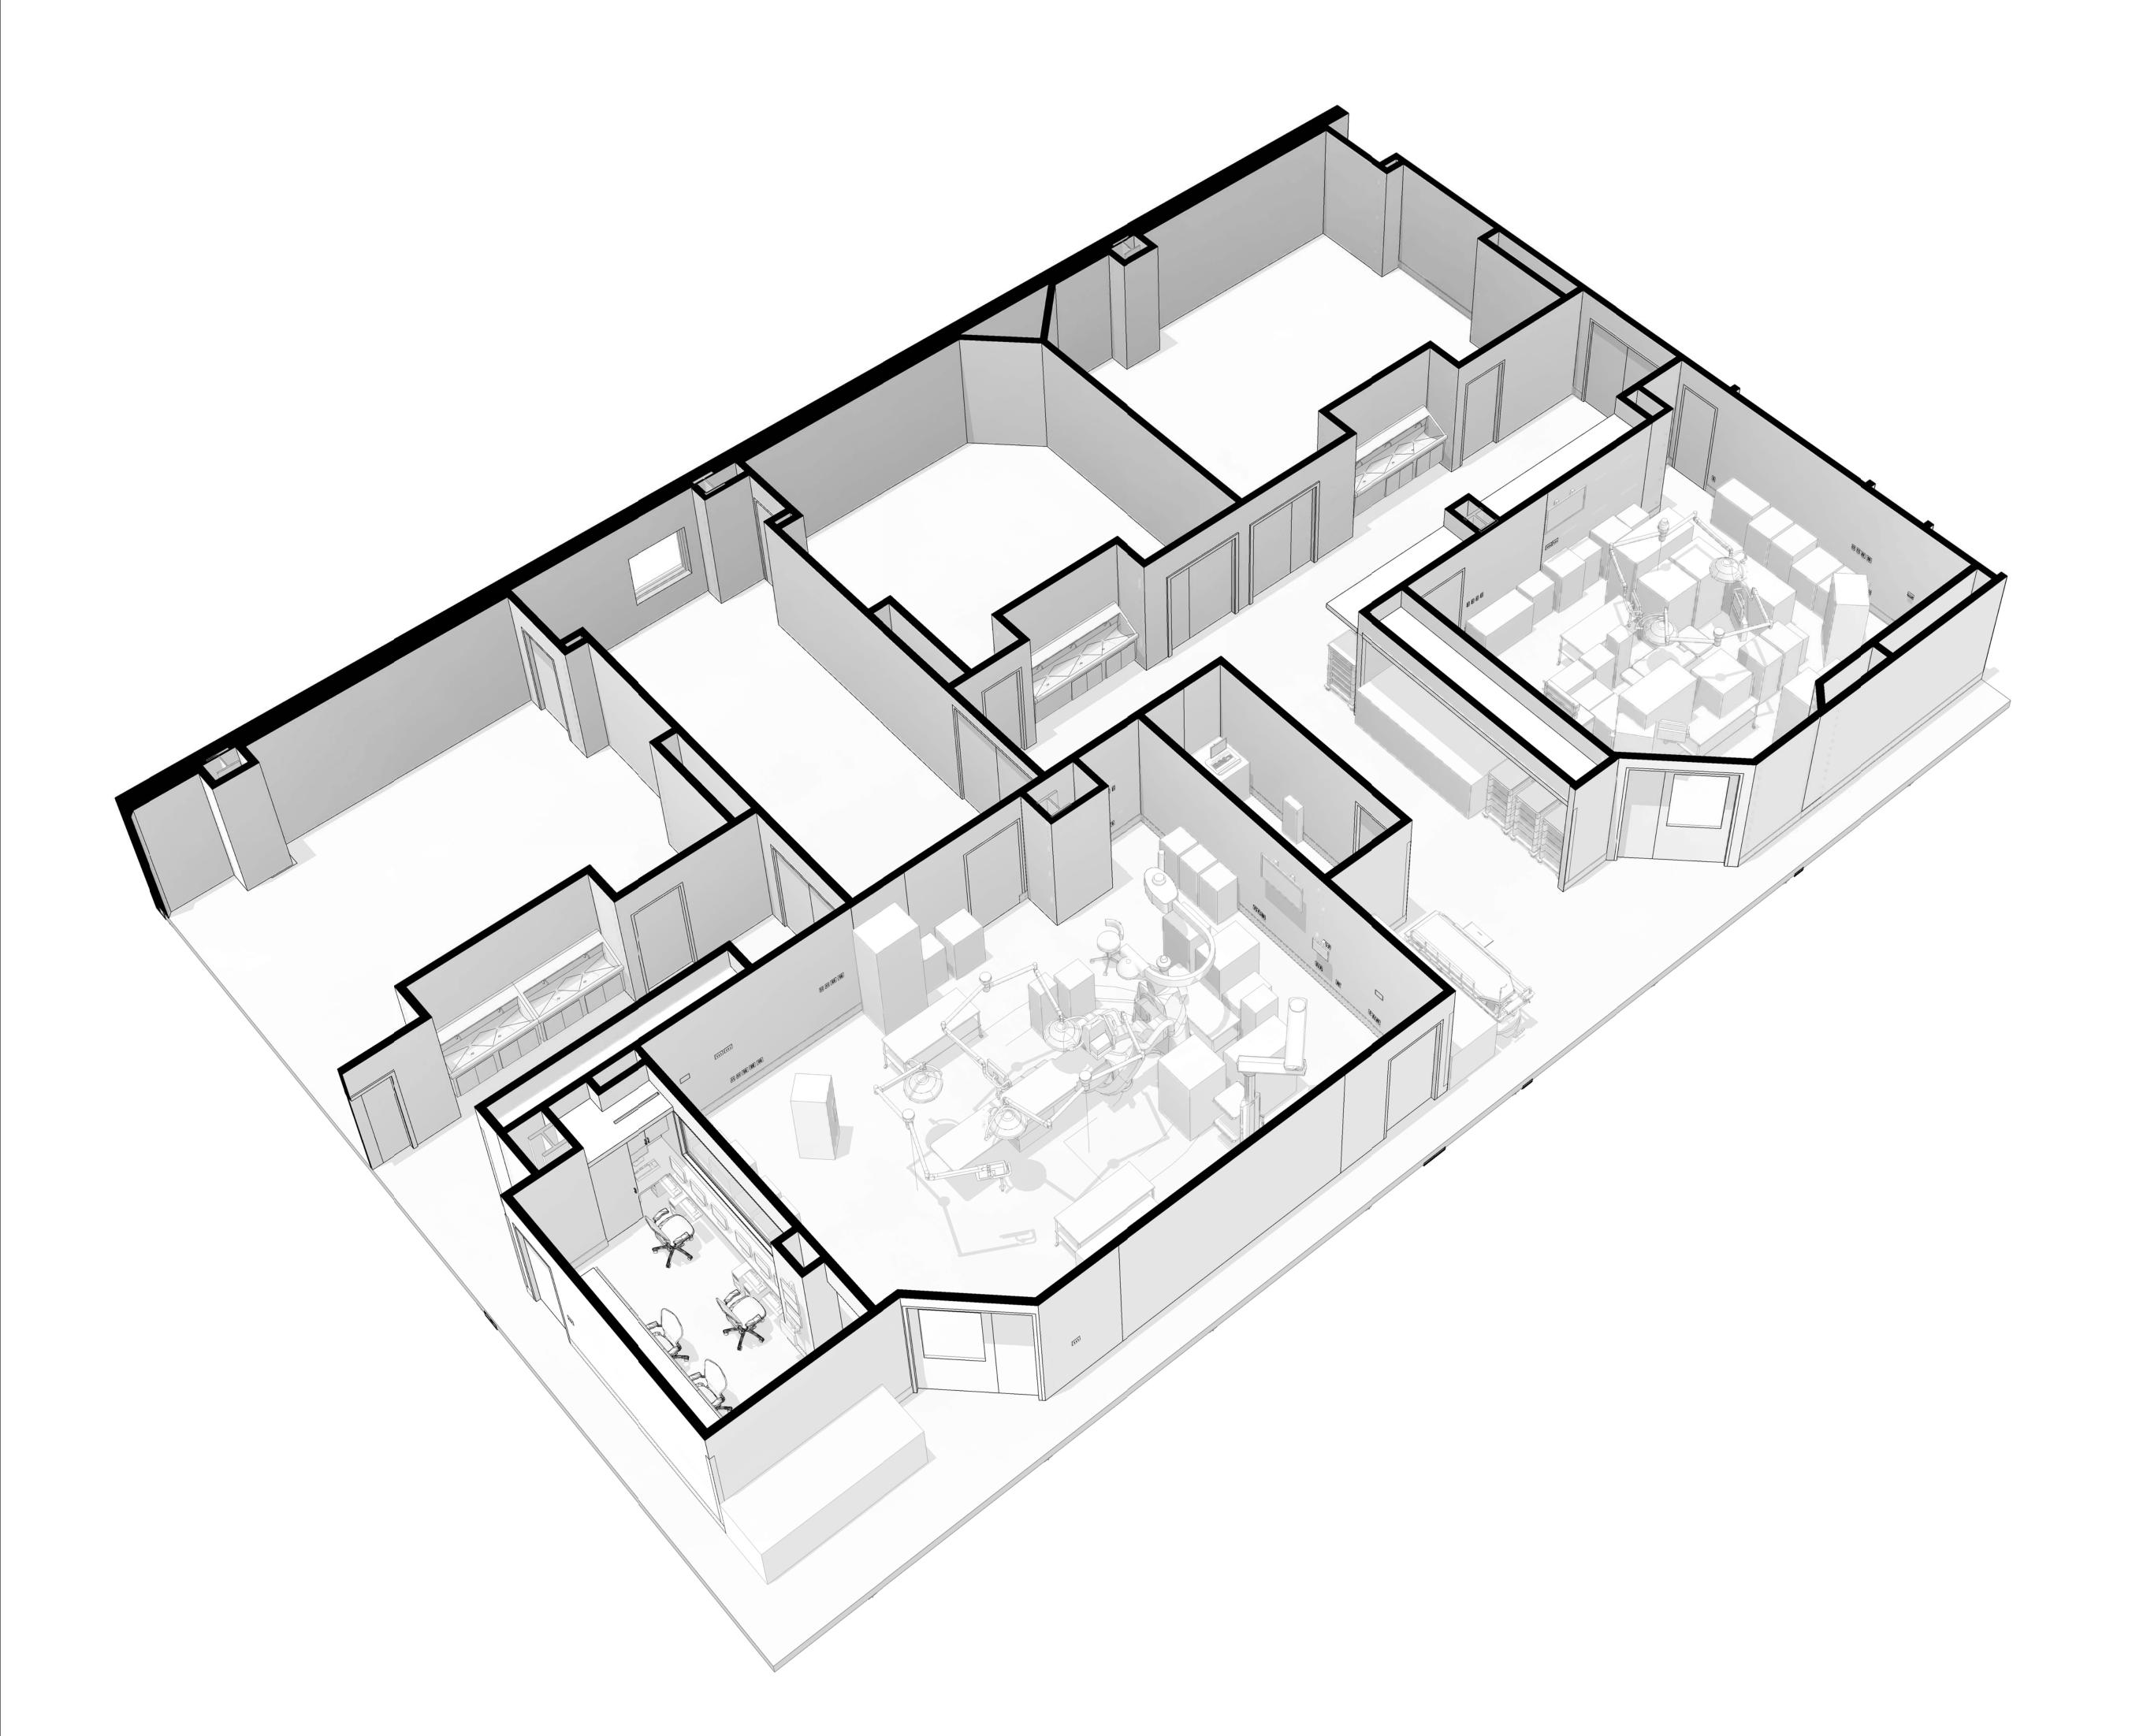

INDEX OF DRAWINGS				
SHEET NUMBER	SHEET NAME	ISSUED FOR BID 07.31.2015	Addendum 1 08.21.2015	3 POC PC 80 TIMELE GOT GETTISSI
A00-00	COVER SHEET	•	•	
A00-00	GENERAL NOTES & ABBREVIATIONS	•		
A00-02	TYPICAL MOUNTING HEIGHTS	•		
A00-10	LIFE SAFETY PLAN	•	•	
A00-40	PARTITION TYPES	•	•	•
A00-50	BASEMENT FINISH AND DOOR SCHEDULE	•		•
A01-0SB	OVERALL SUB-BASEMENT PLAN	•		•
A01-0B	OVERALL BASEMENT FLOOR PLAN	•		•
A01-02	OVERALL LEVEL 2 PLAN	•		_
A03-0B	BASEMENT DEMOLITION PLAN - HYBRID OR & OR 6	•		_
A04-0B	BASEMENT NEW WORK PLAN - HYBRID OR & OR 6  BASEMENT REFLECTED CEILING PLAN - HYBRID OR & OR 6	•	•	9
A05-0B A06-0B1	BASEMENT FINISH PLAN - HYBRID OR & OR 6	•	•	_
A06-0B1	BASEMENT PINISH PLAN - HTBRID OR & OR 6	•	•	
A07-0B1	HYBRID OR EQUIPMENT PLAN & FURNITURE PLAN	•		
A07-0B2	OR #6 EQUIPMENT PLAN	•		
A10-01	HYBRID OR ENLARGED PLAN, RCP & ELEVATIONS	•	•	
A10-02	OR #6 ENLARGED PLAN, RCP & ELEVATIONS	•	•	•
A10-10	INTERIOR ELEVATIONS	•	•	•
A10-20	MILLWORK DETAILS	•	•	•
A10-30	CEILING DETAILS	•		•
S04-0GD	GROUND FLOOR FRAMING PLAN HYBRID OR	•		
304-0GD	GROUND FLOOR FRAMING FLAN HTBRID OR	•		
M00-01	MECHANICAL COVER SHEET		•	
M01-0B	MECHANICAL BASEMENT DUCTWORK DEMOLITION PLAN	•		
M02-0B	MECHANICAL BASEMENT PIPING DEMOLITION PLAN	•	•	
M03-0B	MECHANICAL BASEMENT DUCTWORK PLAN	•	•	
M04-0B	MECHANICAL BASEMENT PIPING PLAN	•	•	•
M04-02	MECHANICAL LEVEL 2 PIPING PLAN	•	•	•
M05-00	MECHANICAL DETAILS	•	•	•
M06-00	MECHANICAL SCHEDULES	•	•	•
P00-01	PLUMBING COVER SHEETS	•	•	•
P01-0B	PLUMBING BASEMENT DEMOLITION PLAN	•	•	•
P01-0B2	PLUMBING SUB-BASEMENT DEMOLITION PLAN	•	•	_
P02-0B P02-0B2	PLUMBING BASEMENT PLAN PLUMBING SUB-BASEMENT PLAN	•	•	_
P03-00	PLUMBING DETAILS	+ -		
P04-00	PLUMBING SCHEDULES	•	•	
F00-01	FIRE PROTECTION COVER SHEET	•	•	•
F01-0B	FIRE PROTECTION BASEMENT PLAN	•	•	•
F02-00	FIRE PROTECTION DETAILS	•		•
E00-01	ELECTRICAL COVER SHEET	•	•	•
E01-0B	ELECTRICAL BASEMENT LIGHTING DEMOLITION PLAN	•		•
E02-0B	ELECTRICAL BASEMENT POWER DEMOLITION PLAN	•	•	_
E03-0B	ELECTRICAL BASEMENT LIGHTING PLAN	•	•	_
	ELECTRICAL BASEMENT POWER PLAN ELECTRICAL LEVEL 2 POWER PLAN	•	•	_
E04-0B	A CARLOS OF THE WALL A CARRYLL IN CLAIM	•	•	٠, ١
E04-0B E04-02		_		_
E04-0B E04-02 E05-0B	ELECTRICAL BASEMENT FIRE ALARM PLAN	•		•
E04-0B E04-02		•	•	•