	P - PLUMBING FIXTURE SCHEDULE															
					PIPE CONNECTION SIZE (IN.)		PRESSURE		FLOW		MOUNTING					
TAG	DESCRIPTION	MFR.	MODEL	ADA (Y/N)	CW	HW	W	V	MIN	MAX	CONTROL	FAUCET / VALVE	WALL	FLOOR	COUNTER	REMARKS
FD-1	FLOOR DRAIN	J.R. SMITH	2005	N/A			3"	2"						Х		PROVIDE WITH WASTE AND TRAP, TRAP PRIMER.
LAV-1	INTEGRAL SINK	F.B.O.		Y	1/2"	1/2"	2"	2"	8	80	1.5 GPM	CHICAGO 786 XKABCP			Х	PROVIDE WITH STOPS AND SUPPLIES, OFFSET GRID DRAIN, TRAP, & INSULATION KIT.
SK-1	S.S. SINK	ELKAY	LRAD 221955	Υ	1/2"	1/2"	2"	2"	8	80	1.5 GPM	CHICAGO 786 XKABCP			Х	PROVIDE WITH STOPS AND SUPPLIES, OFFSET GRID DRAIN, TRAP, & INSULATION KIT.

THERMOSTATIC MIXING VALVE, S59-2025 AS MANUFACTURED BY BRADLEY OR

" REDUCED PRESSURE

- INSTALL PER D.E.P. REQUIREMENTS

THERMOSTATIC MIXING VALVE IS LOCATED ABOVE

CEILING.

NO SCALE

BACKFLOW PREVENTER

WATER PIPING DIAGRAM FOR

STERILIZER

ASSEMBLY" - WATTS 909

APPROVED EQUAL.

1-1/4" TEMPERED — WATER TO STERILIZER

N.T.S

	P - MEDICAL GAS VALVE BOX SCHEDULE													
						VALVE SIZE								
MARK	SERVES	LOCATION	MFR.	MODEL	OX	MA	VAC	N	NO	WAGD	REMARKS			
ZVB-1	PRE/POST OP RECOVERY	CORRIDOR	BEACON MEDAES	SSB-821-01	1/2"	1/2"	3/4"			-				
ZVB-2	C-SECTION OR	CORRIDOR	BEACON MEDAES	SSB-821-01	1/2"	1/2"	1-1/4"	1/2"	1/2"	3/4"				
ZVB-3	C-SECTION OR	CORRIDOR	BEACON MEDAES	SSB-821-01	1/2"	1/2"	1-1/4"	1/2"	1/2"	3/4"				

OUTLET

→ NITROGN |

OUTLET

NITROUS

OXIDE

OUTLET

MANUFACTURED BY BEACON MEDAES OR APPROVED EQUAL.

DETAIL NOTES:

INDEPENDENTLY

FROM ROOF DECK.

SUPPORT CEILING TILE

MED. AIR

WAGD

OUTLET

1. PLUMBING CONTRACTOR SHALL REFER TO ARCHITECTURAL DRAWINGS FOR LOCATIONS OF

2. PROVIDE HOSE ASSEMBLIES FOR CEILING DROPS WITH HEAVY DUTY, DOUBLE RETRACTOR


3. REFER TO SCHEDULE FOR QUANTITY AND TYPES OF OUTLETS TO BE INCLUDED IN CEILING

MEDICAL GAS CEILING PANEL DETAIL


MEDICAL GAS CEILING OUTLETS. MEDICAL GAS INLETS AND OULETS SHALL BE AS

SIMILAR TO BEACON MEDAES MODEL 6-132002-00 FOR ALL INLETS AND OUTLETS.


OUTLET

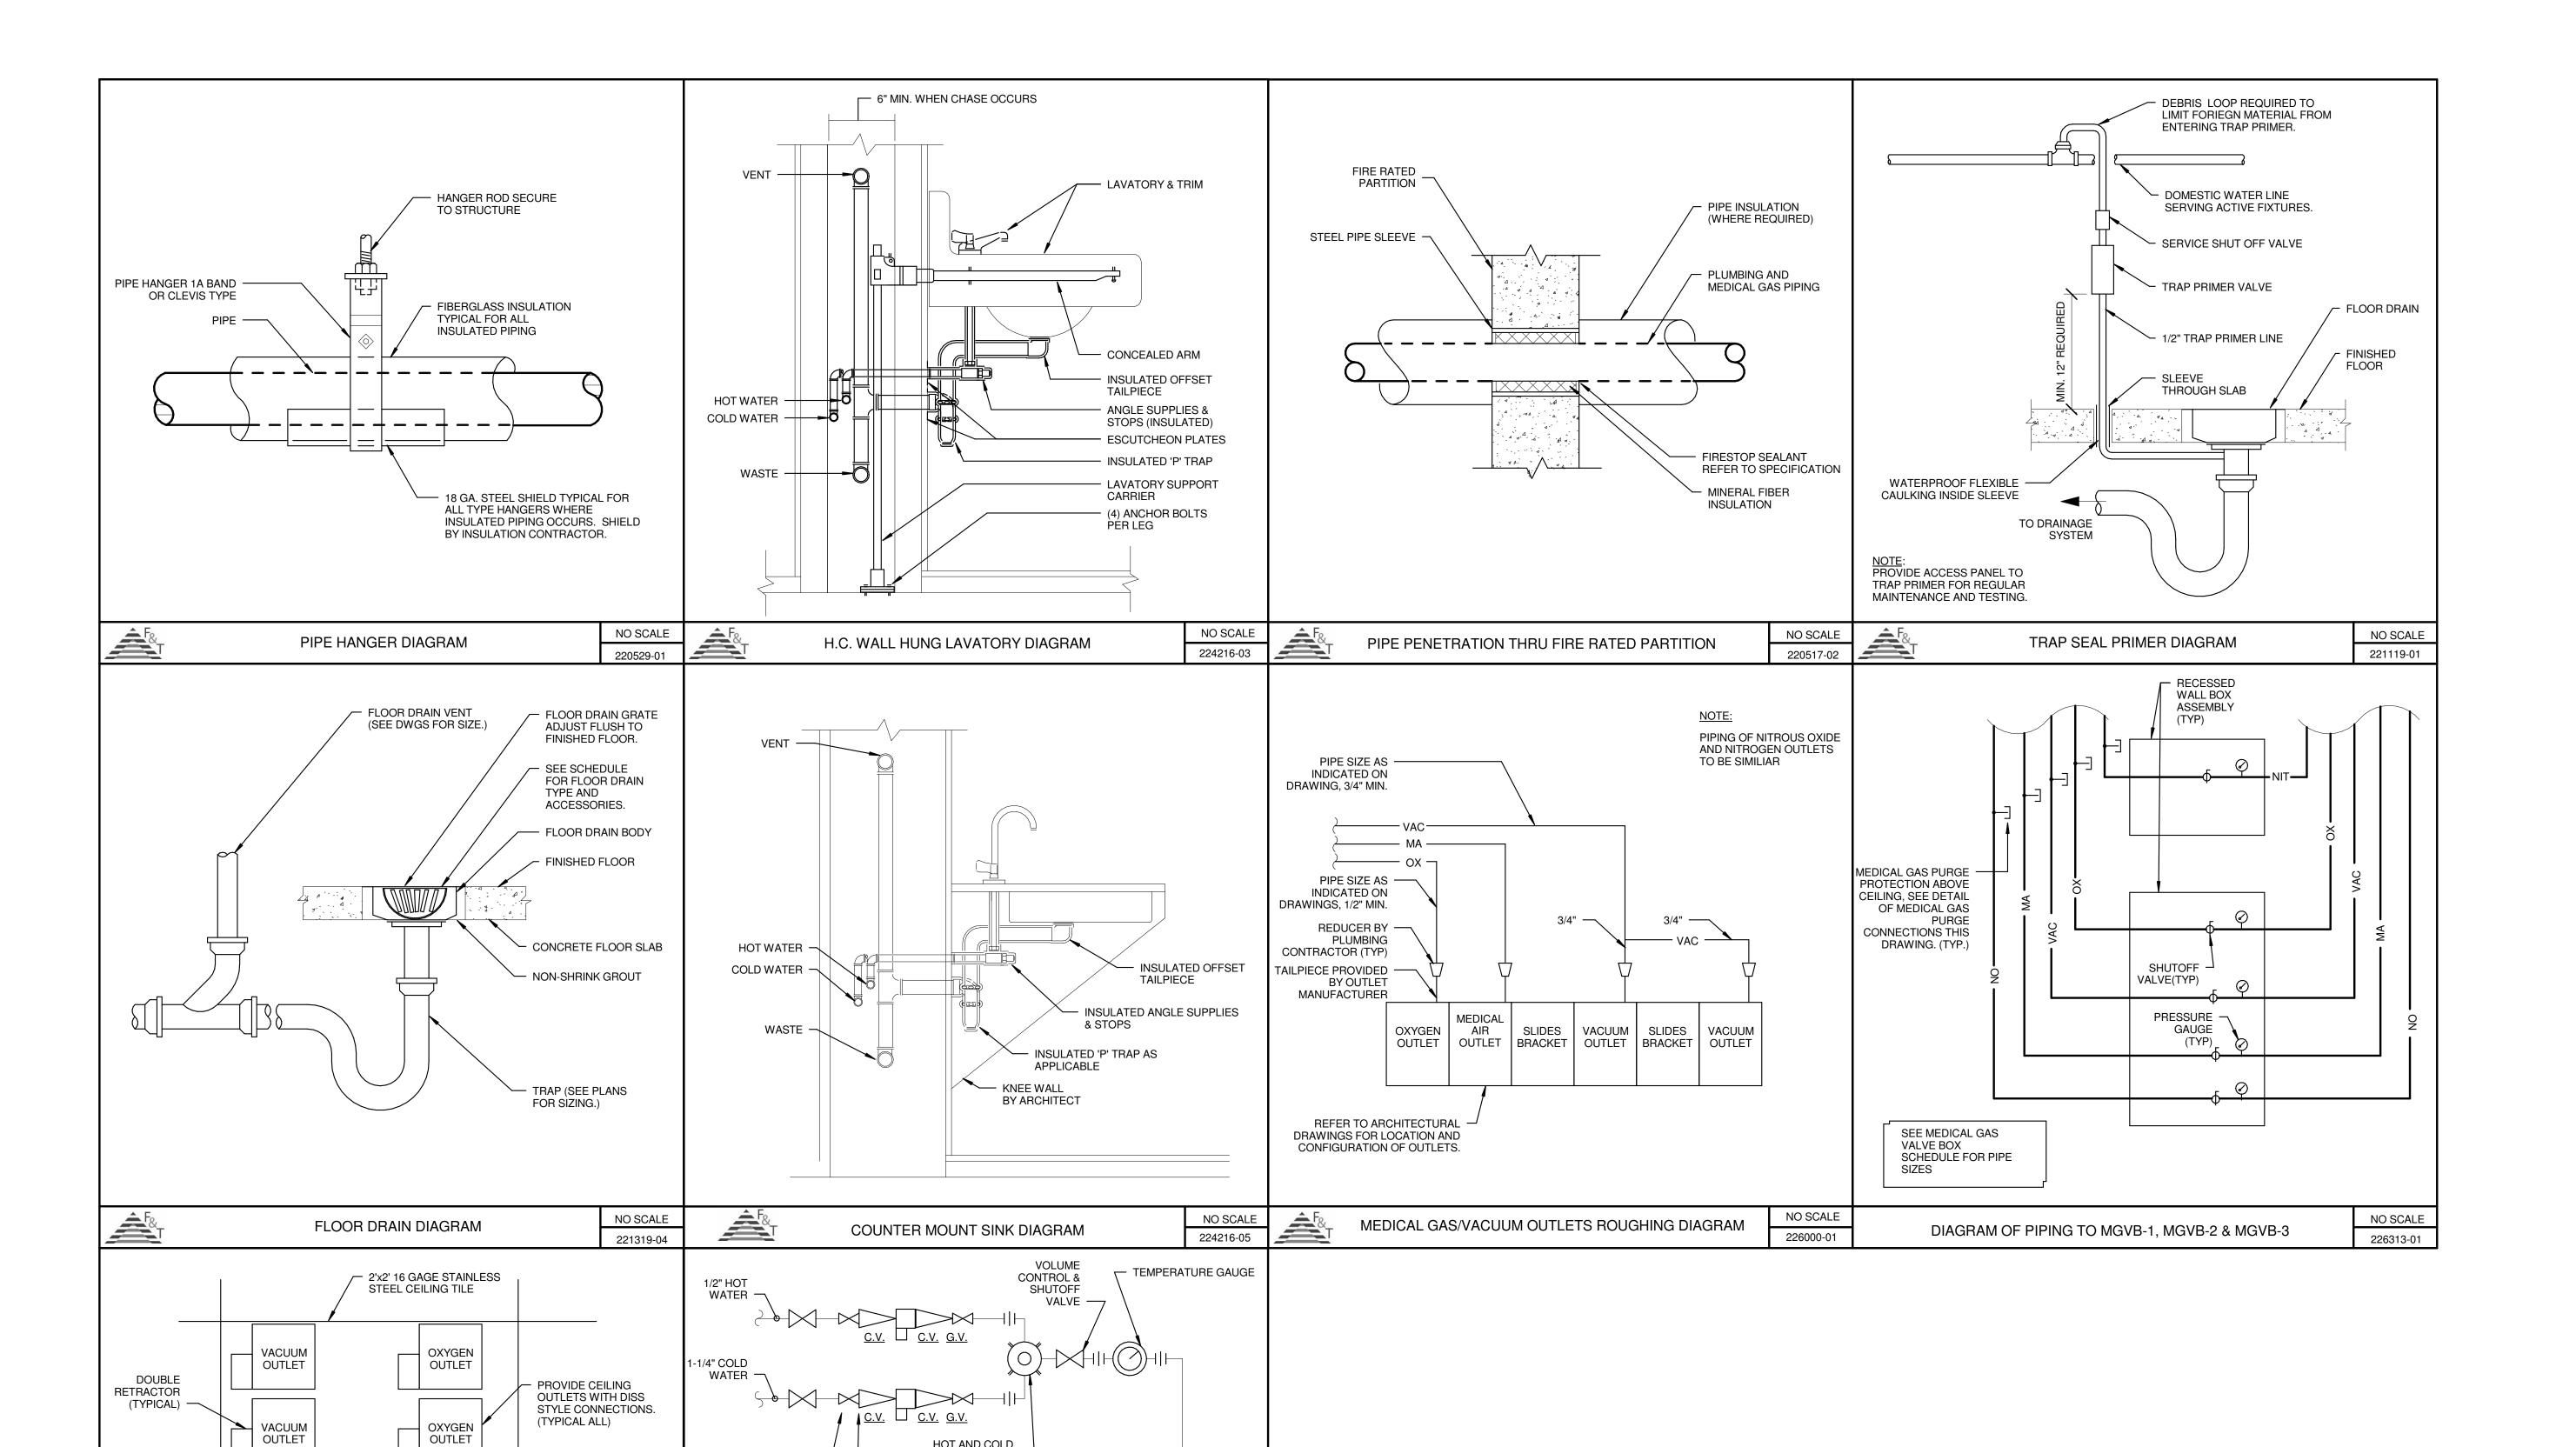




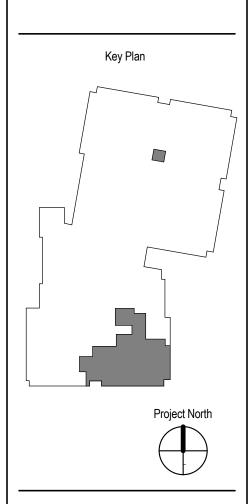



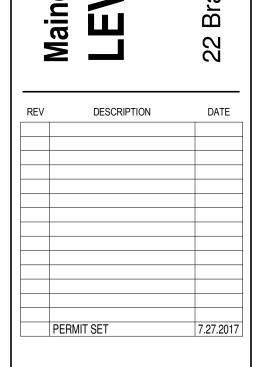

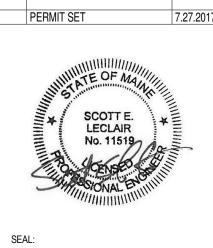

PROJECT NUMBER: 2017009 07/27/2017 SHEET TITLE AND NUMBER:

PLUMBING SCHEDULES AND **DETAILS**