



☐ Architecture Space Planning Value Deelgn

434 Cumberland Avenue Portland, NE 04101 Phone: (207)774-4441 Fax: (207)774-4016

www.CWSarch.com

YC PORTLAND L.P.
C/O AVESTA 307 CUMBERLAND AVE

> PORTLAND, MAINE 04101 |207) 553-7777

🔲 Client:

YORK-CUMBERLAND HOUSING DEVELOPMENT

LOGAN PLACE

PORTLAND, MAINE


Project No:

AS NOTED

☐ Drawing Title: THIRD FLOOR ELECTRICAL PLAN

JANUARY 14, 2004

Drawing Number:

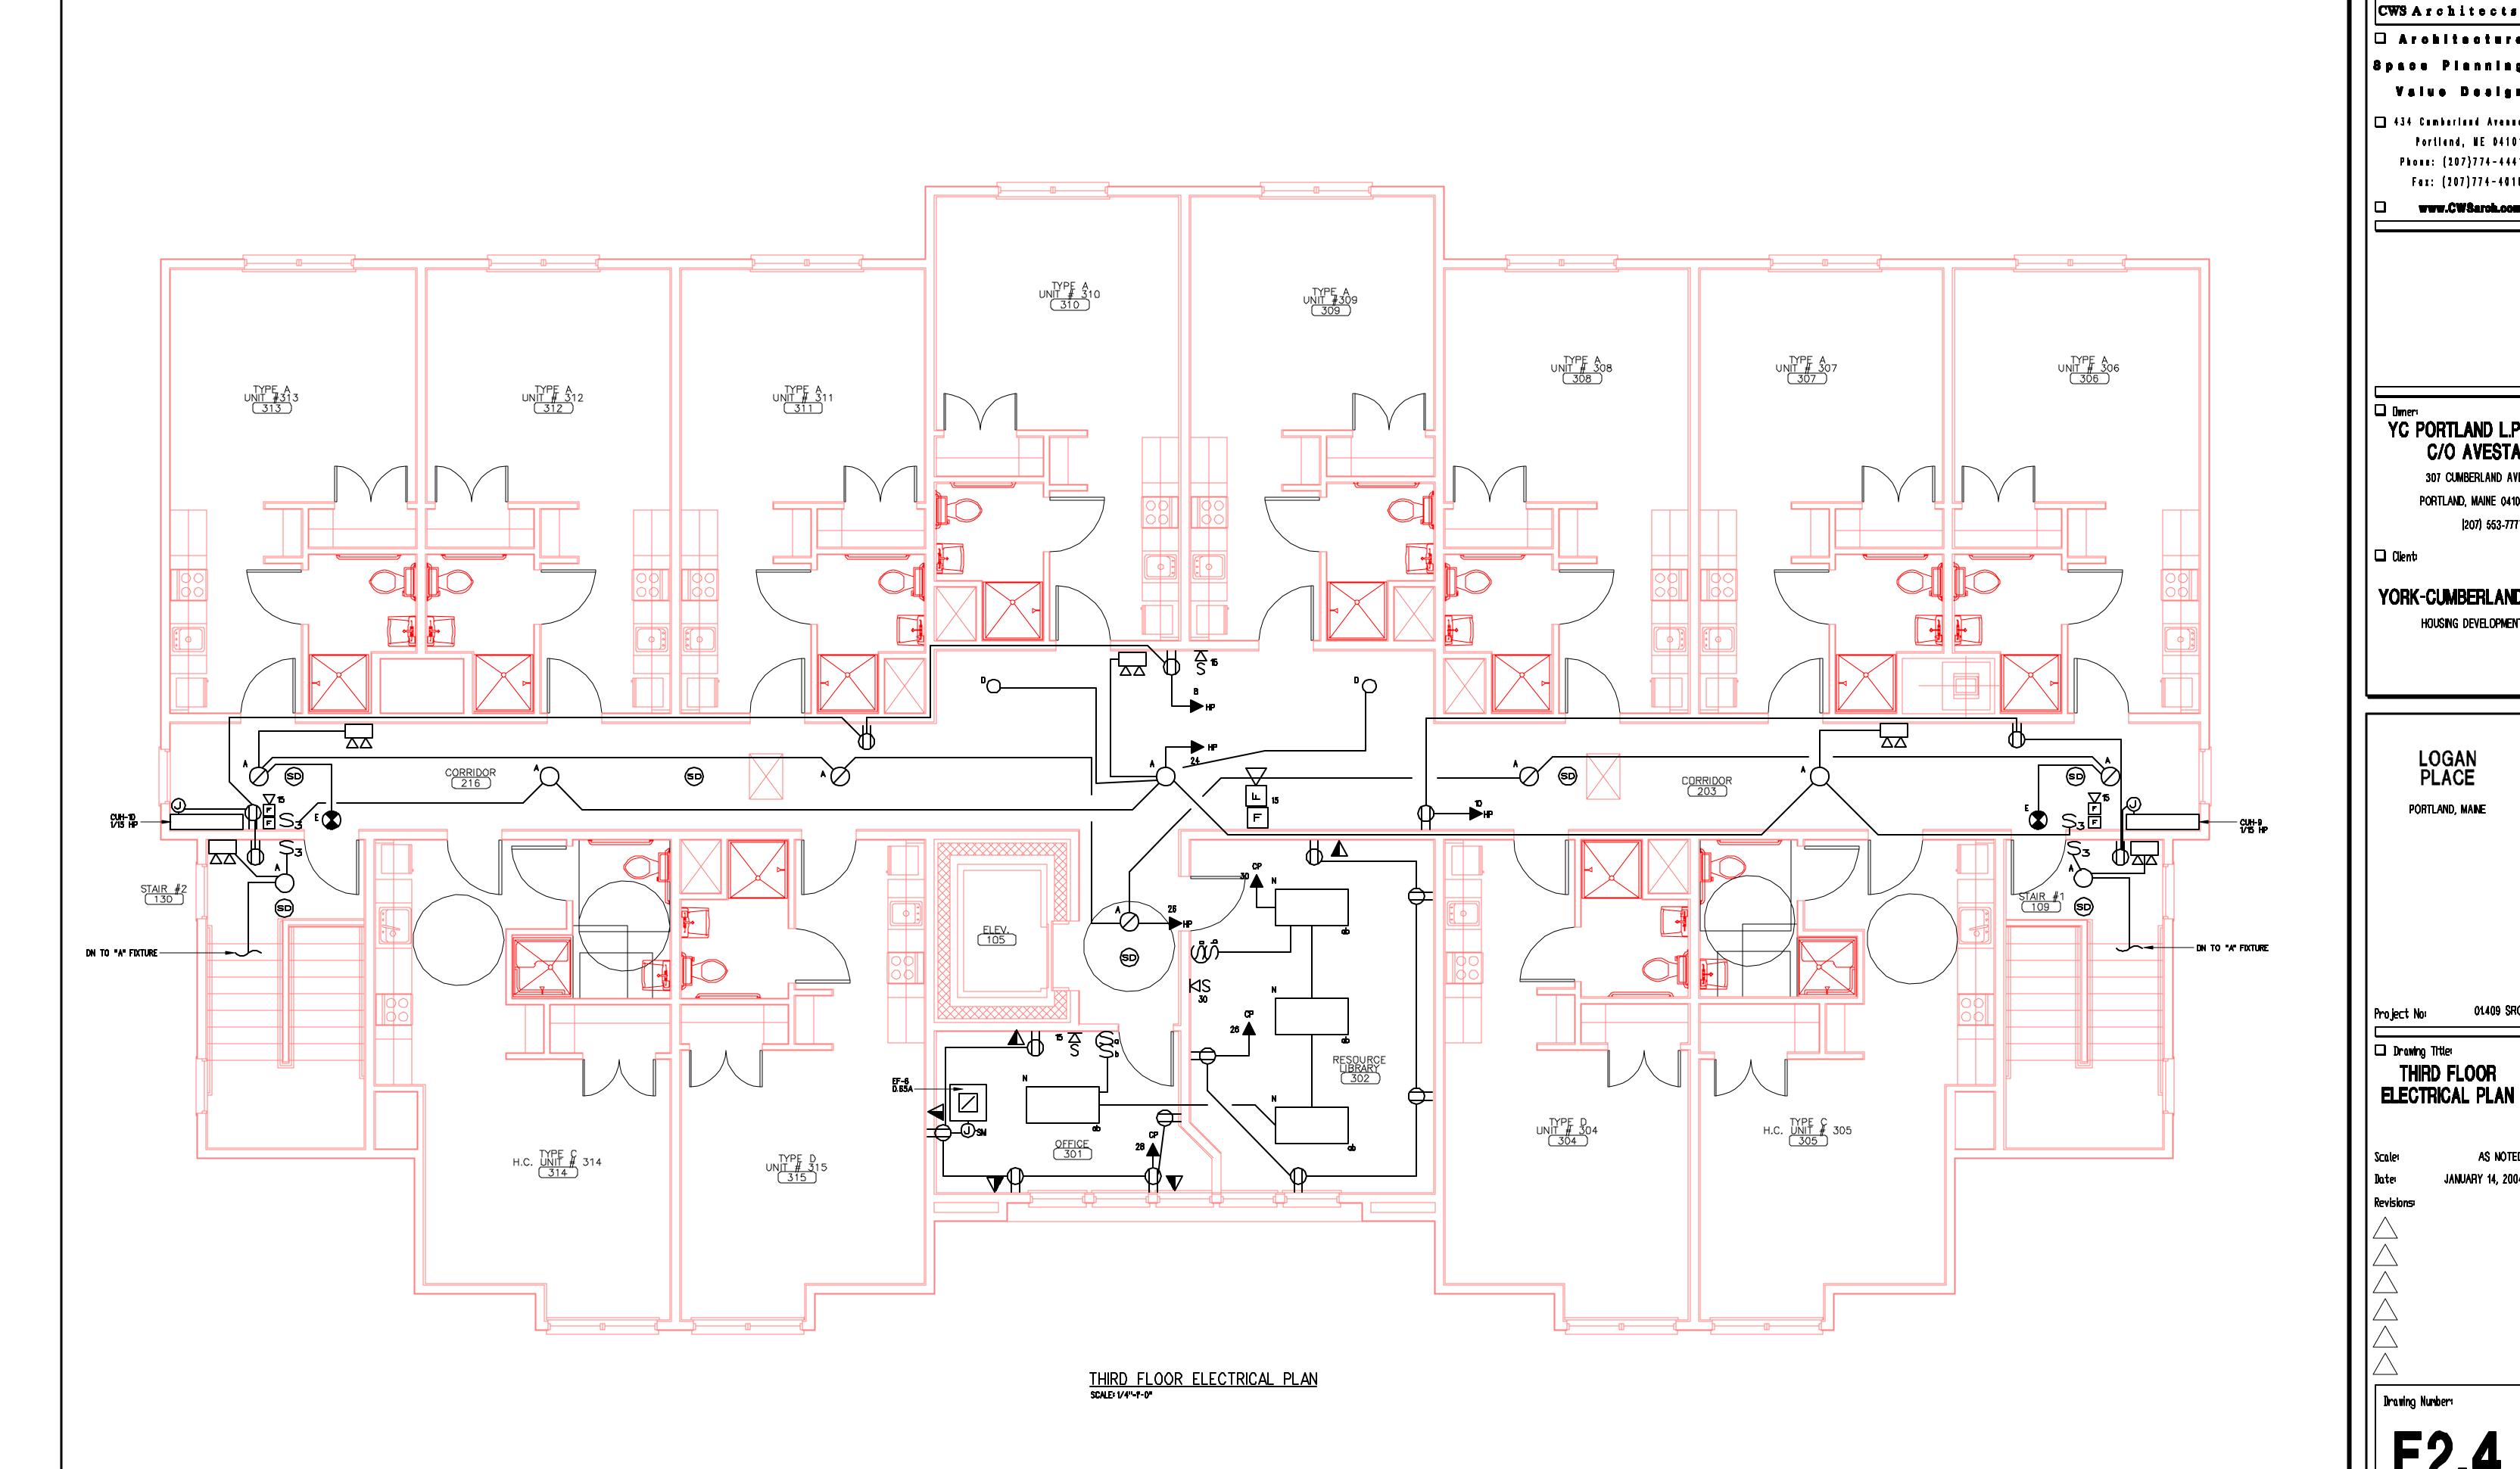

...\Drawings\E2.4.dgn 05/10/04 04:04:59 PM