



CWS Architects ☐ Architecture

Space Planning Value Dealgn

☐ 434 Cumberland Avenue Portland, NE 04101 Phone: (207)774-4441 Fax: (207)774-4016

www.CWSarch.com

YC PORTLAND L.P.
C/O AVESTA 307 CUMBERLAND AVE

PORTLAND, MAINE 04101 |207) 553-7777

YORK-CUMBERLAND HOUSING DEVELOPMENT

LOGAN PLACE

PORTLAND, MAINE


01409 SRO Project No:

☐ Drawing Title:

ATTIC SANITARY PLUMBING PLAN AS NOTED

JANUARY 14, 2004

Drawing Number:

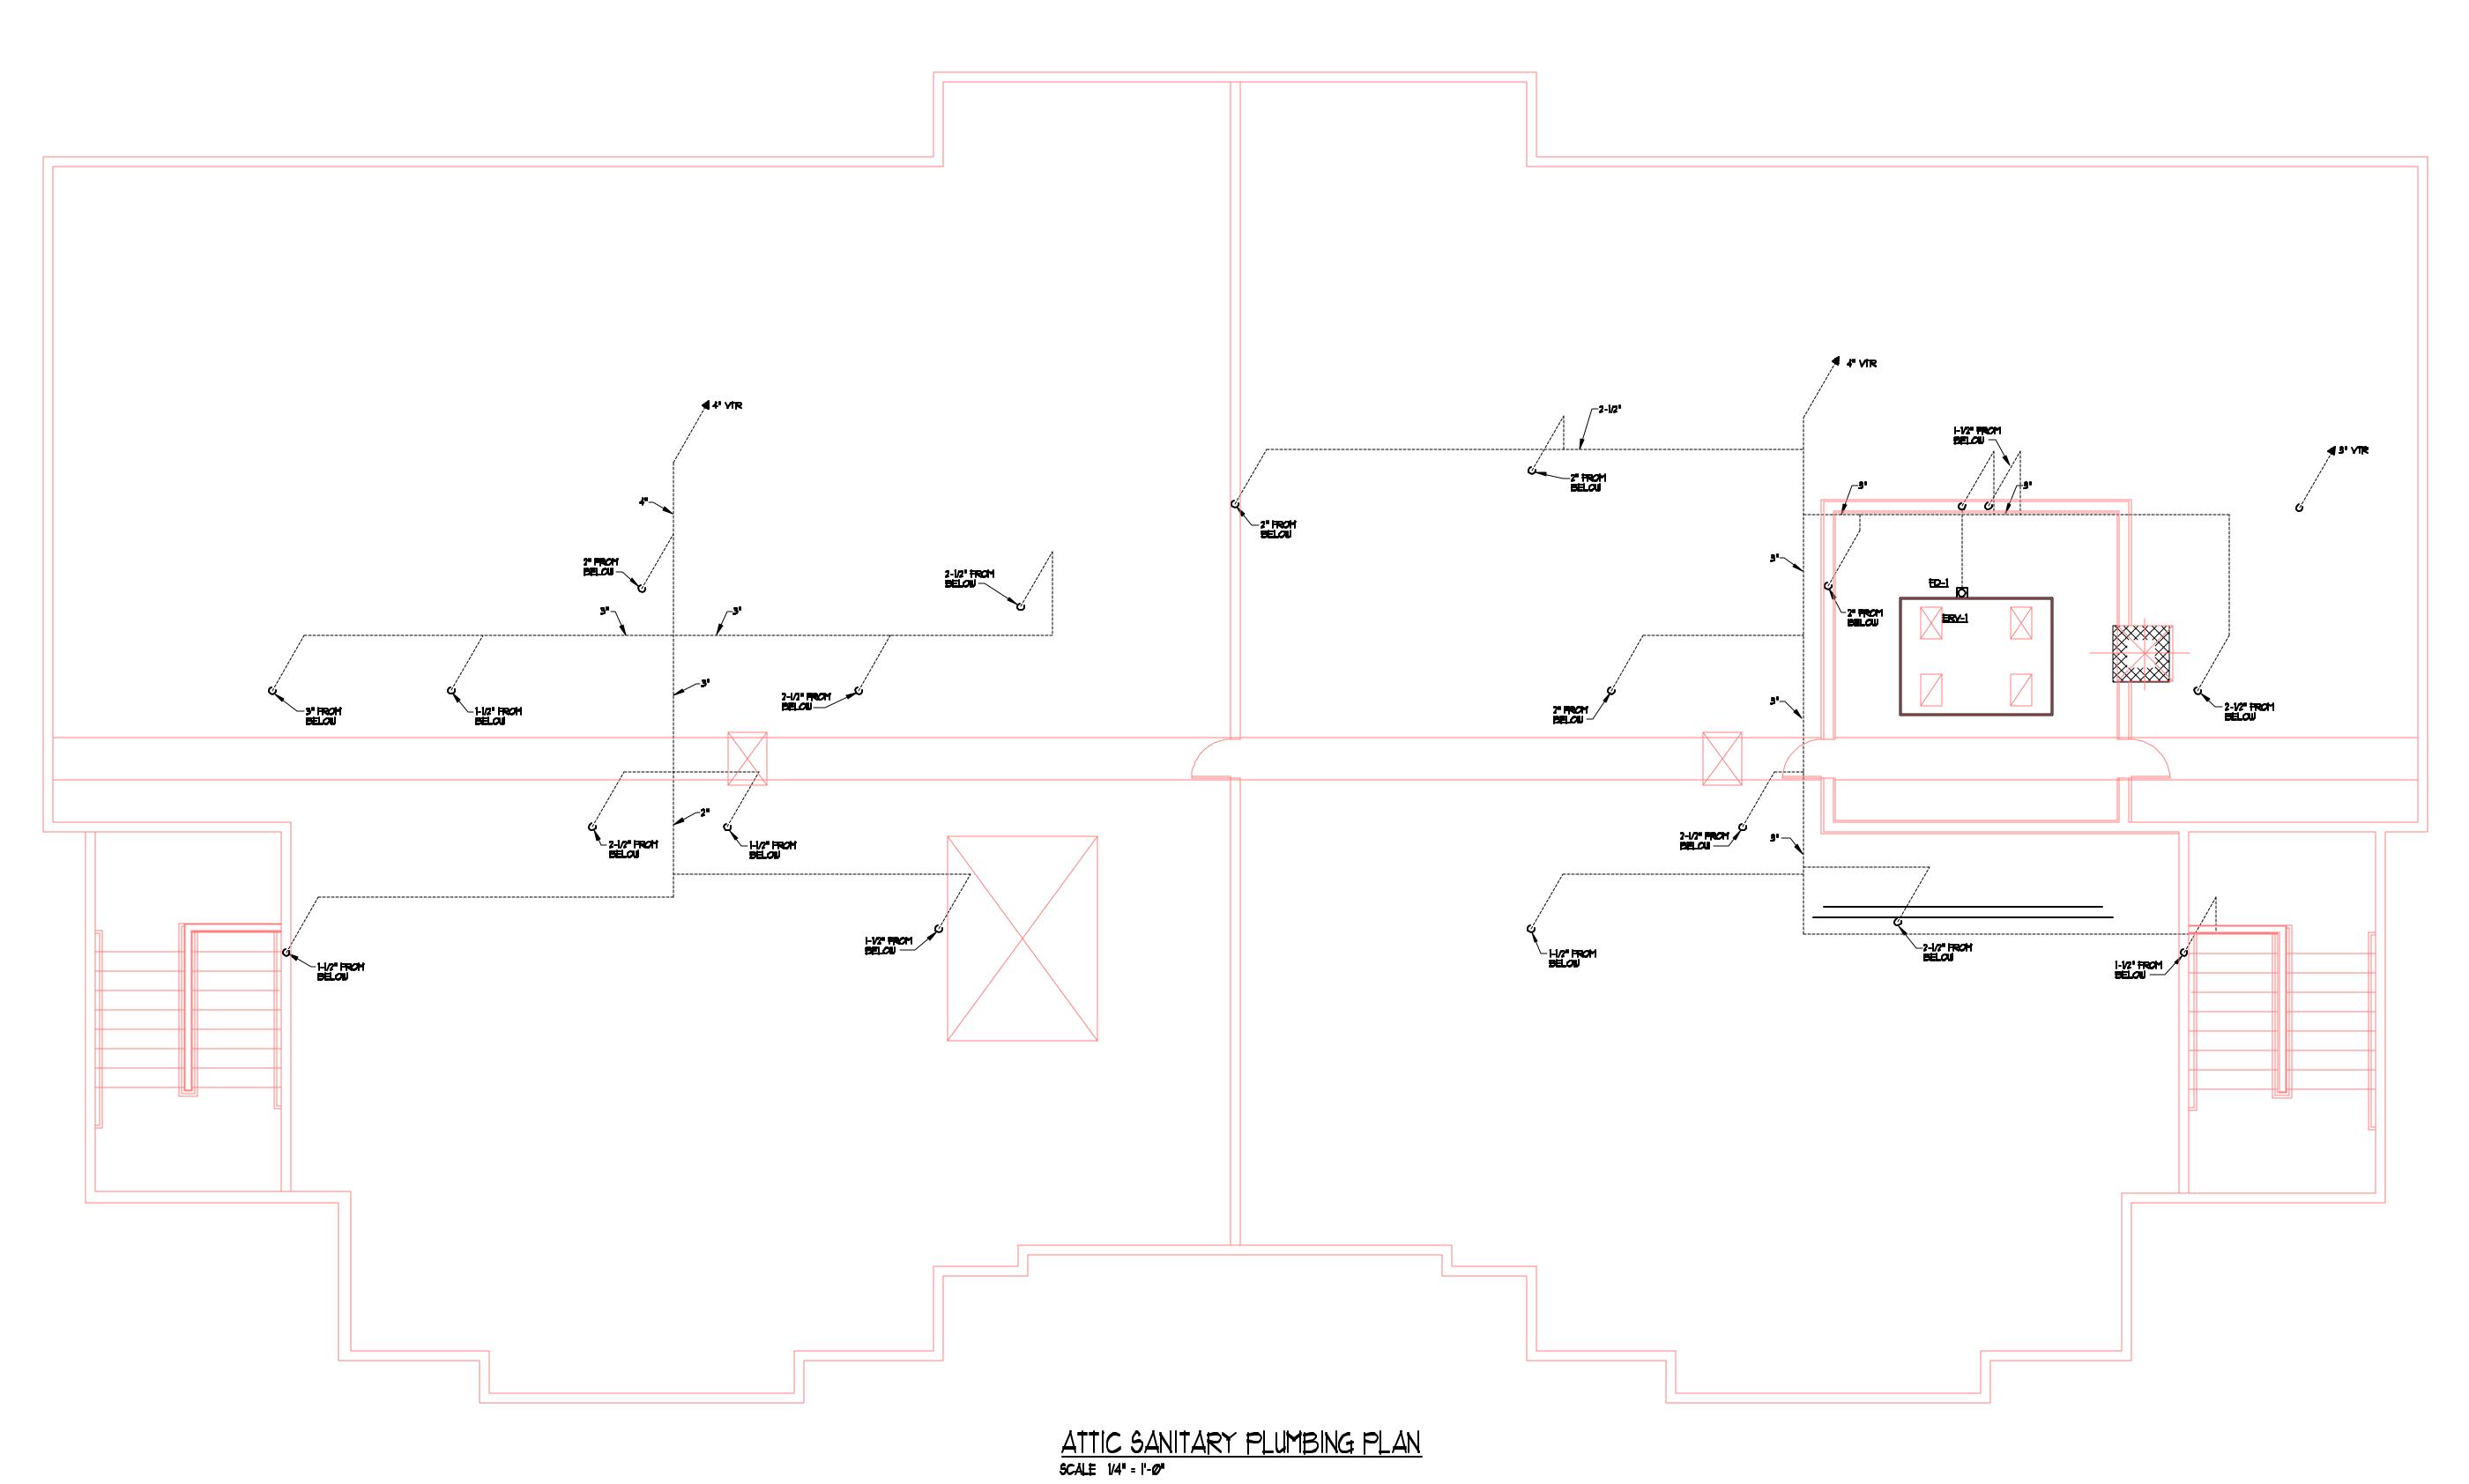

...\Drawings\m2.4.dgn 05/10/04 04:11:14 PM