ARCHITECTS

LIB 2017 SHEET TITLE:

DEMO PLAN

D1.2



LIFE SAFETY SYMBOLS

E EXIT SIGN

EMERGENCY LIGHTING

H FIRE ALARM SYSTEM - HORN

-S FIRE ALARM SYSTEM - STROBE

FIRE EXTINGUISHER- WALL MOUNTED

FIRE EXTINGUISHER- WALL MOUNTED IN CABINET

S SMOKE DETECTOR

ADA DOOR OPENER


CARBON MONOXIDE DETECTOR

HS HORN/ STROBE

P PULL STATION

NOTE: EXISTING FLOOR TWO LIFE SAFETY DEVICES TO REMAIN AS MUCH AS POSSIBLE. THE FIXTURES THAT HAVE BEEN ADDED INCLUDE THE HORN/STROBES AND SMOKE DETECTORS SHOWN IN THE MENS AND WOMENS RTC & DETOX ROOMS.

NOTE: FIXTURE DESIGNATED WITH "N" IS

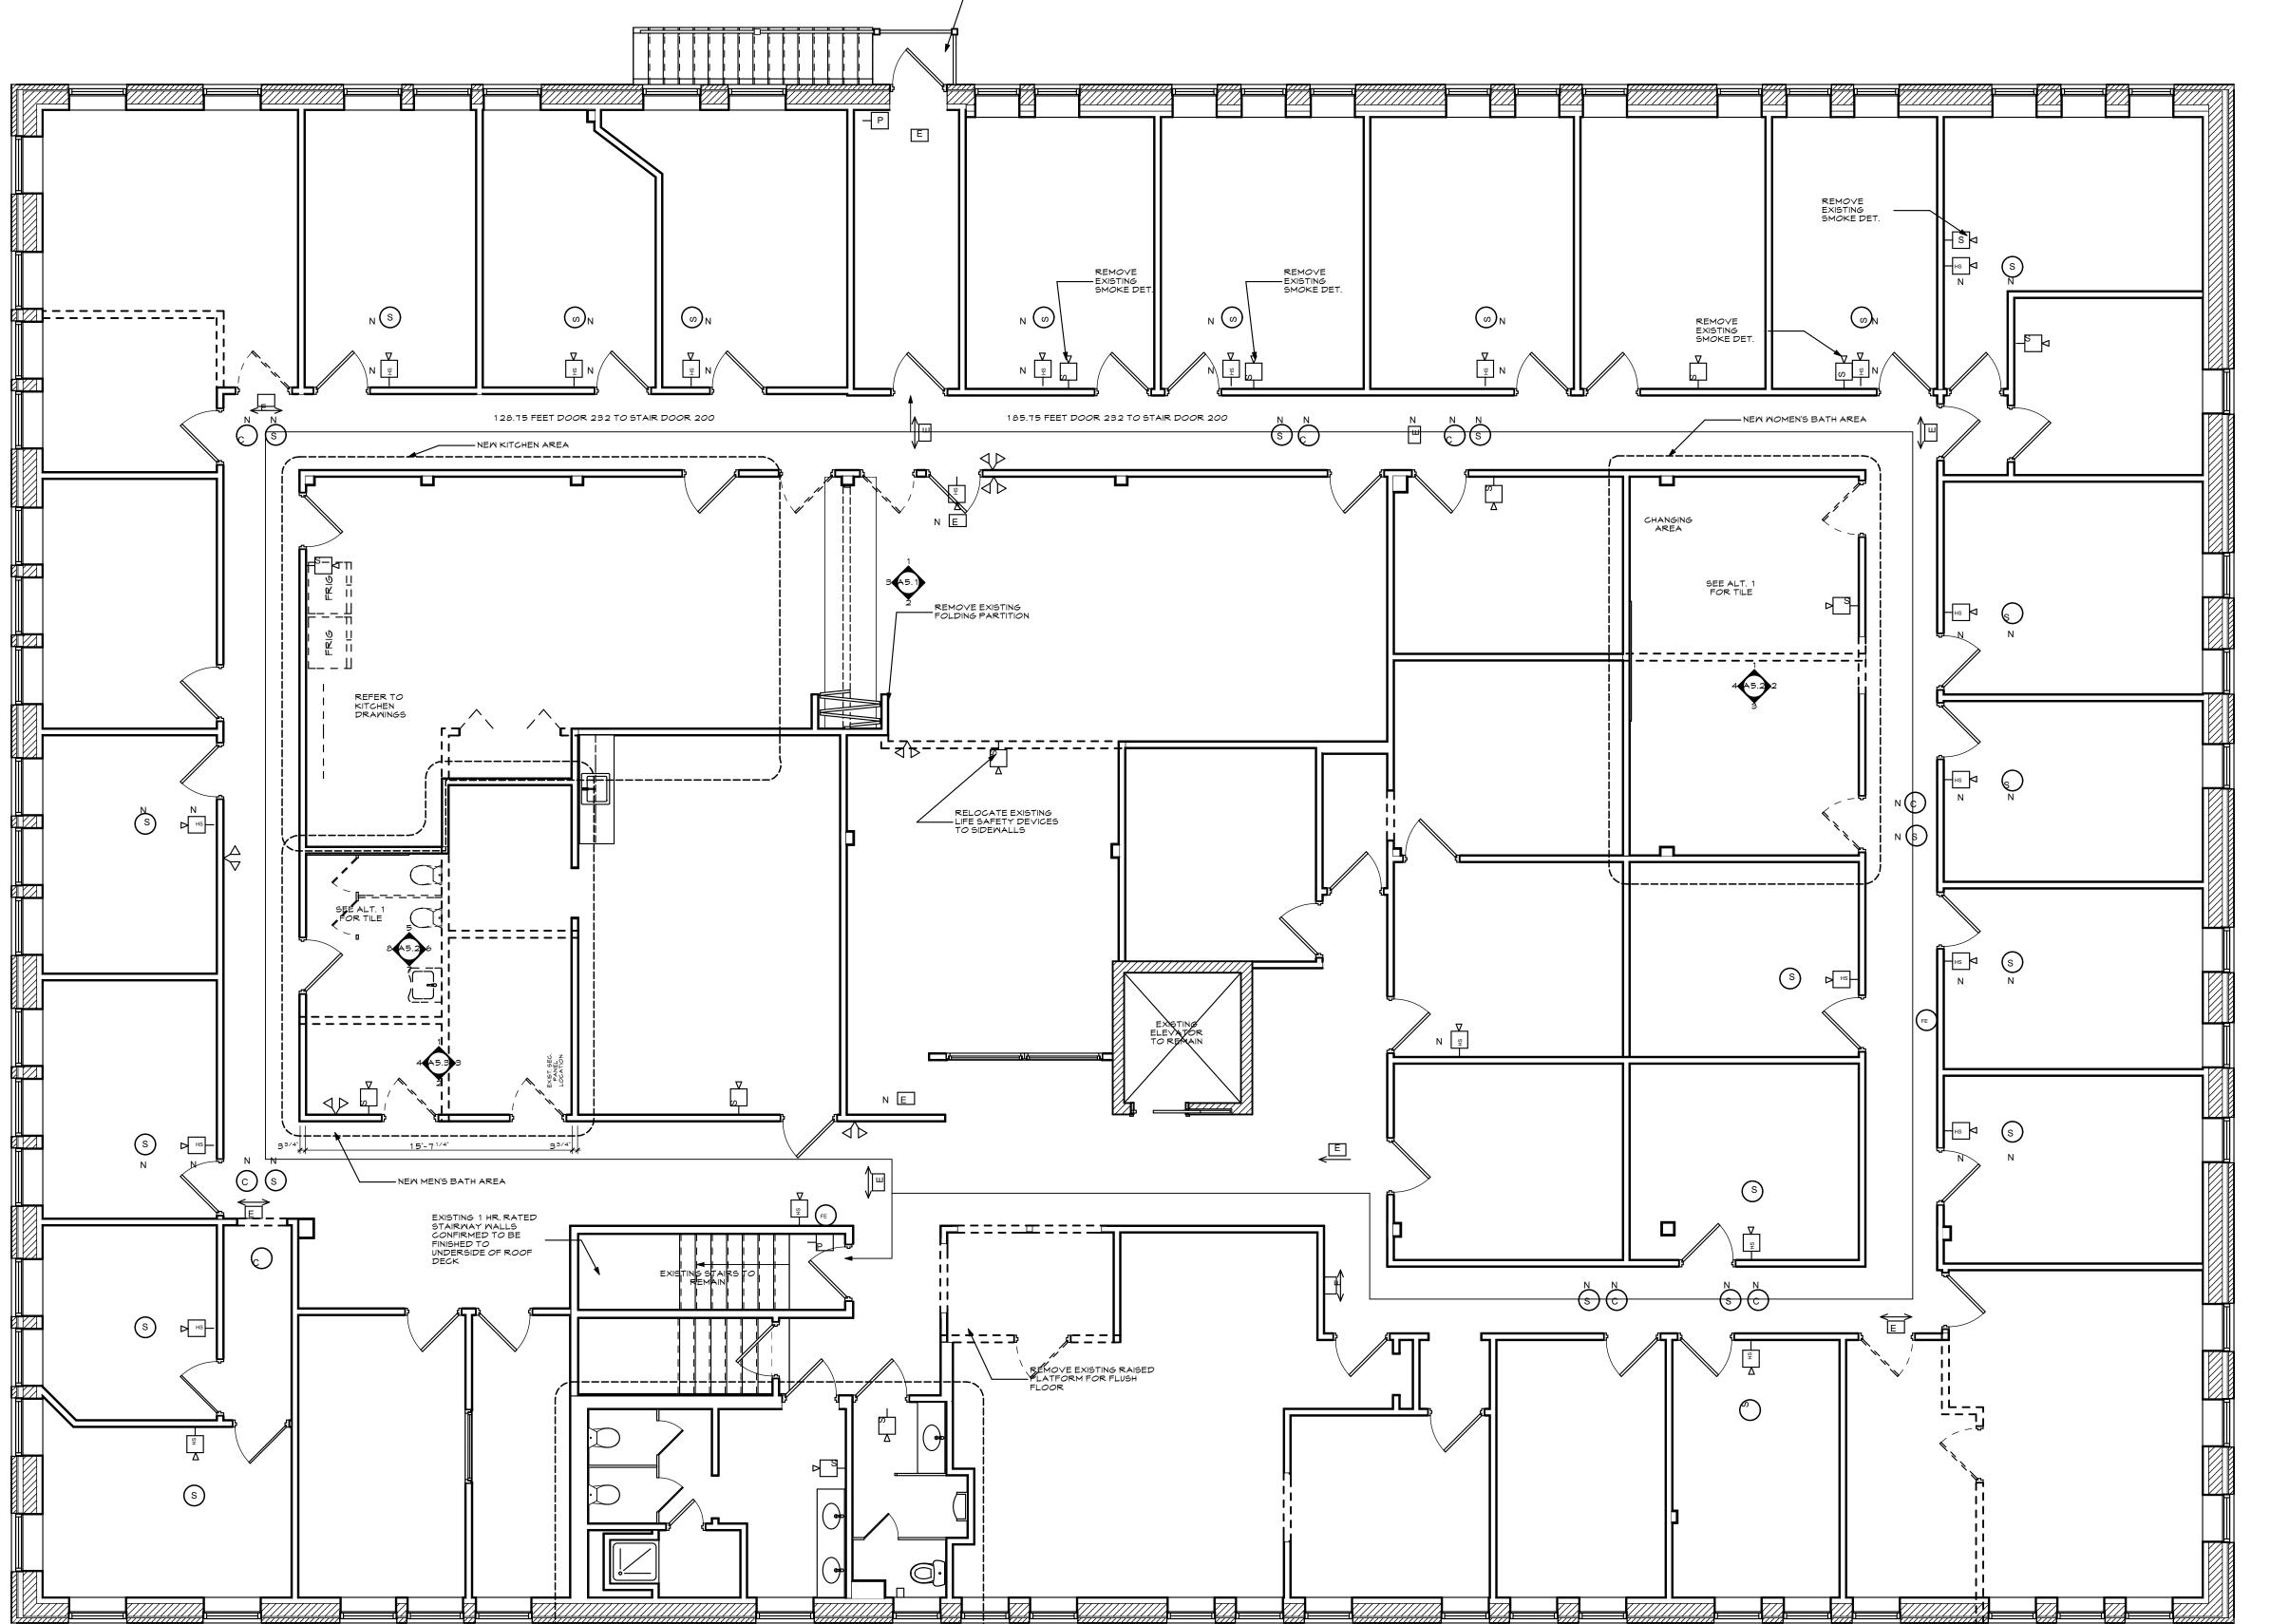

______ MEN'S BATH AREA- EXISTING — FINISHES AND FIXTURES TO REMAIN SECOND FLOOR DEMO PLAN 1 SECONU T D1.2 SCALE: 3/16" = 1'-0"