Sheet #

01 - Architectural

02 - Interiors

03 -Mechanical

04 -Plumbing

05 -Electrical

E0.0

E1.1

ID1.1

COVER SHEET

DEMOLITION PLANS

INTERIOR ELEVATIONS

INTERIOR ELEVATIONS

INTERIOR DESIGN PLANS

MECHANICAL FLOOR PLANS

MILLWORK DETAILS

REFLECTED CEILING PLANS PARTIAL BUILDING SECTIONS

CODE ANALYSIS TEXT, SYMBOLS AND RATINGS

PARTIAL THIRD FLOOR PLAN AND ROOF PLAN

MECHANICAL FLOOR PLAN, SPECIFICATIONS AND DETAILS

PLUMBING AND MECHANICAL ABBREVIATIONS AND LEGENDS PLUMBING AND MECHANICAL FLOOR PLANS - DEMOLITION

ELECTRICAL LEGENDS. ABBREVIATIONS AND GENERAL NOTES

THIRD FLOOR LIGHTING AND POWER AND SYSTEMS PART PLANS

POWER AND DATA ROUTING LOCATIONS BASEMENT AND THIRD FLOORS

ENLARGED BENCH PLANS AND DETAILS

MECHANICAL DETAILS AND SCHEDULES

PLUMBING FLOOR PLANS - DRAINAGE PLUMBING FLOOR PLANS - SUPPLY PLUMBING PART PLANS - SUPPLY

PLUMBING DETAILS AND SCHEDULES

ELECTRICAL SCHEDULES AND DETAILS

PAYSON-SMITH HALL CHEMISTRY LAB RENOVATION

Owner:

UNIVERSITY OF SOUTHERN MAINE

96 Falmouth Street, Portland, ME, 04101

ARCHITECT:

Lavallee Brensinger Architects


155 Dow Street, Suite 400, Manchester, NH 03101 40 Cambridge Street, Charlestown, MA 02129 NH: 603.622.5450 MA: 617.398.2035 www.LBPA.com


MEPFP ENGINEER:

Allied Engineering, Inc. 160 Veranda Street Portland, Maine 04103 P: (207) 221-2260 F: (207) 221-2266 www.allied-eng.com

UNIVERSITY OF SOUTHERN MAINE

96 Falmouth Street, Portland, ME, 04101

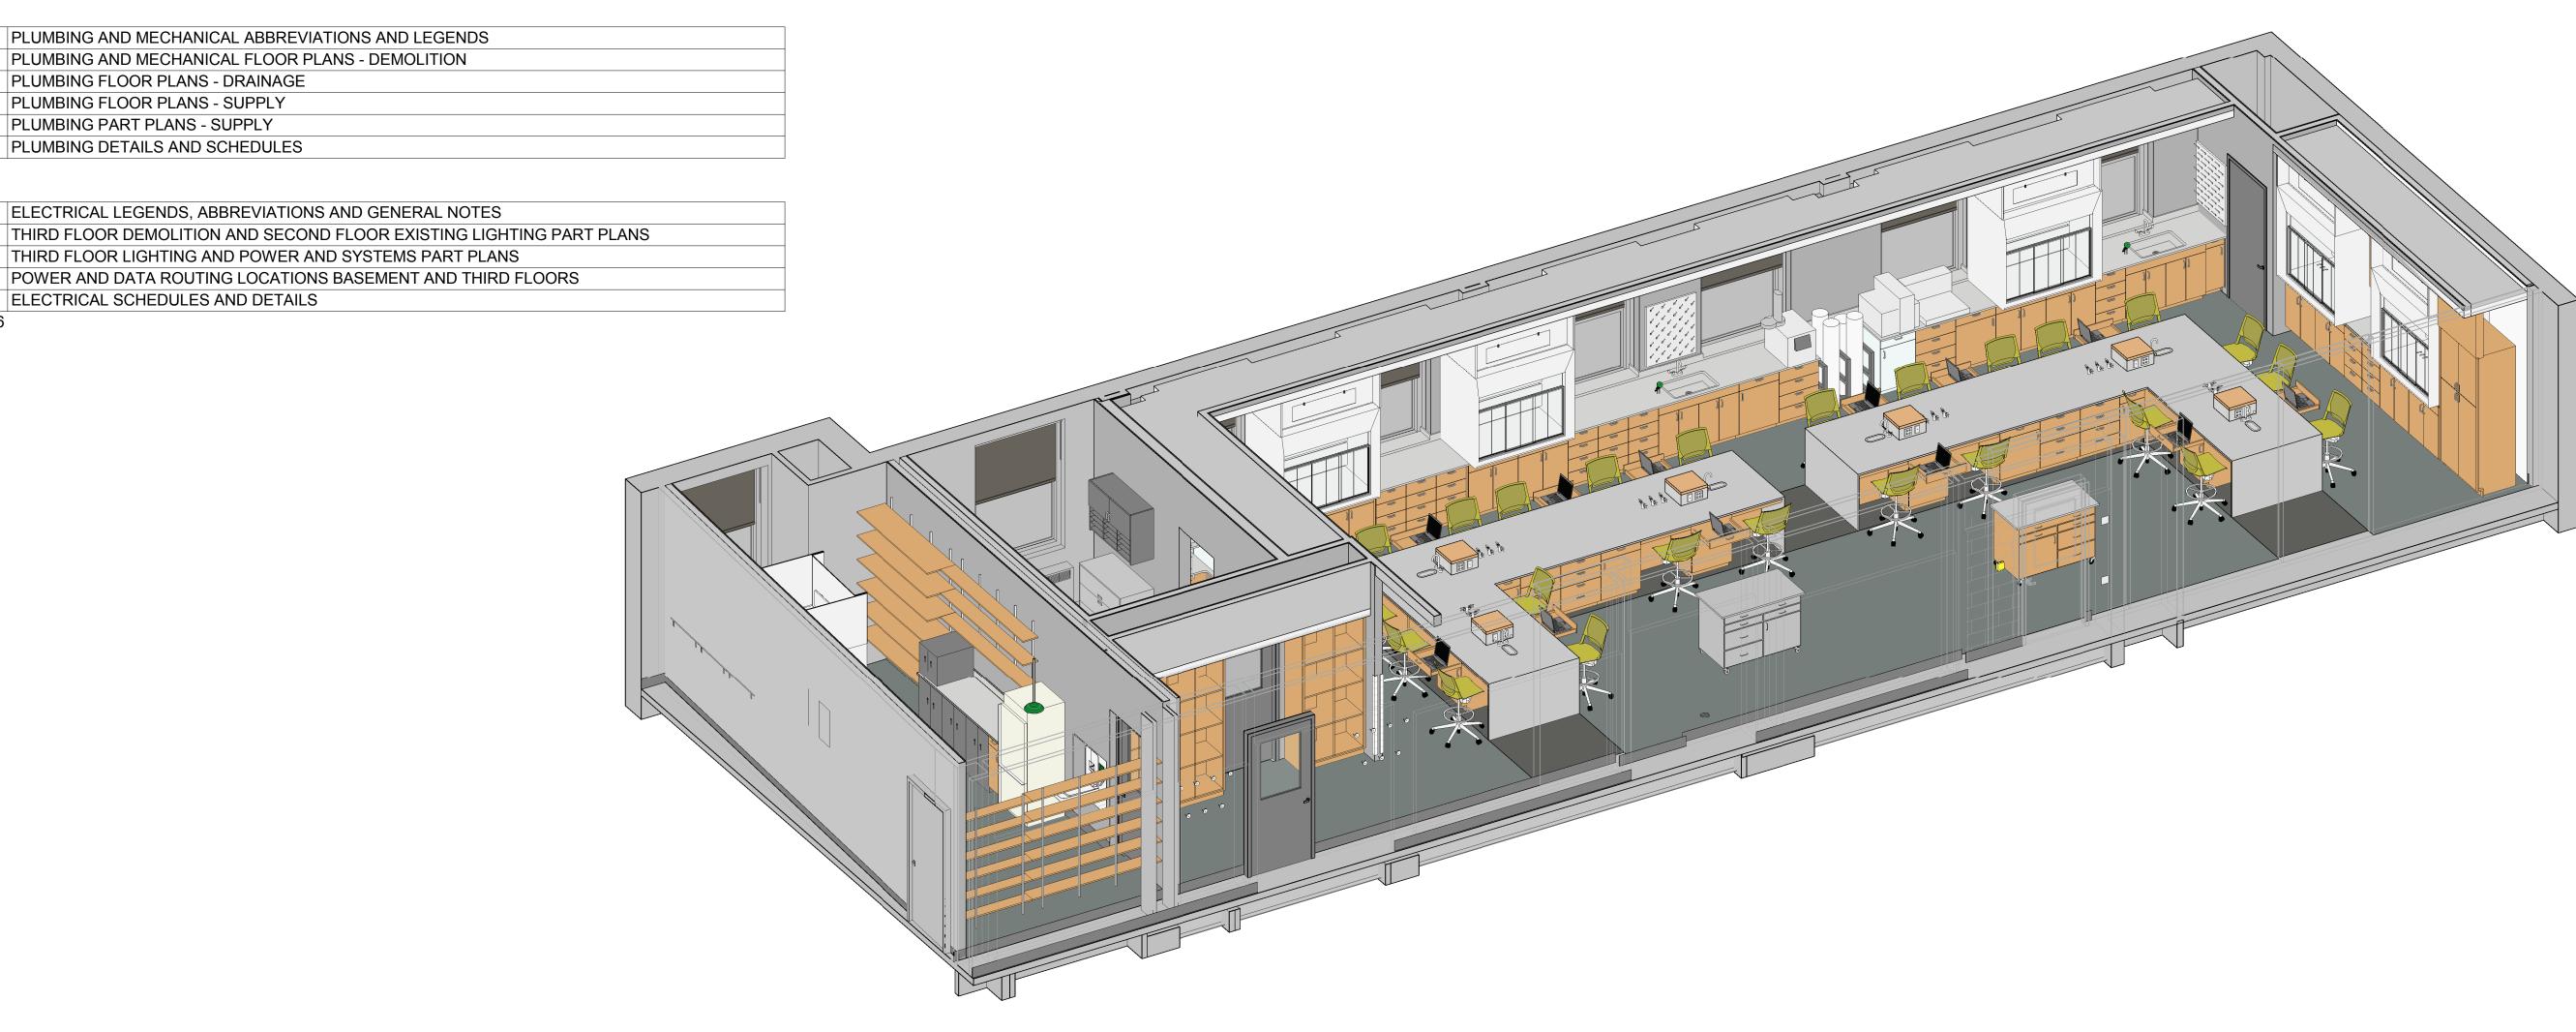

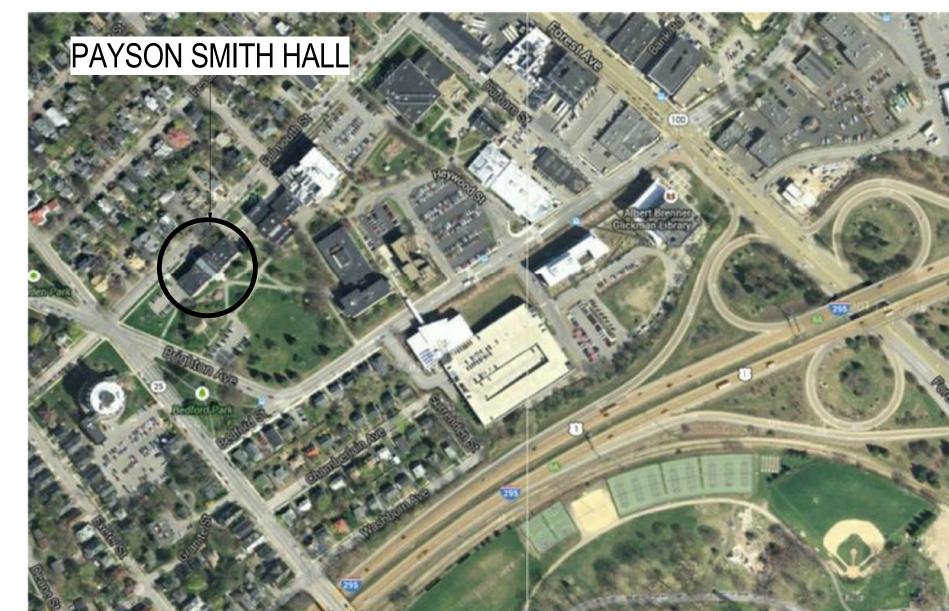

Drawing List

LEGENDS, SYMBOLS, NOTES, PARTITION TYPES. DOOR AND FRAME TYPES & 1-1/2" DETAILS

Sheet Name

COPYRIGHT © 2015 LAVALLEE/BRENSINGER PROFESSIONAL ASSOCIATION. ALL RIGHTS RESERVED. NO REPRODUCTION WITHOUT PRIOR WRITTEN PERMISSION.