
SYSTEM INPUTS

1	MANUAL FIRE ALARM PULL STATION
2	AREA SMOKE DETECTOR
3	FIRE ALARM AC POWER FAILURE
4	FIRE ALARM SYSTEM LOW BATTERY
5	OPEN CIRCUIT
6	GROUND FAULT
7	NOTIFICATION APPLIANCE CIRCUIT SHORT
8	
9	
10	
11	
12	
13	
14	
15	
16	
17	
18	
19	
20	
21	

-

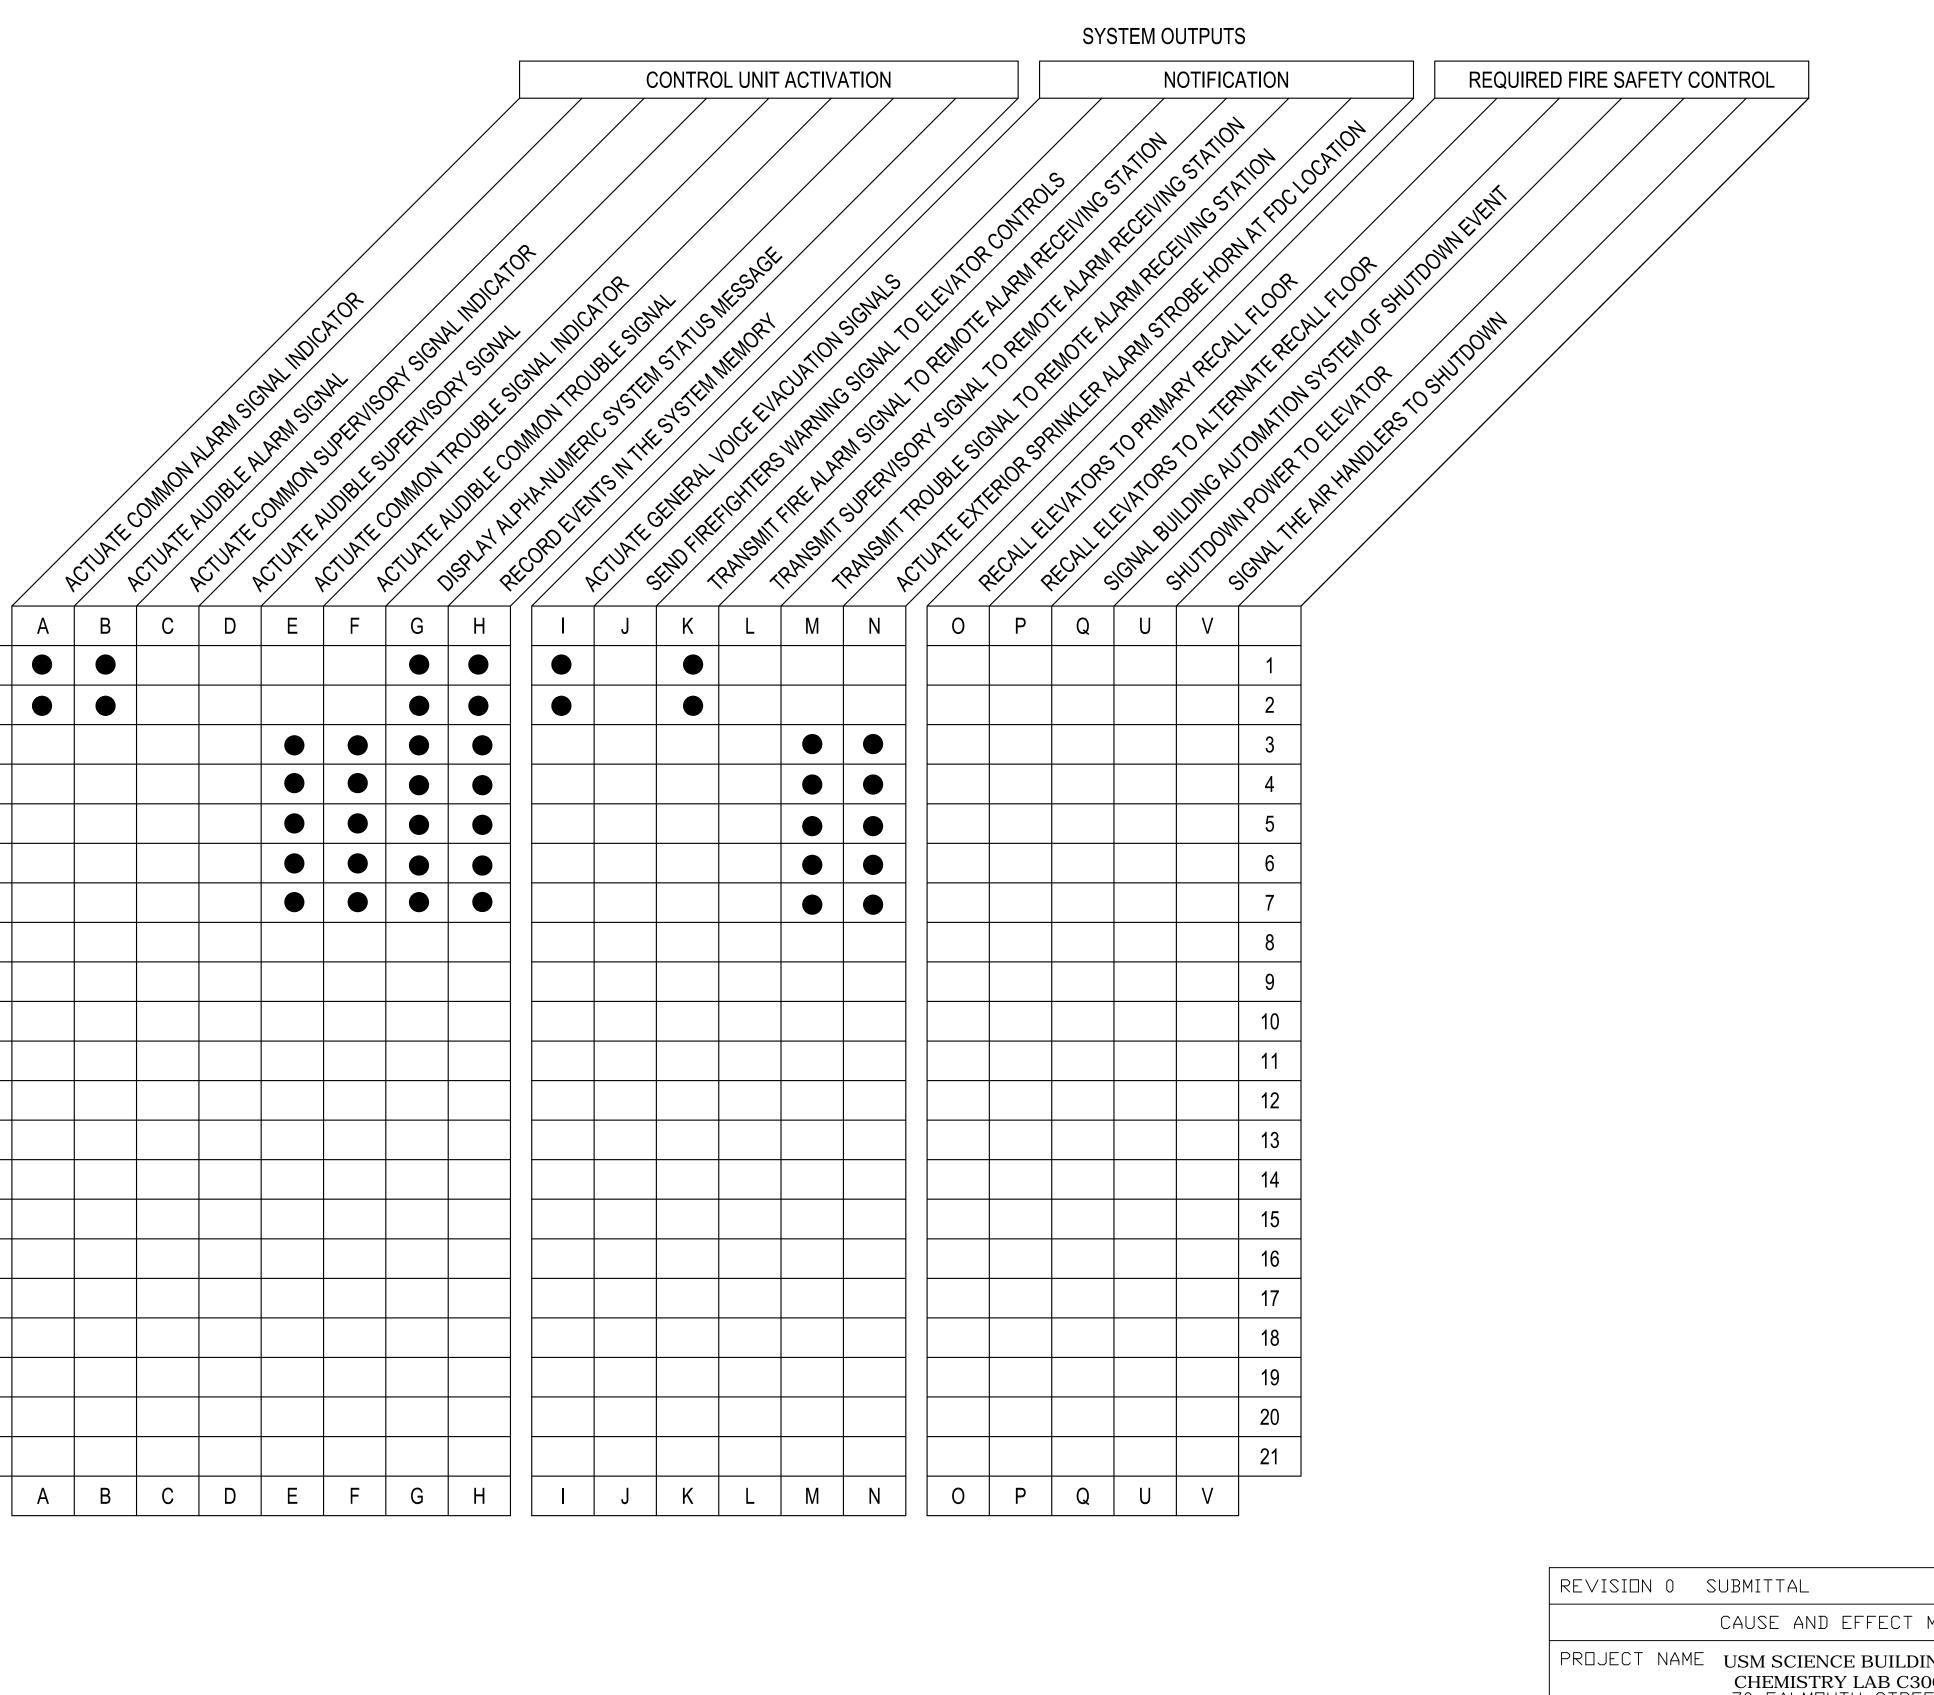

SION O SUBMITTAL	DATE	10/07/2015
CAUSE AND EFFECT MATR	IX	
JECT NAME USM SCIENCE BUILDING		SCALE NTS
CHEMISTRY LAB C300 70 FALMOUTH STREET		BY: JRS
PORTLAND, ME		CK BY:
		DG
	SAVED AS:	
Prepared For Tomorrow; Delivered Today 2257 BROADWAY, SO. PORTLAND, MA	INE	