MOESER & ASSOCIATES 206 AYER ROAD HARVARD, MA 978-456-6905 ARCHITECT

DRAWINGS/SPECIFICATIONS BY: ☐ WALGREENS'

■ LANDLORD'S CONSULTANT


ALL CONSTRUCTION WORK, UNLESS NOTED OTHERWISE, BY:

☐ WALGREENS' CONTRACTOR

OTHERS

LANDLORD'S CONTRACTOR (TURNKEY CONSTRUCTION) STORE BUILDING NEW ■ NEW REMODELING RELOCATION NEW SHELL ONLY . . .

SEE SHEET FP1.2 FOR FIRE ALARM SYSTEM

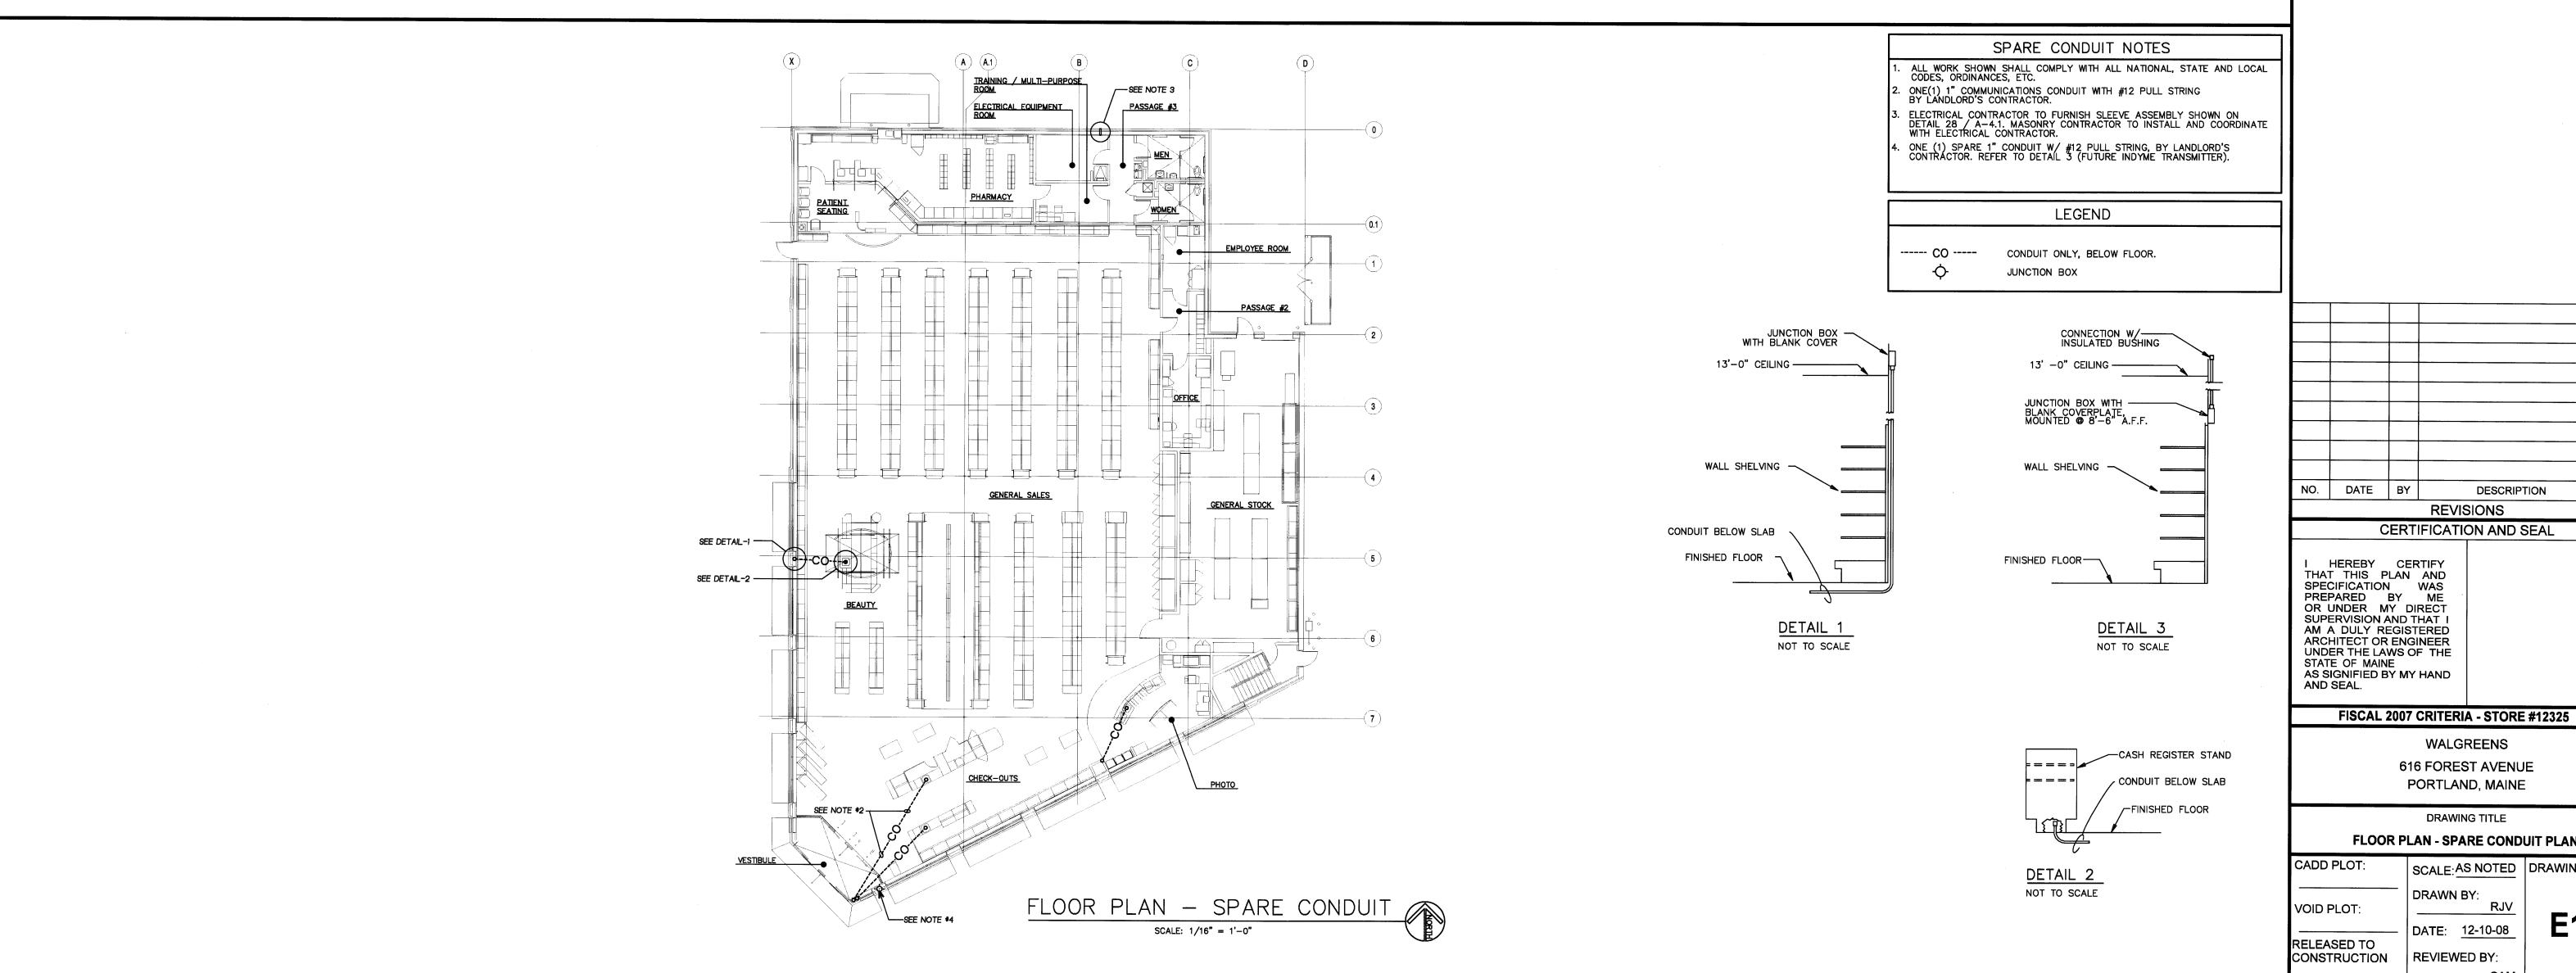

FLOOR PLAN - SPARE CONDUIT PLAN

SCALE: AS NOTED DRAWING NO. RJV DATE: <u>12-10-08</u> CONSTRUCTION REVIEWED BY:

CONST