


69 FALL BOOKS

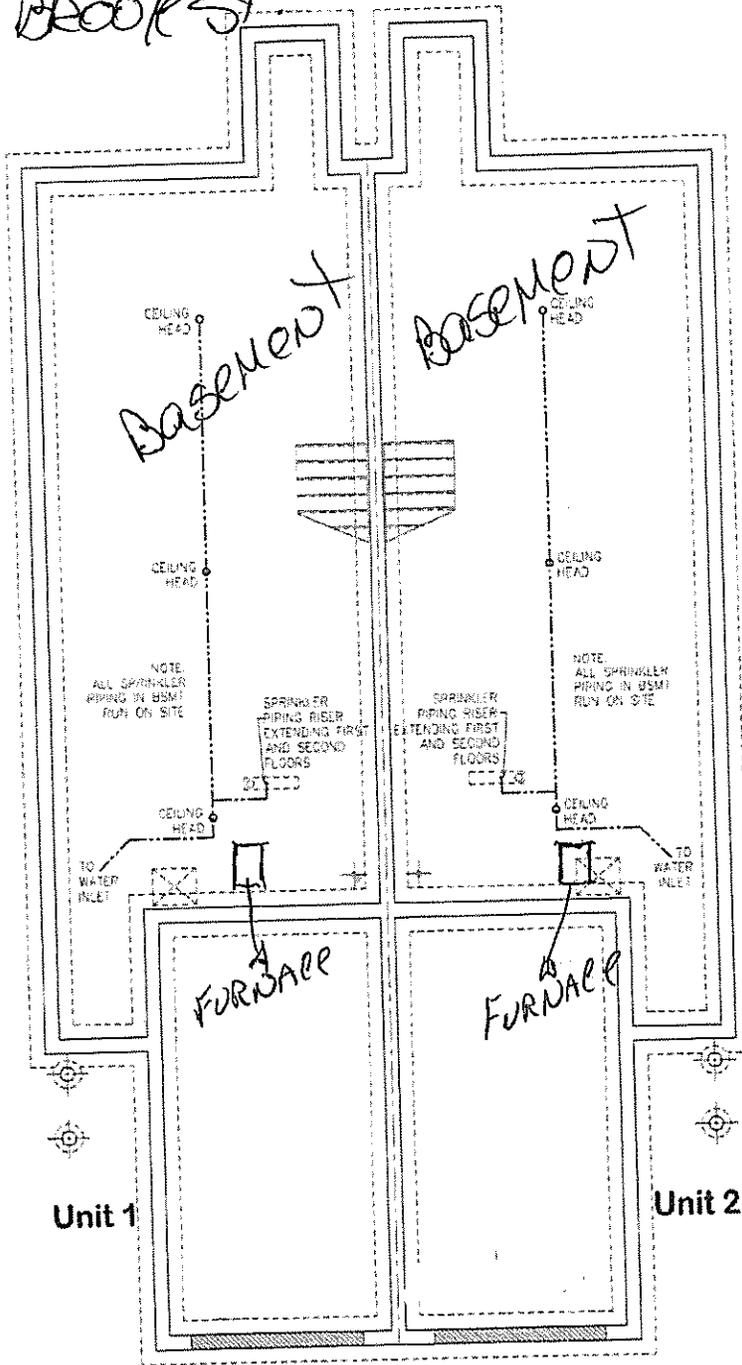

Foundation Sprinkler Plan

ISSUED FOR SIGNATURES CANNOT PROCEED WITHOUT
CUSTOMER APPROVAL
BUILDER APPROVAL

Note: Any drawings, concepts or designs created by Prestige Homes Inc. are the sole property of Prestige Homes Inc. and are subject to copyright protection under the Canadian Intellectual Property Act. Any attempt at utilizing a design, part of a design, or concept without express written permission is strictly prohibited.

Sheet No.	Drawn By: AG	<p>We're built differently.</p>	Prestige Homes Inc. 14 Industrial Drive Sussex, New Brunswick E4E-2B8 Phone: (204)422-9150 Fax: (204)422-9141	Foundation Sprinkler Plan		Revisions List: Oct. 25/16
Original Date	Sept 20/16			12827A	R12859A-14-1C	Revised by AG
Scale	3/16"=1'-0"					