- 1. (1) 2" POWER CONDUIT FOR CHECK-OUT BRANCH CIRCUITS FROM CPI PANEL ASSEMBLY.
- 2. 2" CONDUIT FROM MAIN BACKBOARD TO CHECK OUT COUNTER FOR DATA WIRING.
- 3. 3/4"C. FOR ISO GROUND CIRCUIT.
- 4. 3/4"C. CONDUIT FROM CHECK OUT AREA TO MANAGER'S DESK FOR EXTENSION OF ISO GROUND CIRCUIT.
- 5. RECEPTACLE FOR LOTTERY TERMINAL SHALL BE ORANGE IN COLOR AND ONLY USED FOR LOTTERY USE. RECEPTACLE TO BE MANUFACTURED BY HUBBELL HBL4792.
- 6. JUNCTION BOX FOR FUTURE DIGITAL ORDER TERMINAL. COORDINATE LOCATION IN THE FIELD WITH OWNER.
- 7. DUPLEX RECEPTACLE AND DATA PORT PROVIDED FOR DIGITAL MENU BOARD TO BE MOUNTED IN SOFFIT. THE DISTANCE FROM THE TOP OF THE OUTLET TO THE UPPER SOFFIT SHALL BE 2", DATA CABLES TO RUN TO MANAGER'S DESK.
- 8. ELECTRICAL CONTRACTOR TO FURNISH AND INSTALL 3" CONDUIT WITH PULL STRING IN SLAB, CONDUIT TO DATA D-MARC.
- 9. ELECTRICAL CONTRACTOR TO PROVIDE (4) 1"C SCHEDULE 40 PVC, CONDUIT BELOW SLAB WITH LONG RADIUS SWEEP. LOCATION TO BE DETERMINED IN THE FIELD.
- 10. 3/4"C SCHEDULE 40 PVC CONDUIT WITH PULL STRING IN SLAB FOR "CPI" EMERGENCY SHUT-OFF (PROVIDED BY CPI, WIRED BY ELECTRICAL CONTRACTOR).
- 11. REFER TO THE ARCHITECTURAL DRAWINGS FOR EXACT MOUNTING HEIGHT FOR THE MICROWAVE RECEPTACLE.
- 12. TEMPERATURE SENSOR TO BE PROVIDED FOR WALK-IN COOLER/FREEZER AND SANDWICH COOLER (PROVIDED BY CP, WIRED BY ELECTRICAL CONTRACTOR).
- 13. DISCONNECT SWITCHES FOR ALL UC UNITS IN WALK-IN'S ARE SUPPLIED BY THE MECHANICAL CONTRACTOR, ELECTRICAL CONTRACTOR TO INSTALL AND WIRE DISCONNECT SWITCHES.
- 14. FINAL LOCATION FOR GAS PUMP MONITORS AND SECURITY MONITOR TO BE DETERMINED IN THE FILED WITH LOCAL AHJ AND STORE OWNER. QUANTITY OF MONITORS IS DETERMINED BY THE QUANTITY OF GAS PUMPS, (4) PUMPS PER MONITOR. (1) SECURITY MONITOR.
- 15. ELECTRICAL CONTRACTOR TO FIELD COORDINATE MOUNTING HEIGHT FOR ELECTRIC WATER HEATERS WITH ARCHITECTURAL

		CABLE	& CONDUIT SCHEDULE	
CONDUIT	SIZE	WIRE	PURPOSE	REMARKS
a	3/4"C	#18/3 TWISTED SHIELDED	TEMPERATURE SENSOR DEFROST COIL IN COOLER/FREEZER	
b	3/4"C	#18/3 TWISTED SHIELDED	DOOR SWITCH	
С	3/4"C	#18/3 TWISTED SHIELDED	REFRIGERATION CIRCUIT TEMP. SENSOR	


<u>LEGEND</u>

S COIL TEMPERATURE SENSOR

T SPACE TEMPERATURE SENSOR DS DOOR SWITCH

REFER TO REFRIGERATION EQUIPMENT MANUFACTURER'S SPECIFICATIONS FOR TERMINATION LOCATIONS OF TEMPERATURE SENSORS

ALL 15 AND 20A KITCHEN CIRCUITS SHALL BE PROTECTED WITH GFI CIRCUIT BREAKERS. A KITCHEN AREA SHALL BE ANY AREA WITH A SINK AND PROVISIONS FOR COOKING.

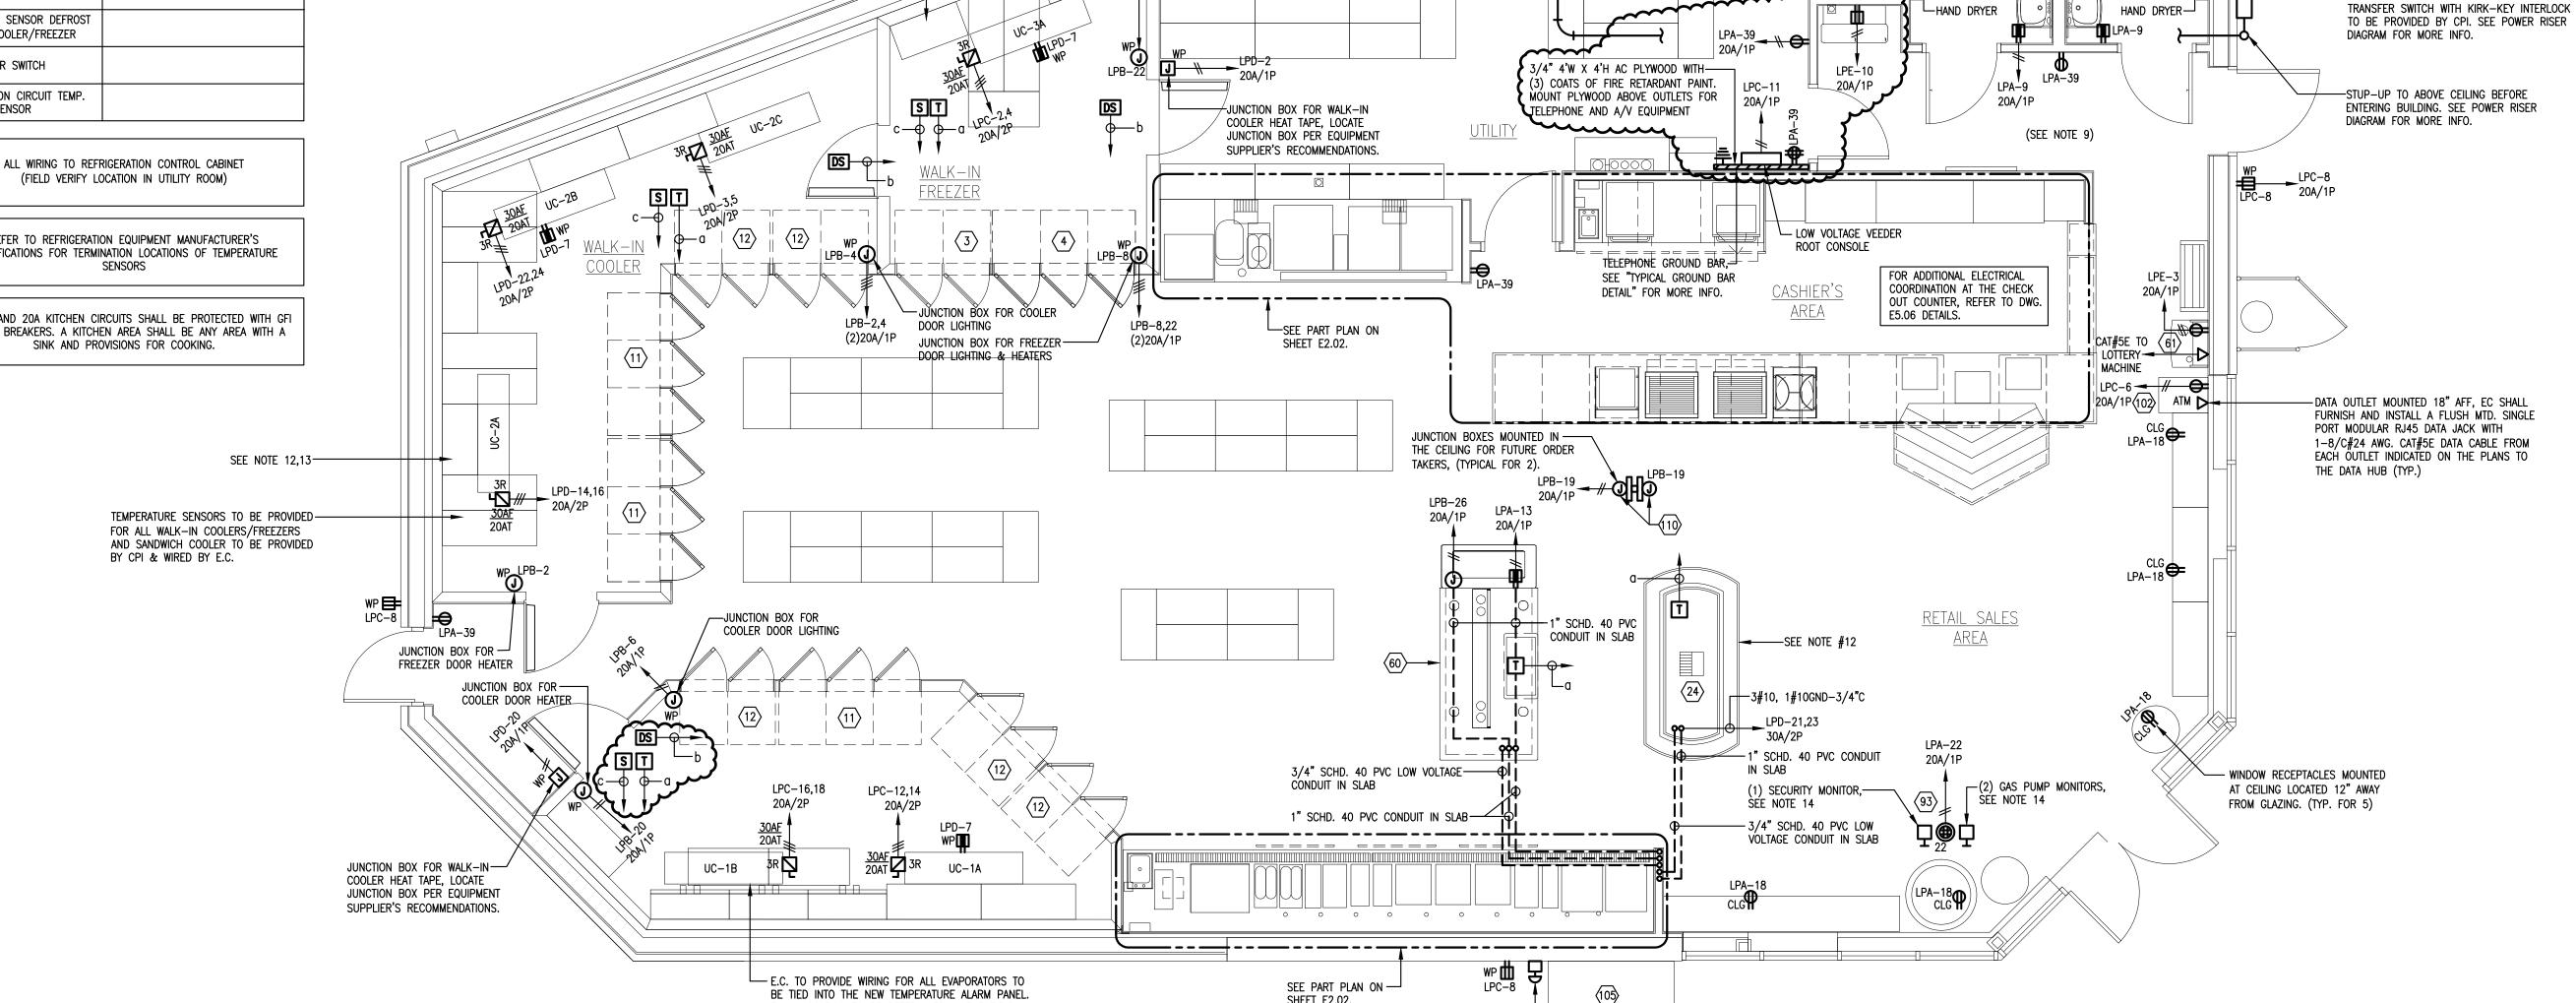

FE PETRO PUMP CONTROLLERS, LOCATED

PANEL FEEDERS & CONDUIT ABOVE -

¢ÉILING, REÆ∰ TO ONE-LINE POWER

RISER DIAGRAM ON SHEET E5.01.

ABOVE CPI CABINET. COORDINATE W/

G.C. FOR FINAL LOCATION

JUNCTION BOX FOR —

FREEZER DOOR HEATER

SEE NOTE 12,13-

FINAL LOCATION TO BE DETERMINED IN THE FIELD

TEMPERATURE SENSORS TO BE PROVIDE FOR ALL —

COOLER TO BE PROVIDED BY CPI & WIRED BY E.C.

WALK-IN COOLERS/FREEZERS AND SANDWICH

ELECTRICAL - POWER & SIGNAL PLAN SCALE: 1/4"=1'-0"

GASOLINE PUMP EMERGENCY SHUT-OFF SWITCH

(PROVIDED BY OTHERS, WIRED BY E.C.)

SEE PART PLAN ON — SHEET E2.02.

Cumberland Farms Store # 5613 512 Woodford Street

Portland, ME



100 Crossing Blvd Framingham, Ma tel 508 270 1400

AIR MACHINE TO REMAIN. TIE INTO NEW "LP1" SWITCHGEAR. VERIFY RATINGS AND

COORDINATE WITH UTILITY COMPANY EXACT SERVICE

REQUIREMENTS PRIOR TO START CONSTRUCTION

C/T CABINET

ENTRANCE EQUIPMENT & INCOMING SERVICE SEQUENCE

— RATED NEMA 3R METER CABINET

-MAIN SERVICE ENTRANCE RATED NEMA 3R

-NEW 208Y/120V 600A 3Ø NEMA 3R MAIN

SERVICE ENTRANCE RATED FUSED DISCONNECT.

NON-AUTOMATIC SERVICE ENTRANCE RATED

WIRING IN THE FIELD.

-CPI PANELBOARD ASSEMBLY

-SEE PART PLAN ON

SHEET E2.02

(BY OTHERS)

---PLYWOOD BACKER

- MACVICTOR UPS

- ICE MACHINE TO REMAIN. TIE INTO NEW

"LP1" SWITCHGEAR. VERIFY RATINGS AND

WIRING IN THE FIELD.

<u> LPA LPC LPD LPB LPE∳LPG</u>



DUXBURY, MASSACHUSETTS 02332 PHONE: (781) 452-7121 FAX: (860) 264-1628 WEBSITE: www.phasezerodesign.com



Consultant



 No.
 Date
 Issued for

 11/22/13
 90% Review Set

01/24/14 Bid and Permit

Revisions

	04/03/14	ADDENDUM 01			
Key Plan					
	" - -				

ELECTRICAL: POWER PLANS, SCHEDULES, LEGENDS & NOTES

Drawing No.

Cumberland Farms Project No.

2113119