
((XD.7)							
(XF							
(
(ХК							
(XL							
(XM)							
(XM.5							
	REFL	ECTED	CEILING	PLAN -	LEVEL 2	- ZONE	7	

<u>SCALE: 1/8" = 1'-0"</u>

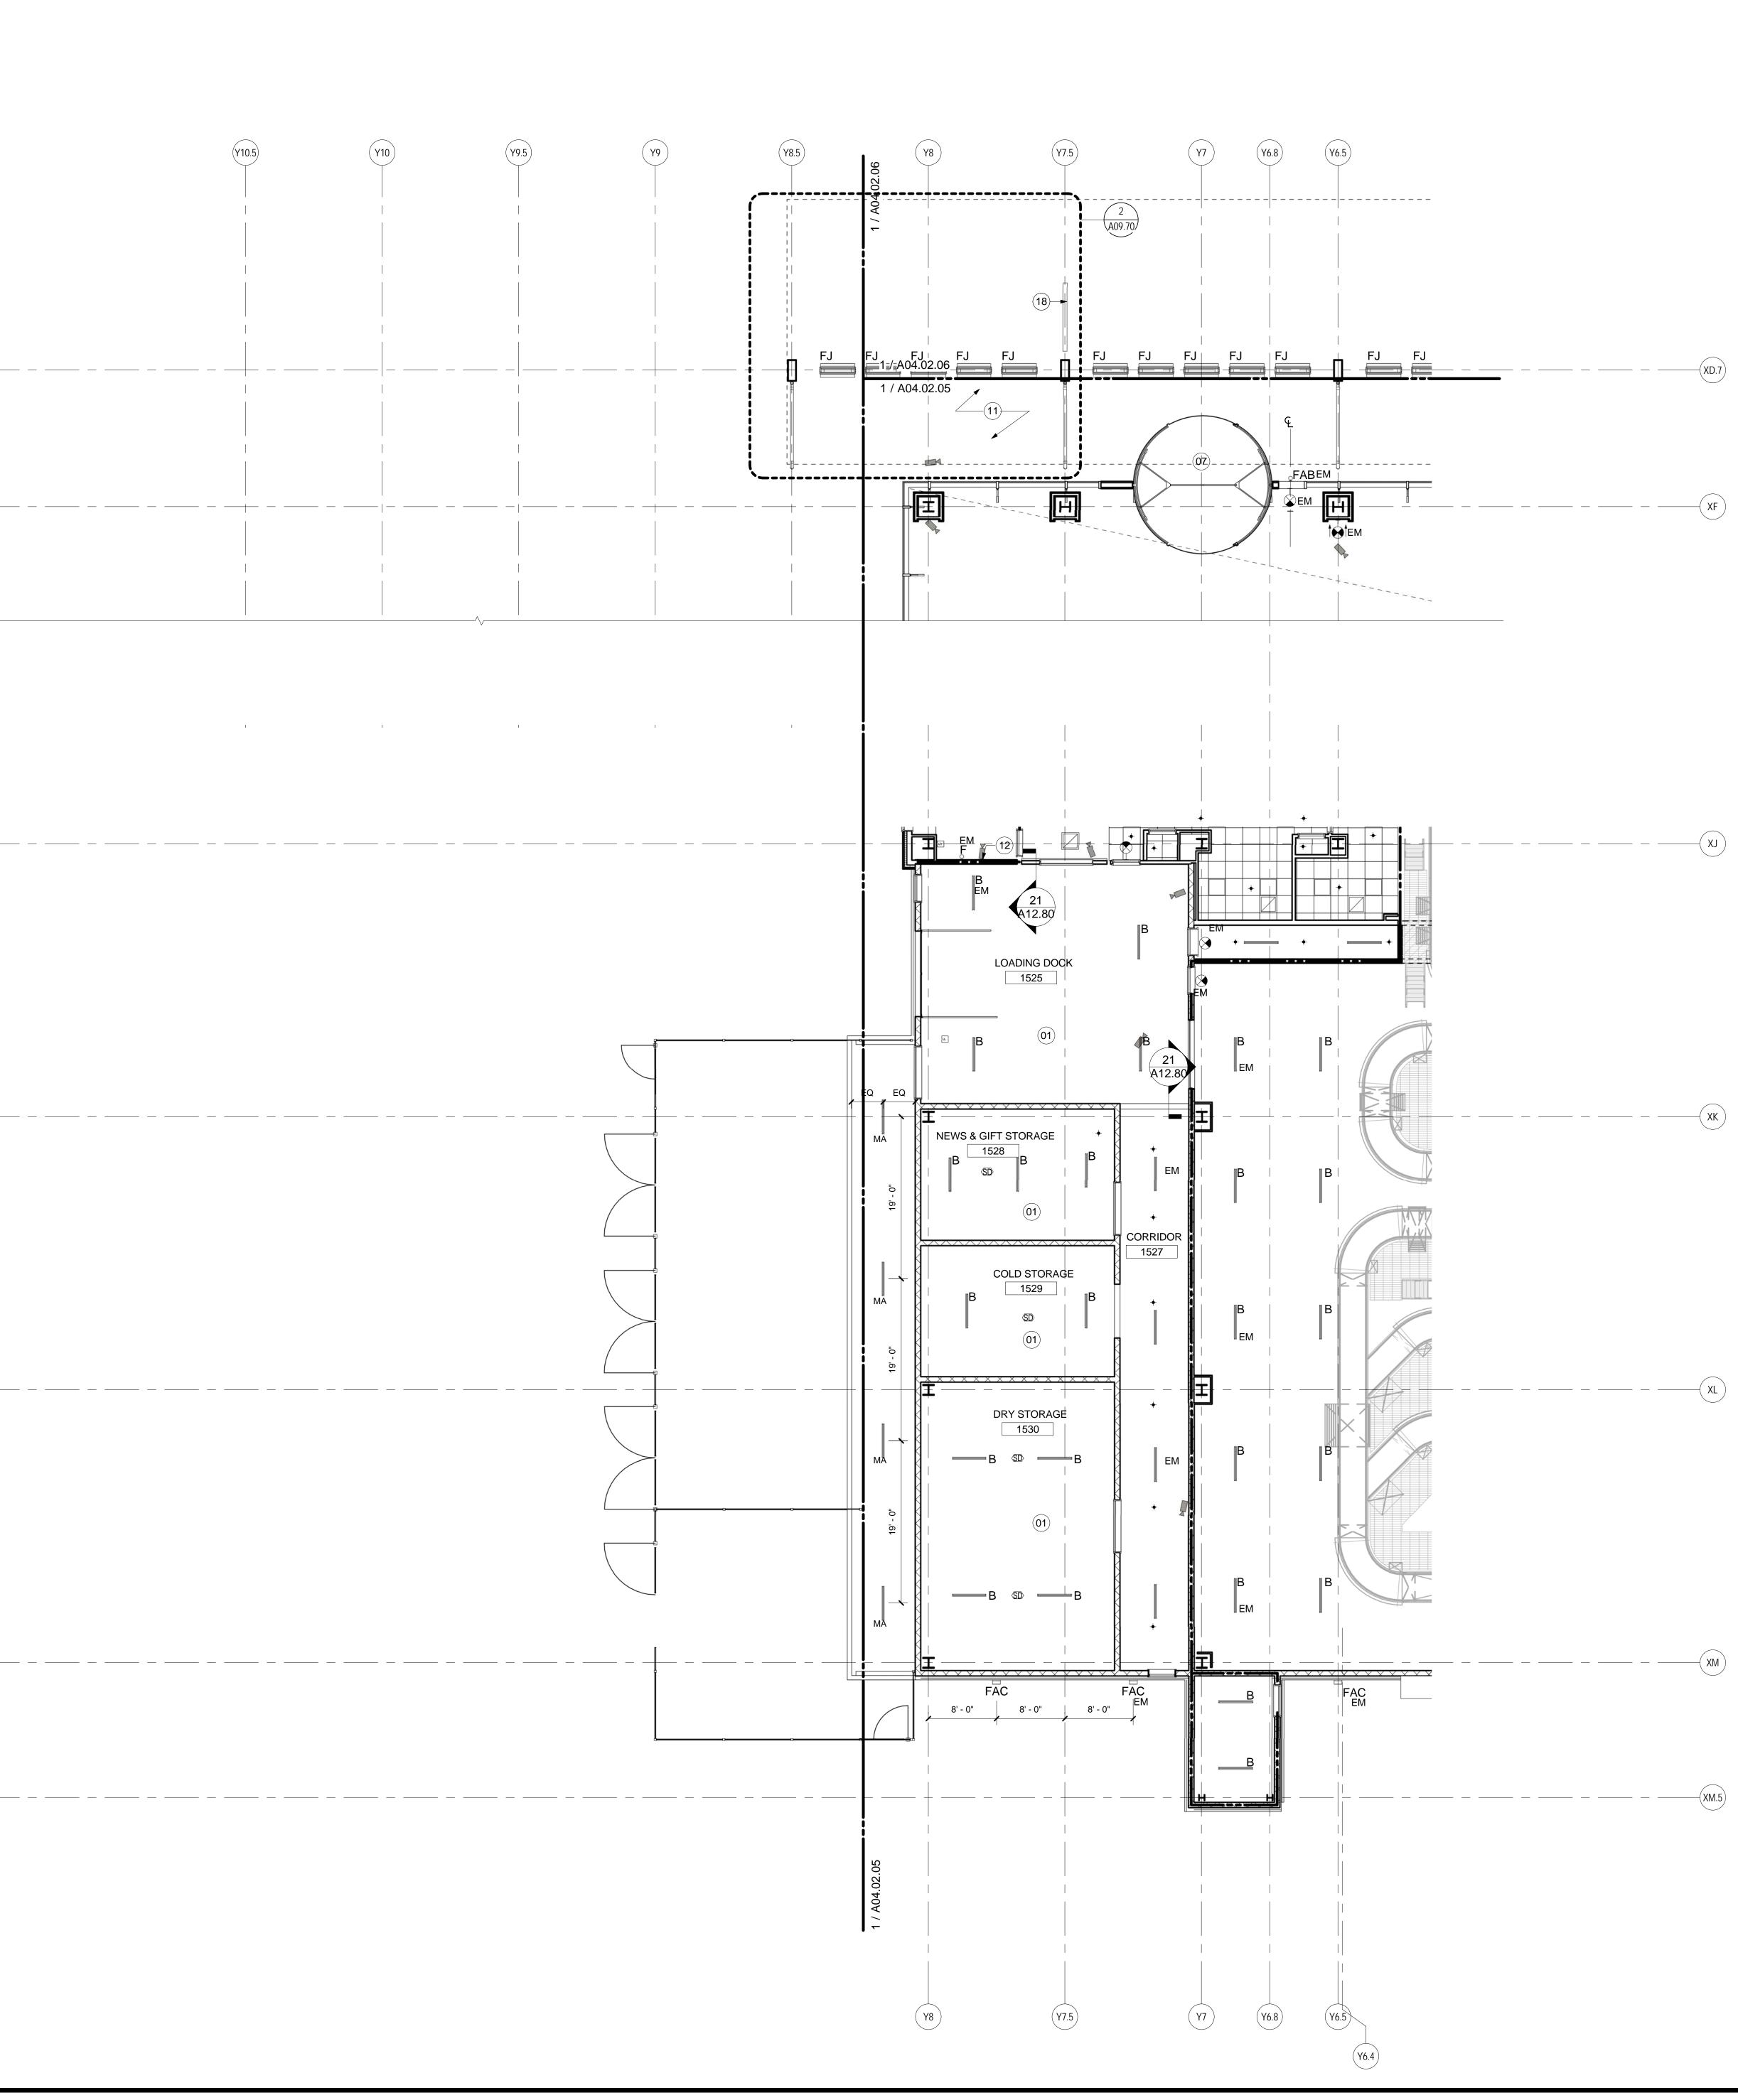

A01.DS1

SHEET NOTES

01 NO CEILING

02 CEILING BY TENANT 03 EXISTING CEILING AND LIGHT FIXTURES TO REMAIN. RELOCATE SALVAGED LIGHT FIXTURES TO AREAS OF DEMOLITION AS REQUIRED. PATCH AND REPAIR AS REQUIRED AT AREAS OF DEMOLITION. 04 LIGHTING BY TENANT

Portland International

2020 K Street, Northwest

Washington DC 20006

Suite 200

Gensler Telephone 202.721.5200 Facsimile 202.872.8587

Jetport

1001 Westbrook Street

Portland, Maine 04102

- 05 ESCALATORS TO HAVE INTEGRAL LIGHTING STRIPS ON SIDE PANELS. PROVIDED BY ESCALATOR MANUFACTURER.
- 06 UNDERSIDE OF ESCALATOR TO BE METAL PANEL CLAD, M-02 07 REVOLVING DOOR LIGHTING BY DOOR
- MANUFACTURER. RE: PROJECT MANUAL 08 2-HR RATED GYPSUM BOARD CEILING 09 ALL EXISTING TO REMAIN. ROOM TO BE
- USED BY OWNER FOR BHS STORAGE AND MAINTENANCE 10 FOR CEILING IN THIS AREA REFER TO A04.01
- SERIES 11 CANOPY ABOVE 12 PROVIDE LIGHT FIXTURE AT EVERY STAIR
- LANDING U.O.N. REFER TO ELECTRICAL DRAWINGS FOR MORE INFORMATION. 13 EXPANSION JOINT. RE: A02 SERIES FOR
- SCHEDULE 14 CONTROL JOINT. REFER TO 06/A12.80
- 15 ACCESS PANEL FOR FIRE SHUTTER. COORDINATE EXACT LOCATION OF PANEL WITH ARCHITECT. 16 FIRE SHUTTER
- 17 CENTERLINE FIXTURE TO ALIGN WITH CENTERLINE OF MULLION ABOVE. TYP. REFER TO PROJECT MANUAL FOR
- ADDITIONAL INFORMATION 18 SIGNAGE AND WAYFINDING: REFER TO A07 SERIES DRAWING FOR ADDITIONAL INFORMATION
- 19 12"X12" ACCESS PANEL ON ANGELED CEILING RE:FIRE PROTECTION DRAWINGS FOR MORE INFORMAITON
- 20 EXISTING PRECAST ENCLOSED BEAM. PATCH AND REPAIR AS REQUIRED. PAINTED TO MATCH EXISTING
- 21 CEILING HEIGHT IS INDICATED FROM EXISTING TERMINAL 22 UPPER LEVEL LIGHTS AND EXIT SIGNS
- MOUNTING HEIGHTS TO BE COORDINATED WITH BAGGAGE EQUIPMENT 23 LIGHT FIXTURE AT ESCALATOR PIT MOUNTED PER MANUFACTURERS
- RECOMMENDATIONS 24 CONDUIT FOR CAMERA SHALL BE CONCEALED; FLEX TO RIGID TRANSITION SHALL BE RECESSED WITHIN PRECAST COLUMN COVERS AND/OR PARTITIONS. WEATHERPROOF ALL PENETRATIONS AS REQUIRED.

Date

Description

10/26/09 ISSUED FOR PERMIT


 2
 11/12/09
 ADDENDUM #2

 145
 09/01/11
 ISSUED FOR CONSTRUCTION

12/03/08 75% CONSTRUCTION DOCUMENTS

01/23/09 95% CONSTRUCTION DOCUMENTS

Seal/Signature

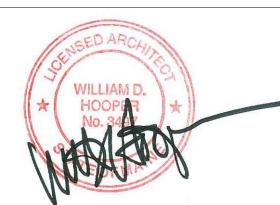

Project Name PWM Terminal Enhancement

Project Number 09.6395.000

Description

Scale

© 2009 Gensler

REFLECTED CEILING PLAN - LEVEL 2 - ZONE 7





GENERAL NOTES

- A FOR LIGHTING TYPES, DETAILS AND INFORMATION
- REFER TO PROJECT MANUAL. B FOR DIFFUSER INFORMATION AND QUANTITY, REFER TO PROJECT MANUAL. C ALL GWB CEILINGS TO BE PAINTED P-01 U.O.N.
- D SPRINKLER HEADS ARE SHOWN FOR DESIGN INTENT ONLY. REFER TO FIRE PROTECTION
- DRAWINGS FOR ADDITIONAL INFORMATION. E FOR CAMERA LOCATION AND MOUNTING DETAILS
- **RE: I.T. AND COMMUNICATION ENGINEERS** DRAWINGS. F DEVICES AND FIXTURES IN BAGGAGE HANDLING
- ROOMS TO BE COORDINATED WITH BHS EQUIPMENT FOR MOUNTING AND VISIBILITY G ACT CEILINGS TO BE CENTERED IN EACH ROOM

KEY PLAN

U.O.N.

