
NOTES:

- 1. SEE THIS SHEET FOR LEGEND, ABBREVIATIONS AND GENERAL NOTES.
- 2. LIGHTING IN THIS AREA SHALL BE FED FROM EXISTING LIGHTING CIRCUITS. PROVIDE ALL ADDITIONAL WIRE AND CONDUITS AS REQUIRED FOR CONNECTION OF NEW LIGHTING FIXTURES AND PROVISION OF SWITCHING LEGS AS SHOWN ON THE LIGHTING PLAN.

KEYED NOTES:


- CONNECT NEW FIRE ALARM DEVICE TO EXISTING FIRE ALARM SYSTEM.
- 2 LIFE SAFETY LIGHTS IN CENTER OF ROOM TO BE CONNECTED TO LOCAL LIFE SAFETY LIGHTING CIRCUIT. FURNISH UL924 RELAY TO TURN LIGHT FIXTURES ON REGARDLESS OF SWITCH POSITION UPON OPERATION OF EMERGENCY GENERATOR. SEE WIRING DIAGRAM THIS SHEFT

<u>LIGHTING SCHEDULE</u>							
TYPE	DESCRIPTION	MANFACTURER	LAMPS	MOUNTING	NOTES		
А	2' X 2' HIGH PERFORMANCE LED TROFFER WITH DIMMING DRIVER 277V	FINELITE	37W LED 4000K 3460 LUMENS	CEILING GRID RECESSED	MODEL #: HPR-A-22-DCO-LEDSO-4000K-120		
В	4" LED DOWNLIGHT — CLEAR ALZAK REFLECTOR & WHITE TRIM 277V	PRESCOLITE	16W LED 4000K 1100 LUMENS	CEILING RECESSED	MODEL #: HOUSING: LF4LED TRIM: 4LFLED5-40K-WT		
С	ARCHITECTURAL WALL SCONCE BRUSHED NICKEL FINISH 277V	SCOTT ARCHITECTURAL LIGHTING	(1)-27W BIAX-CF	WALL SURFACE	MODEL #: S3895-1CF27		

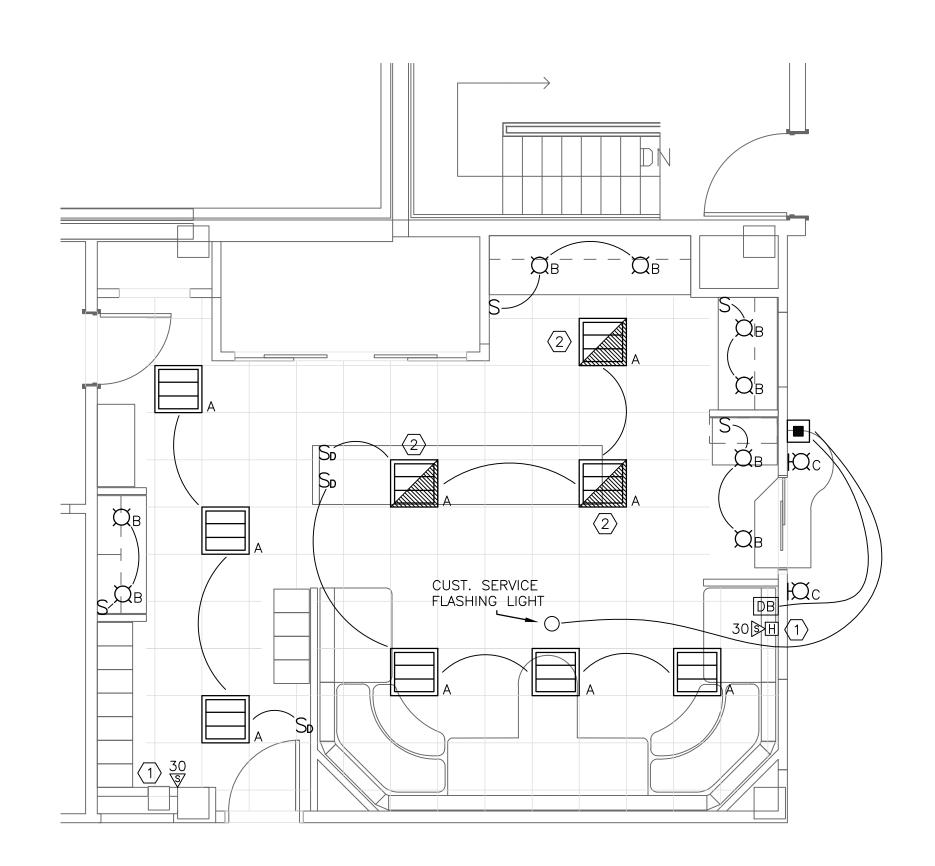



SCALE: 1/4" = 1'-0"

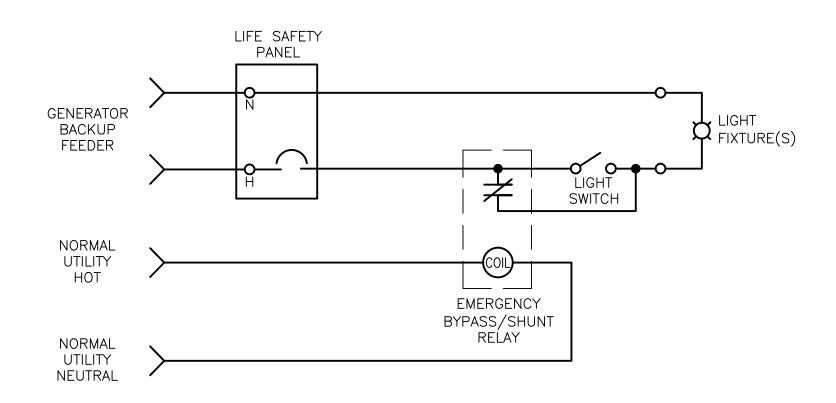

DETAIL NOTE:

1.) LIFE SAFETY SWITCHED CIRCUITS. SHALL BE FURNISHED WITH AN EMERGENCY BYPASS/SHUNT RELAY SUCH AS RIB UL924/20A/ESRO2P, SO THAT UPON LOSS OF NORMAL POWER THE FIXTURES ARE SWITCHED ON.

2 LIFE SAFETY CONTROL WIRING DIAGRAM
SCALE: NOT TO SCALE

ISSUED FOR CONSTRUCTION 03/15/2013

General Notes

Revision/Issue	Date




Project Name and Address

COMMUNICATIONS
CENTER
RENOVATIONS

Sheet Title

ELECTRICAL LIGHTING AND FIRE ALARM PLAN

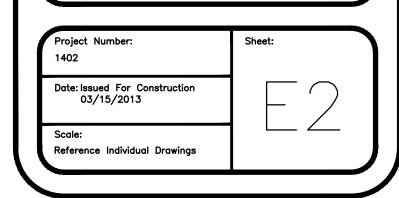

	No. 9199					
/ \SWIFTCURRENT						
	Engineering Services					
	10 Forest Falls Dr. Unit 4B Yarmouth, ME 04096 Tel: (207) 847—9280					