

COMMUNICATIONS CENTER RENOVATIONS AT THE

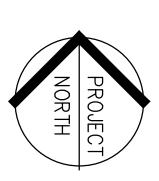

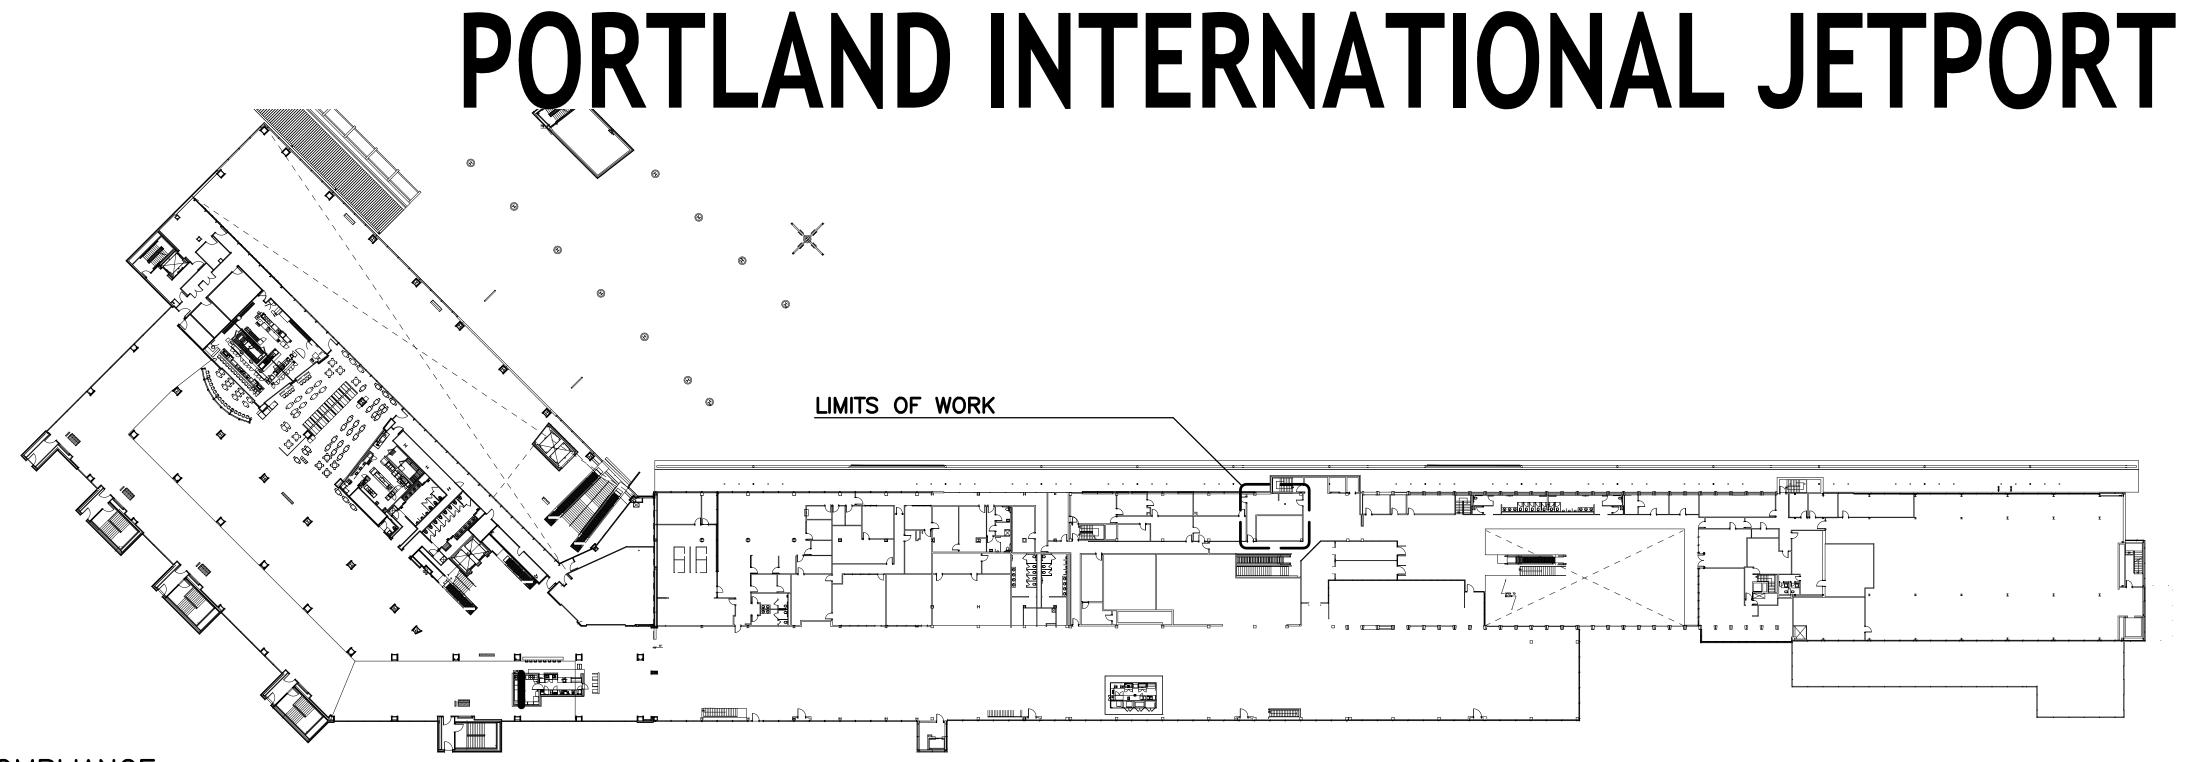

CODE COMPLIANCE

1.0 PRINCIPLE CODES, STANDARDS, AND REVIEW AUTHORITIES APPLICABLE TO PROJECT

NFPA INCLUDING 101 LIFE SAFETY CODE, 2009 EDITION STATE FIRE MARSHAL'S OFFICE, RICHARD McCARTHY PHONE: (207)624-8744 FAX: (207)626-3886

PORTLAND FIRE DEPARTMENT, FIRE CHIEF, Captain Chris Pirone

PHONE: (207)874-8405 FAX: (207)874-8400

IBC BUILDING CODE, 2009 EDITION PORTLAND CODE ENFORCEMENT OFFICER, Tammy Munson PHONE: (207)874-8706

ADA, ACCESSIBILITY GUIDELINES FOR BUILDINGS AND FACILITIES.

MAINE HUMAN RIGHTS ACT, ANSI A117.1 - 1986 STATE FIRE MARSHAL'S OFFICE, RICH McCARTHY PHONE: (207)624-8744 FAX: (207) 626-3886

ASHRAE 62.1 2007

PLUMBING:

AUTOMATIC SPRINKLER SYSTEM:

ENERGY:

ELECTRICAL:

SITE LOCATION MAP: SECOND FLOOR OF TERMINAL BUILDING

SCALE: NTS

DRAWING LIST

T-1 TITLE SHEET

GENERAL INFORMATION

DEMOLITION PLAN

FLOOR PLAN, REFLECTED CEILING PLAN, LAYOUT PLAN DETAILS

INTERIOR ELEVATIONS, DETAILS

ROOM FINISH SCHEDULE; DOOR SCHEDULE, WALL TYPES, DETAILS

MECHANICAL SYSTEMS PLANS & DETAILS

ELECTRICAL LEGEND AND GENERAL NOTES

ELECTRICAL POWER & SYSTEMS PLAN

ELECTRICAL LIGHTING AND FIRE ALARM PLAN

	General Notes	
	ISSUED FOR CONSTRUCTION 3/15/2014	
No.	Revision/Issue	Date



COMMUNICATIONS CENTER RENOVATIONS AT THE PORTLAND INTERNATIONAL **JETPORT**

TITLE SHEET

Project Number: 1402	Sheet:
Date: Issued For Construction 3/15/2014	1 T - 1
Scale: Reference Individual Drawings	