
(XD.7) — — — — —		 
-		
(XF) — — — —		 
$\frown$		
$\frown$		
(XK) — — — — —		 
$\frown$		
XL — — — — —		 
(XM) — — — — —		 
(XM.5) — — — — —		 
	CEILING PLAN - LEVE	

SCALE: 1/8" = 1'-0"

Y10.5	Y9.5	Y9                   	Y8.5       90         FK       6         FK       6         1       1         1       1
			1 / A04.03.05

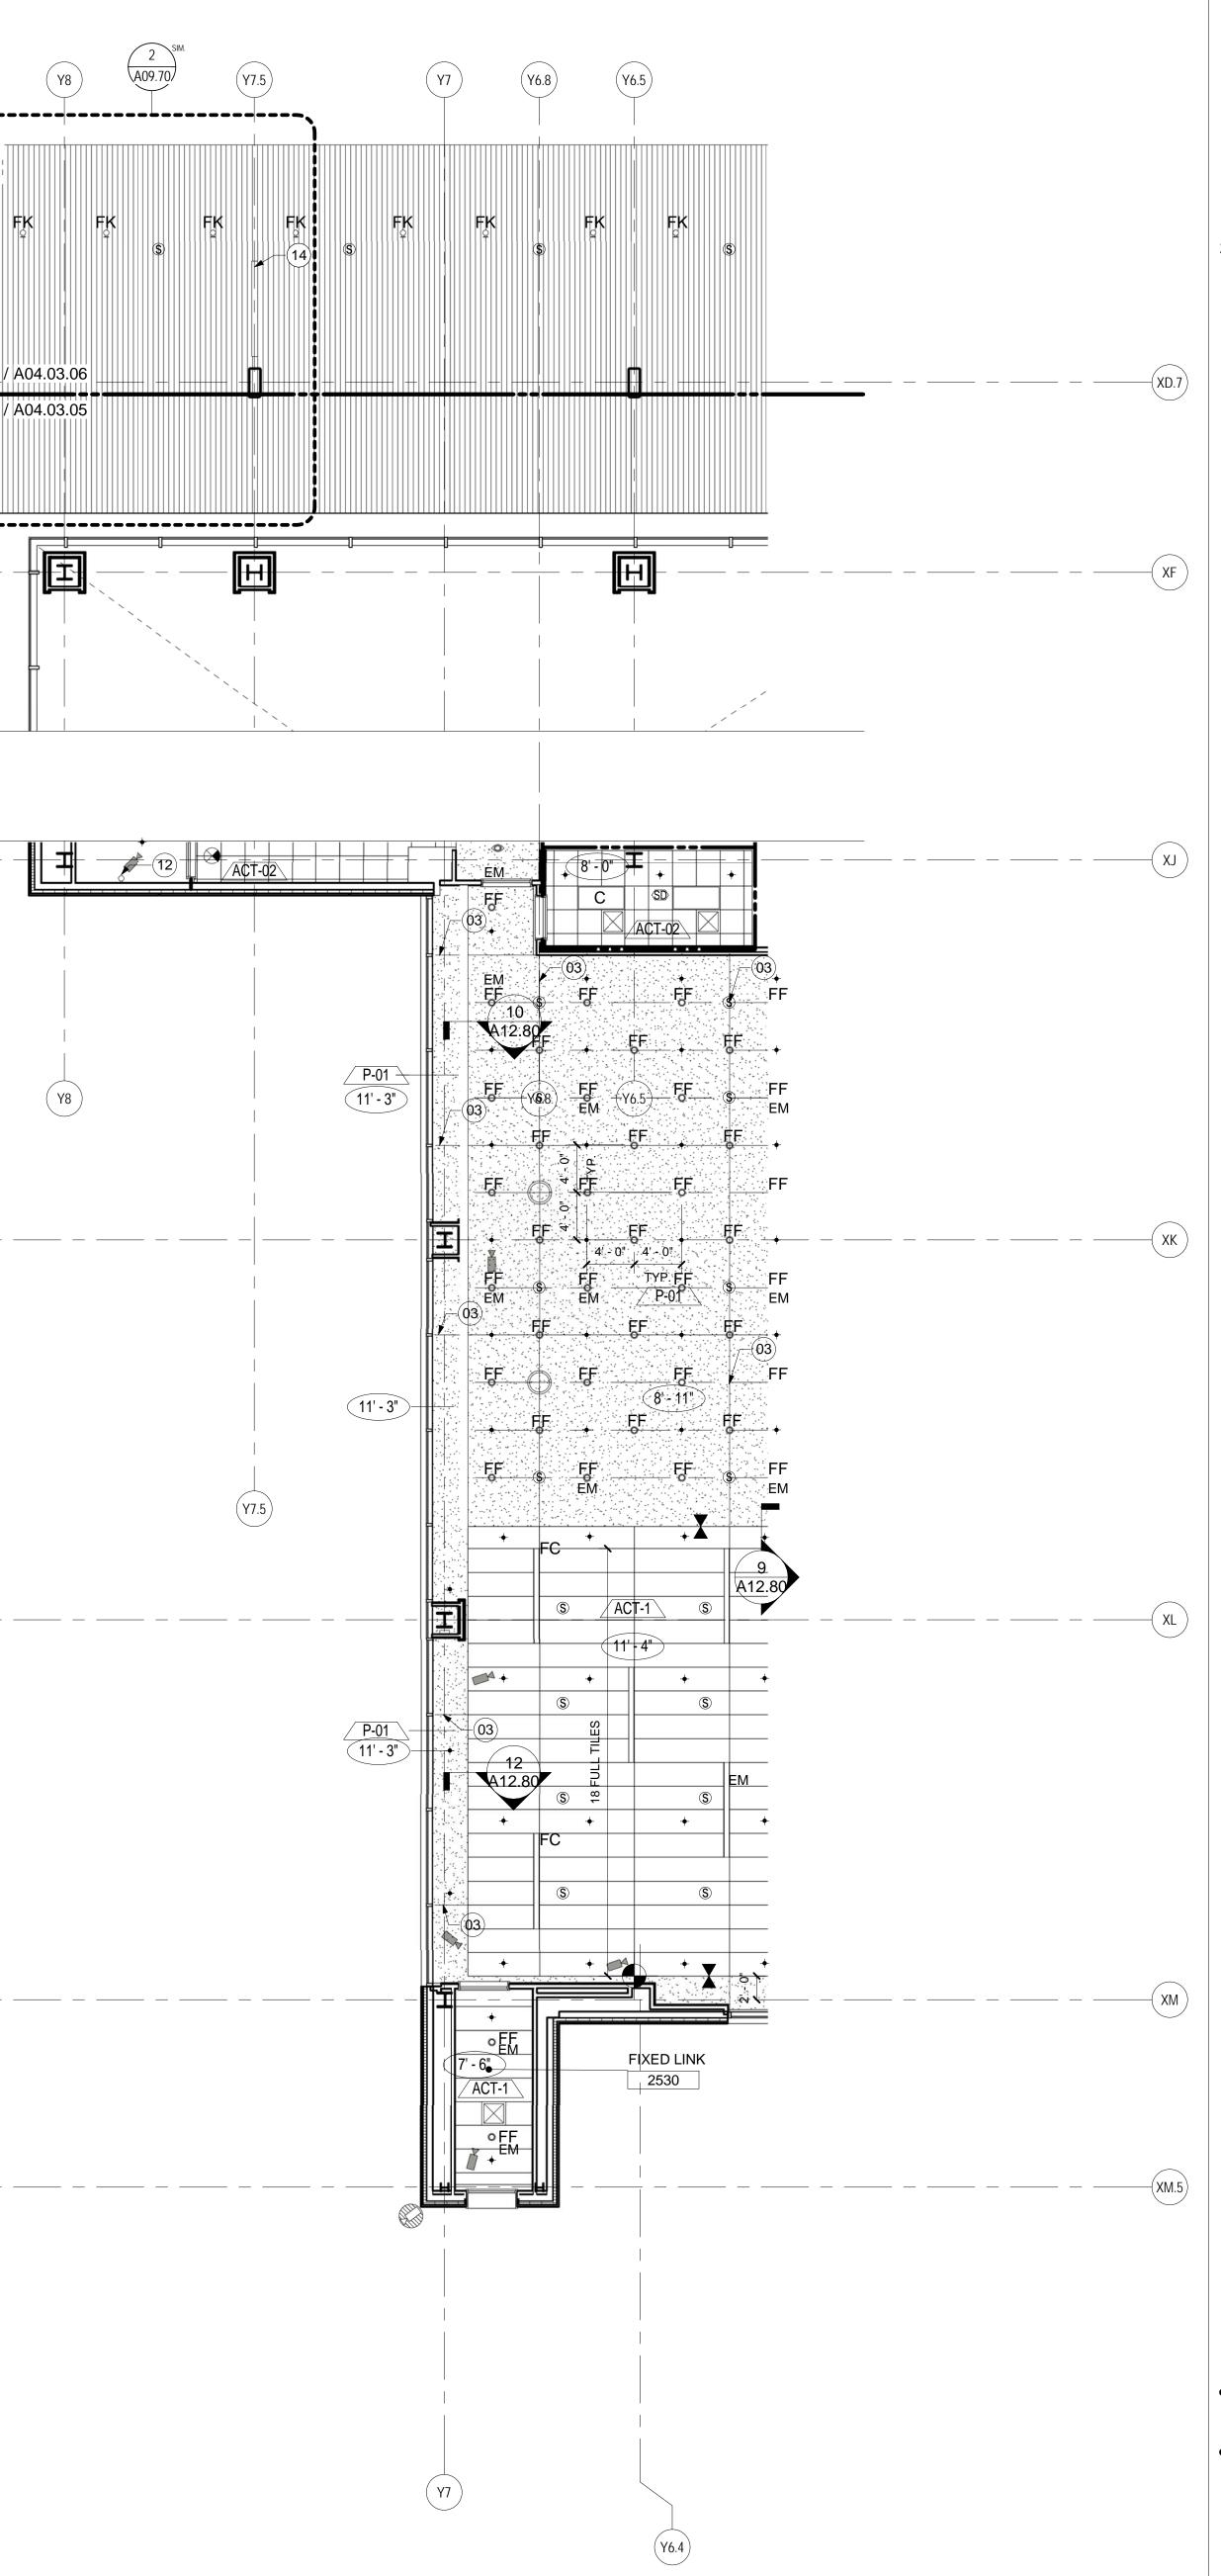

## SHEET NOTES

## 01 NO CEILING

- 02 CEILING BY TENANT
- 03 CONTROL JOINT. REFER TO 06/A12.80
- 04 LIGHTING BY TENANT 05 PATCH AND REPAIR CEILING AS REQUIRED.
- CEILING TO MATCH EXISTING.
- 06 GYP. CEILING. PAINTED P-01 07 ESCALATORS TO HAVE INTEGRAL LIGHTING STRIPS ON SIDE PANELS. PROVIDED BY
- ESCALATOR MANUFACTURER. 09 2-HR RATED GYPSUM BOARD CEILING
- 10 CEILING MOUNTED TV; REFER TO TELECOM DRAWING AND PROJECT MANUAL FOR
- ADDITIONAL INFORMATION 12 PROVIDE LIGHT FIXTURE AT EVERY STAIR LANDING U.O.N. REFER TO ELECTRICAL ENGINEER DRAWINGS FOR MORE
- INFORMATION. 13 FIRE SHUTTER
- 14 SIGNAGE AND WAYFINDING: REFER TO A07 SERIES DRAWING FOR ADDITIONAL INFORMATION
- 15 ACCESS PANEL FOR FIRE SHUTTER. COORDINATE EXACT LOCATION OF PANEL WITH ARCHITECT. 16 12" ROUND ACCESS PANEL
- 17 REINSTALL EXISTING DIFFUSERS; LIGHT FIXTURES; SIGN DEVICES AS PER EXISTING LAYOUT
- 18 CONDUIT FOR CAMERA SHALL BE CONCEALED; FLEX TO RIGID TRANSITION SHALL BE RECESSED WITHIN PARTITIONS. WEATHERPROOF ALL PENETRATIONS AS REQUIRED.
- 19 DASHED LINE INDICATES 3-HOUR RATED FASCIA ABOVE CEILING TO THE U/S OF ROOF. U/S OF FINISHED GYPSUM WALLBOARD CEILING SHALL TRANSITION SMOOTHLY FROM RATED TO UN-RATED SECTIONS.
- 20 REFER TO DETAIL 1/A12.79 FOR CEILING CONSTRUCTION AND FIRE-RATINGS. ALL PENETRATIONS AND DEVICES SHALL BE RATED ACCORDING TO THE CEILING ASSEMBLY WHERE THEY ARE LOCATED.

Portland International Jetport

1001 Westbrook Street Portland, Maine 04102



2020 K Street, Northwest Suite 200 Washington DC 20006

Date

Description 12/03/08 75% CONSTRUCTION DOCUMENTS 01/23/09 95% CONSTRUCTION DOCUMENTS 10/26/09 ISSUED FOR PERMIT 11/12/09ADDENDUM #209/01/11ISSUED FOR CONSTRUCTION

Seal/Signature

**GENERAL NOTES** 

DRAWINGS.

KEY PLAN

A FOR LIGHTING TYPES, DETAILS AND INFORMATION REFER TO PROJECT MANUAL.
B FOR DIFFUSER INFORMATION AND QUANTITY, REFER TO PROJECT MANUAL.
C ALL GWB CEILINGS TO BE PAINTED P-01 U.O.N.

D SPRINKLER HEADS ARE SHOWN FOR DESIGN

F ALL HOLDROOM CEILINGS TO BE ACT-01 U.O.N.


б

**5**4321

G ACT CEILINGS TO BE CENTERED IN EACH ROOM U.O.N.

INTENT ONLY. REFER TO FIRE PROTECTION

DRAWINGS FOR ADDITIONAL INFORMATION. E FOR CAMERA LOCATION AND MOUNTING DETAILS RE: TO IT AND COMMUNICATION ENGINEERS

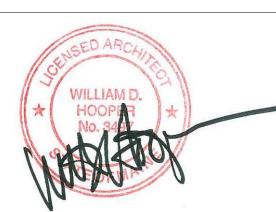

Project Name PWM Terminal Enhancement

Project Number 09.6395.000

Description

REFLECTED CEILING PLAN - LEVEL 3 - ZONE 7

Scale As indicated

© 2009 Gensler



