


Gensler

214 North Tryon Street Suite 2320 Charlotte, NC 28202 United States

Street Tel 704.377.2725 Fax 704.377.2807

CMS & UDIO

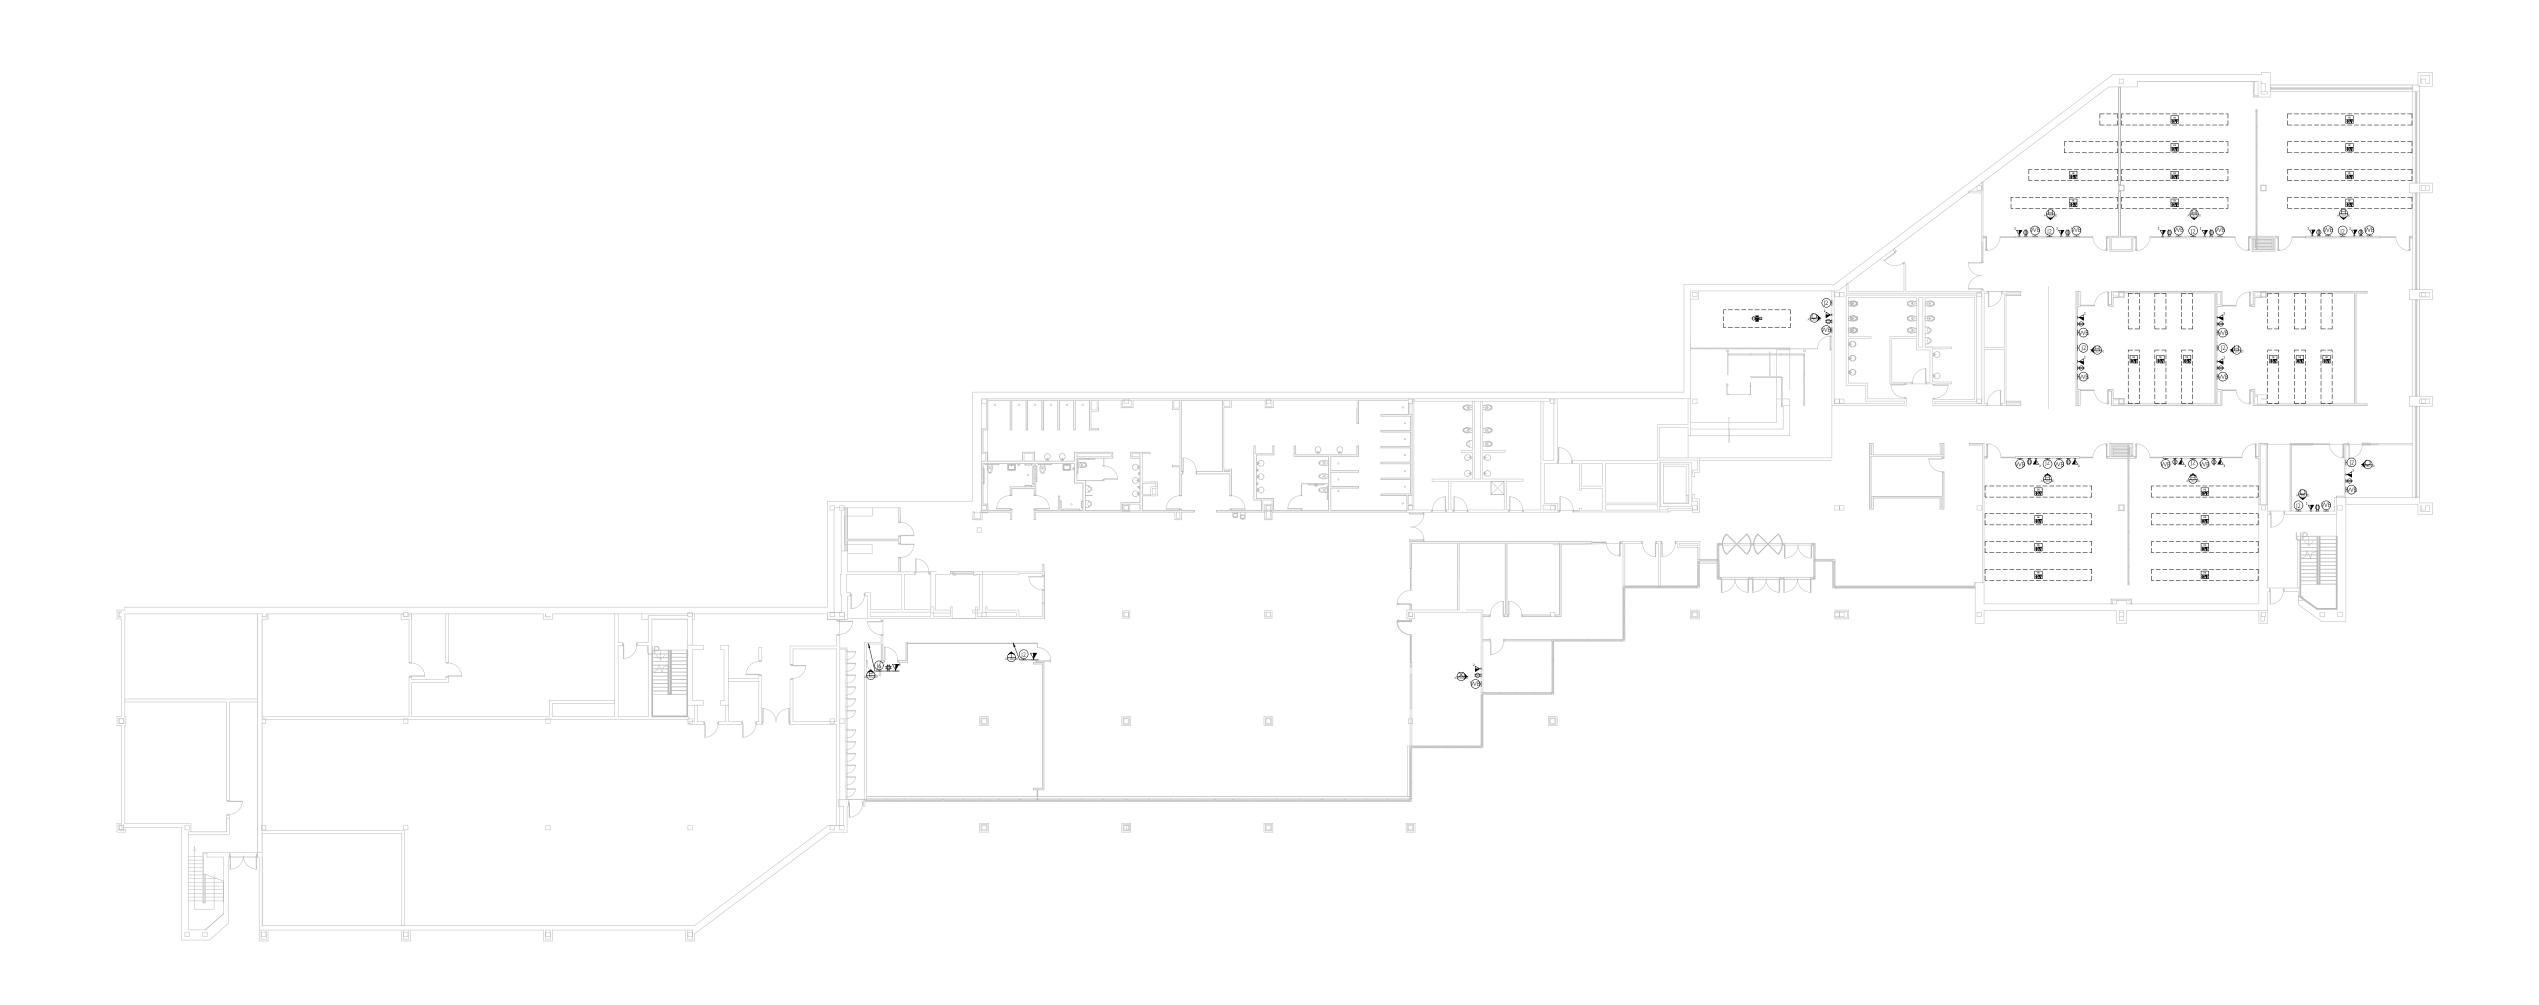

AUDIOVISUAL ELECTRICAL PLAN

FLOOR #HO3-00

• SCALE SIZE: 1/16" = 1'-0"

П	
В)

	SYMBOL	DESCRIPTION	SIZE/TYPE	LOCATION	NOTES	
	PT AV	FLOOR POKE-THRU,(WIREMOLD EVOLUTION 8AT) (SEE DETAIL 05 ON AV.601.00)	WIREMOLD 8AT SERIES OR EQUIVALENT	FLUSH MOUNT IN FLOOR	FLOOR BOX: 4-gang compartment - For audio/video/control (Reference conduit shown on riser) 2-gang compartment - For quad AC power receptacle (Outlet quantity per CMS plans. Power depicted is for AV only conduit for power by others. (Courtesy power by others)	
	Ф	DUPLEX POWER RECEPTACLE DEDICATED POWER CIRCUIT	120 VAC, 20 AMP	FLUSH MOUNT AT BUILDING STANDARD BASE HEIGHT, UNLESS OTHERWISE NOTED.		
AL AL		QUAD POWER RECEPTACLE DEDICATED POWER CIRCUIT	120 VAC, 20 AMP	FLUSH MOUNT AT BUILDING STANDARD for power by others. (Courtesy Data by others)	I-gang compartment - For Voice/Data receptacles (Outlet quantity per CMS plans. Data depicted is for AV only conduit for power by others. (Courtesy Data by others) STUB UP:	
ECTRIC	<u>J#</u>)	AUDIO/VIDEO/CONTROL JUNCTION BOX	4-11/16"H X 2-1/2" DEEP MULTI-GANG JUNCTION BOX. # INDICATES GANG SIZE	FLUSH MOUNT AT BUILDING STANDARD BASE HEIGHT, UNLESS OTHERWISE NOTED.	Conduit - For audio/video/control (Reference riser for quantity and size) Quad AC power receptacle (Outlet quantity per CMS plans. Power depicted is for AV only conduit for power by others. Courtesy power by others) Voice/Data receptacles (Outlet quantity per CMS plans. Data depicted is for AV only conduit for power by others. Courtesy Data by others) WITH "AV" INDICATES POKE THRU DEVICE INCLUDES AV WITH POWER & DATA	
	$\mathbf{Y}^{\#}$	VOICE/DATA RECEPTACLE	ANALOG PHONE LINE / LAN LINES AS INDICATED ON DWGS # = Designation of quantity of ports / cables.	FLUSH MOUNT AT BUILDING STANDARD BASE HEIGHT, UNLESS OTHERWISE NOTED.		
	WB	AV IN-WALL BOX	IN-WALL AV PRE-WIRE WALL BOX SEE DISPLAY DETAIL FOR SPECIFICATION	FLUSH MOUNT IN WALL AT HEIGHT AS INDICATED ON DRAWINGS		
	CA-TV	CABLE TELEVISION SYSTEM FEED	RG-6 QUAD SHIELD TEFLON COAX TO CABLE TV RISER CLOSET			
	⊕ TL	POWER RECEPTACLE DEDICATED POWER CIRCUIT	L5-20 TWIST LOCK RECEPTACLE			
	FB ₩ ▼	AV FLOORBOX FSR FL-640P	12" X 10" X 6" DEEP, WITH COMPARTMENTS FOR MULTIPLE SERVICES POWER AND DATA	S, FLUSH MOUNT IN FLOOR		

∆ Date Descrip

 11/21/2017
 REVIEW & COORDINATION

 11/28/2017
 REVIEW & COORDINATION

 12/05/2017
 REVIEW & COORDINATION

12/14/2017 CD

Seal / Signature

NOT FOR CONSTRUCTION

Project Name

Unum Workplace
Transformation- Phase 2 & 3
Project Number

59.6481.003

AUDIOVISUAL ELECTRICAL PLAN

Scale 1/8" = 1'-0"

AV.202.HO3-00

015 Gensler